


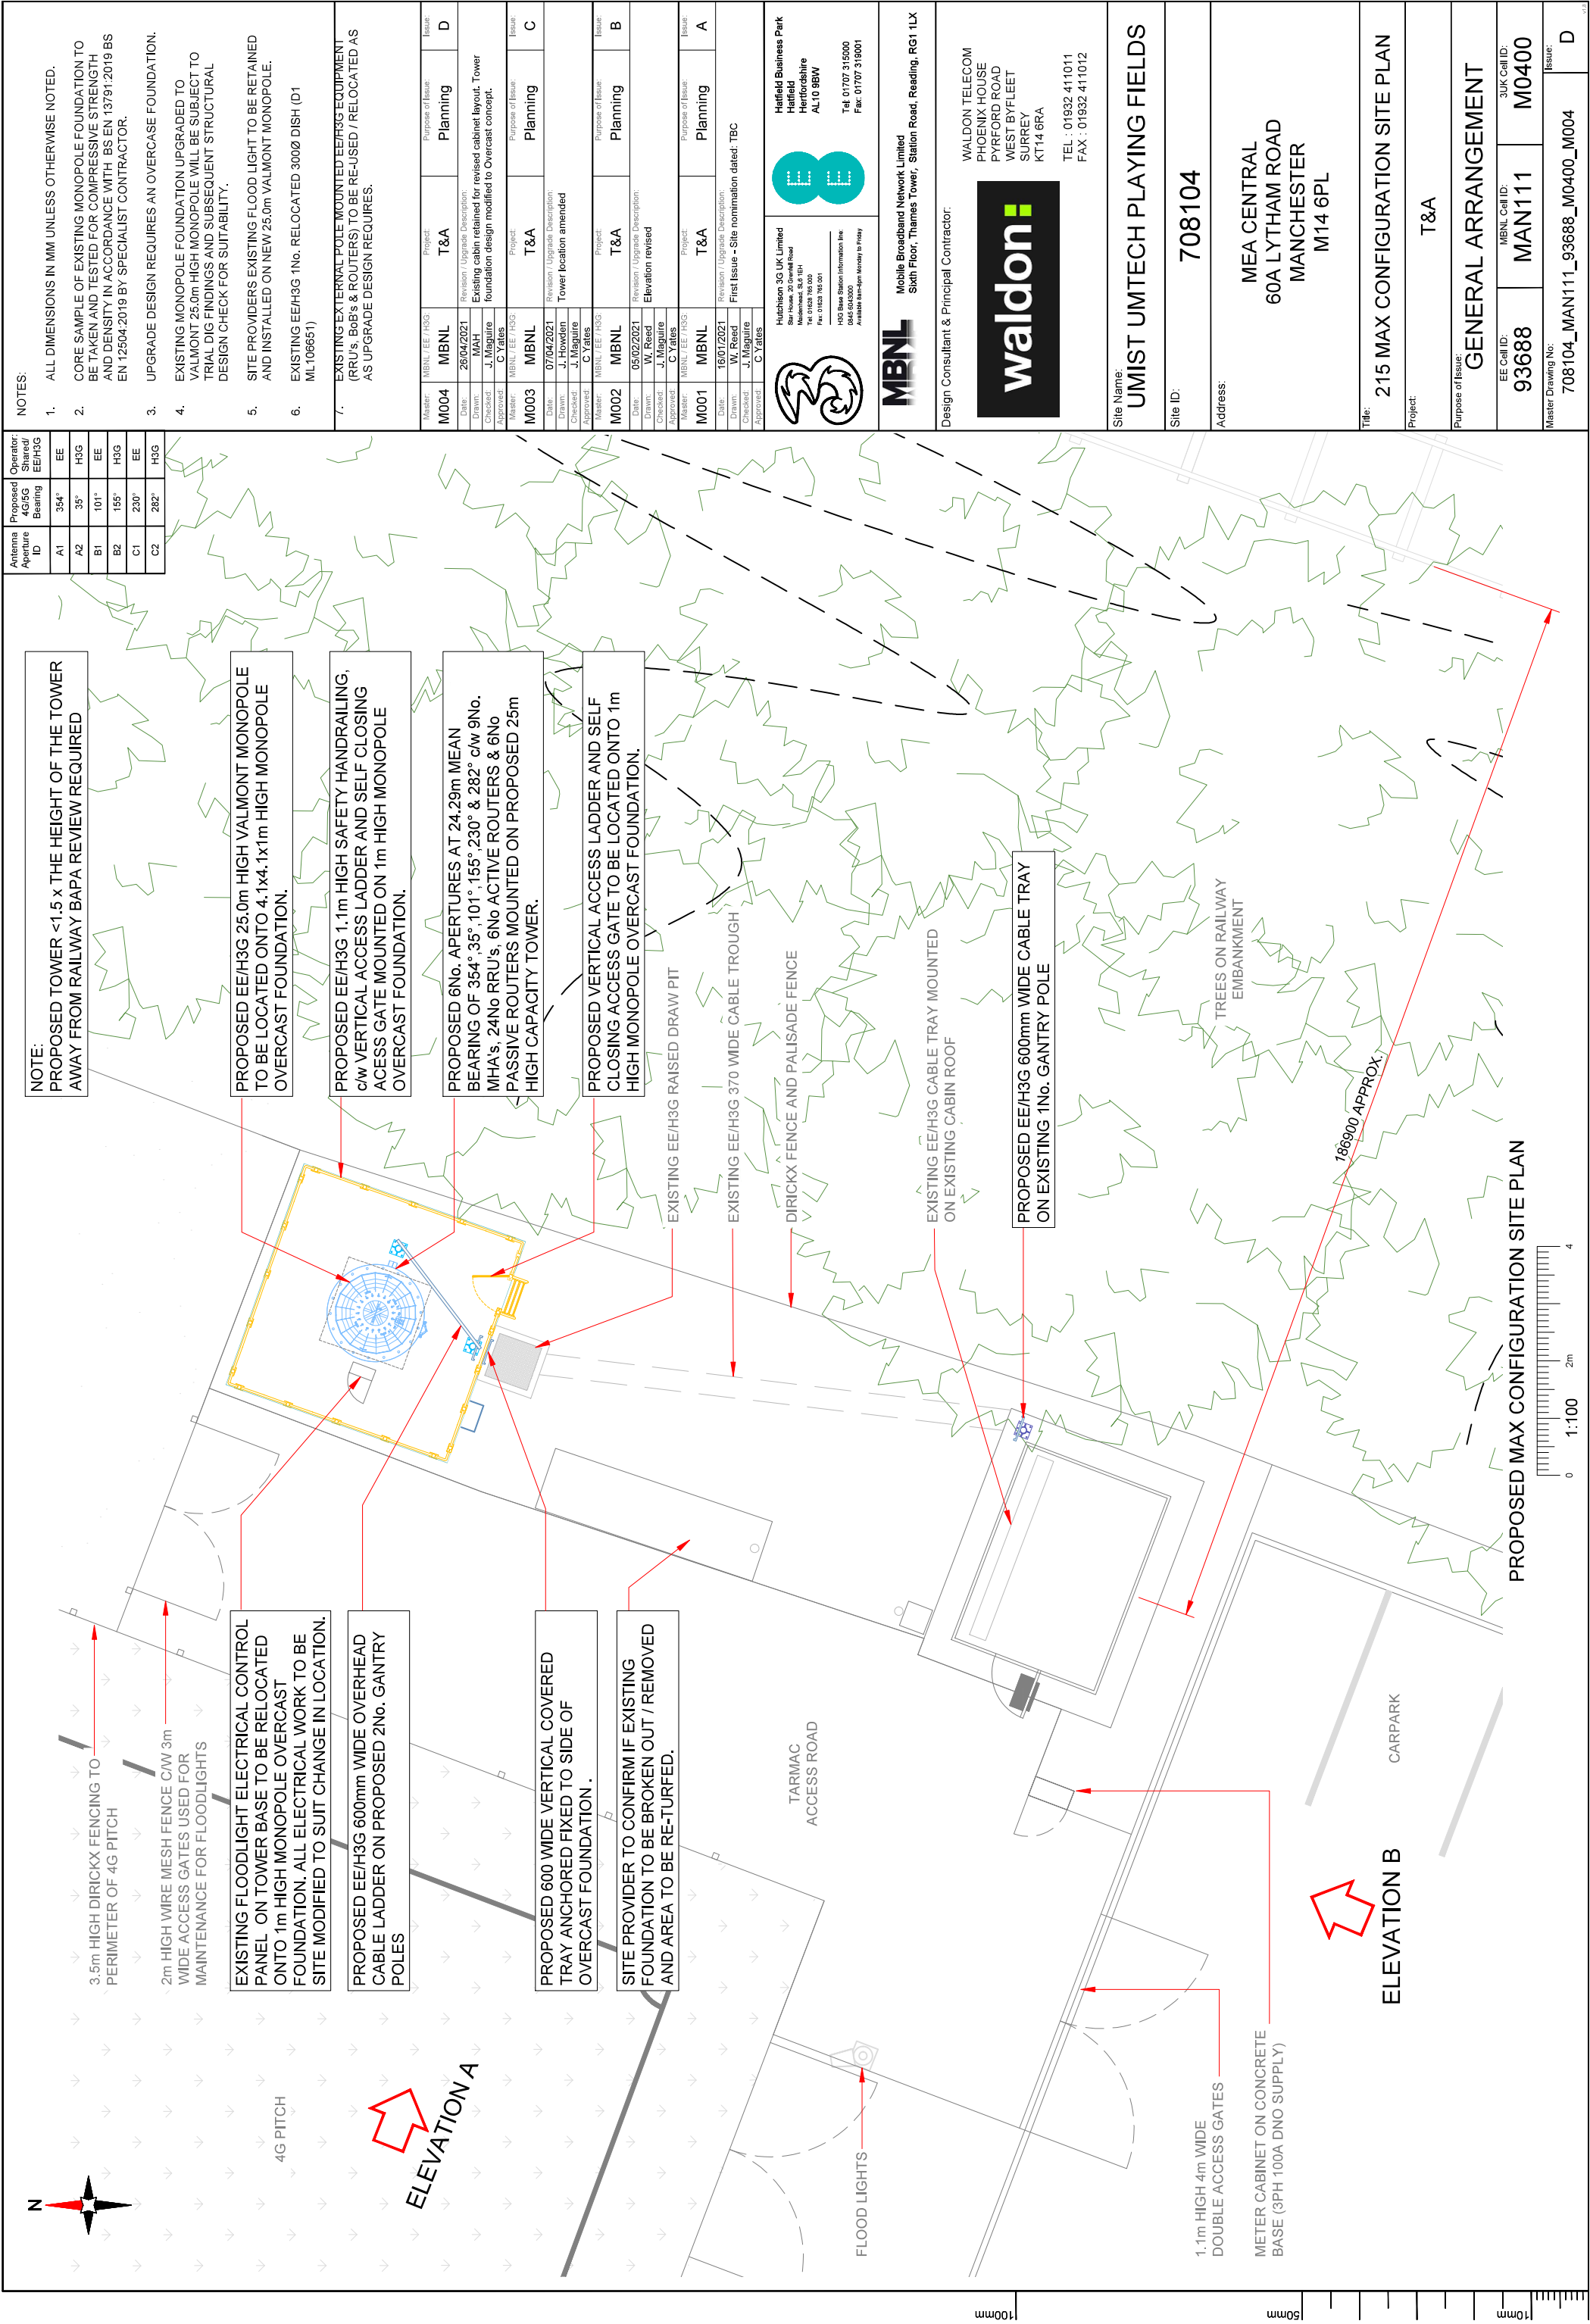

Antenna Aperture ID	Proposed 4G/5G Shared/ Bearing	Operator: EE/ H3G
A1	354°	EE
A2	35°	H3G
B1	101°	EE
B2	155°	H3G
C1	230°	EE
C2	282°	H3G

NOTES:
1. ALL DIMENSIONS IN MM UNLESS OTHERWISE NOTED.
2. CORE SAMPLE OF EXISTING MONOPOLE FOUNDATION TO BE TAKEN AND TESTED FOR COMPRESSIVE STRENGTH AND DENSITY IN ACCORDANCE WITH BS EN 13791:2019 BS EN 12504:2019 BY SPECIALIST CONTRACTOR.
3. UPGRADE DESIGN REQUIRES AN OVERCASE FOUNDATION.
4. EXISTING MONOPOLE FOUNDATION UPGRADED TO VALMONT 25.0m HIGH MONOPOLE WILL BE SUBJECT TO TRIAL DIG FINDINGS AND SUBSEQUENT STRUCTURAL DESIGN CHECK FOR SUITABILITY.
5. SITE PROVIDERS EXISTING FLOOD LIGHT TO BE RETAINED AND INSTALLED ON NEW 25.0m VALMONT MONOPOLE.
6. EXISTING EE/H3G 1No. RELOCATED 3000 DISH (D1 ML 106651)
7. EXISTING EXTERNAL POLE MOUNTED EE/H3G EQUIPMENT (RRU's, BoB's & ROUTERS) TO BE RE-USED / RELOCATED AS AS UPGRADE DESIGN REQUIRES.

Master:	MBNL / EE / H3G	Project:	T&A	Purpose of Issue:	Issue:
M004	MBNL			Planning	D
Date:	26/04/2021	Revision / Upgrade Description:	Existing cabin retained for revised cabinet layout. Tower foundation design modified to Overcast concept.		
Drawn:	MAH	Checked:	J. Maguire		
Approved:	C Yates				
Master:	MBNL / EE / H3G	Project:	T&A	Purpose of Issue:	Issue:
M003	MBNL			Planning	C
Date:	07/04/2021	Revision / Upgrade Description:	Tower location amended		
Drawn:	J. Howard	Checked:	J. Maguire		
Approved:	C Yates				
Master:	MBNL / EE / H3G	Project:	T&A	Purpose of Issue:	Issue:
M002	MBNL			Planning	B
Date:	05/02/2021	Revision / Upgrade Description:	Elevation revised		
Drawn:	W. Reed	Checked:	J. Maguire		
Approved:	C Yates				
Master:	MBNL / EE / H3G	Project:	T&A	Purpose of Issue:	Issue:
M001	MBNL			Planning	A
Date:	16/01/2021	Revision / Upgrade Description:	First Issue - Site nomination dated: TBC		
Drawn:	W. Reed	Checked:	J. Maguire		
Approved:	C Yates				

Hubbison 3G UK Limited
Star House, 20 Dorehill Road
Maidenhead, SL6 6PH
Tel: 01628 760 000
Fax: 01628 760 001
H3G Base Station Information line
0845 6543000
Approved Network Ready to Deploy

EE
Hatfield Business Park
Hatfield
Hertfordshire
AL10 9BW
Tel: 01707 315000
Fax: 01707 316001

Mobile Broadband Network Limited
Sixth Floor, Thames Tower, Station Road, Reading, RG1 1LX

Design Consultant & Principal Contractor.

WALDON TELECOM
PHOENIX HOUSE
PYRFORD ROAD
WEST BYFLEET
SURREY
KT14 6RA
TEL : 01932 411011
FAX : 01932 411012

Site Name:
UMIST UMTECH PLAYING FIELDS

Site ID:
708104

Address:
**MEA CENTRAL
60A LYTHAM ROAD
MANCHESTER
M14 6PL**

Title:
215 MAX CONFIGURATION SITE PLAN

Project:
T&A

Purpose of Issue:
GENERAL ARRANGEMENT

EE Call ID:	MBNL Call ID:	3UK Call ID:
93688	MAN111	M0400

Master Drawing No:
708104_MAN111_93688_M0400_M004

Issue:
D