




COMMERCIALDW
DRAINAGE AND WATER ENQUIRY

SEWER RECORD LAND AT MAYTON STREET MANCHESTER M11 2AN

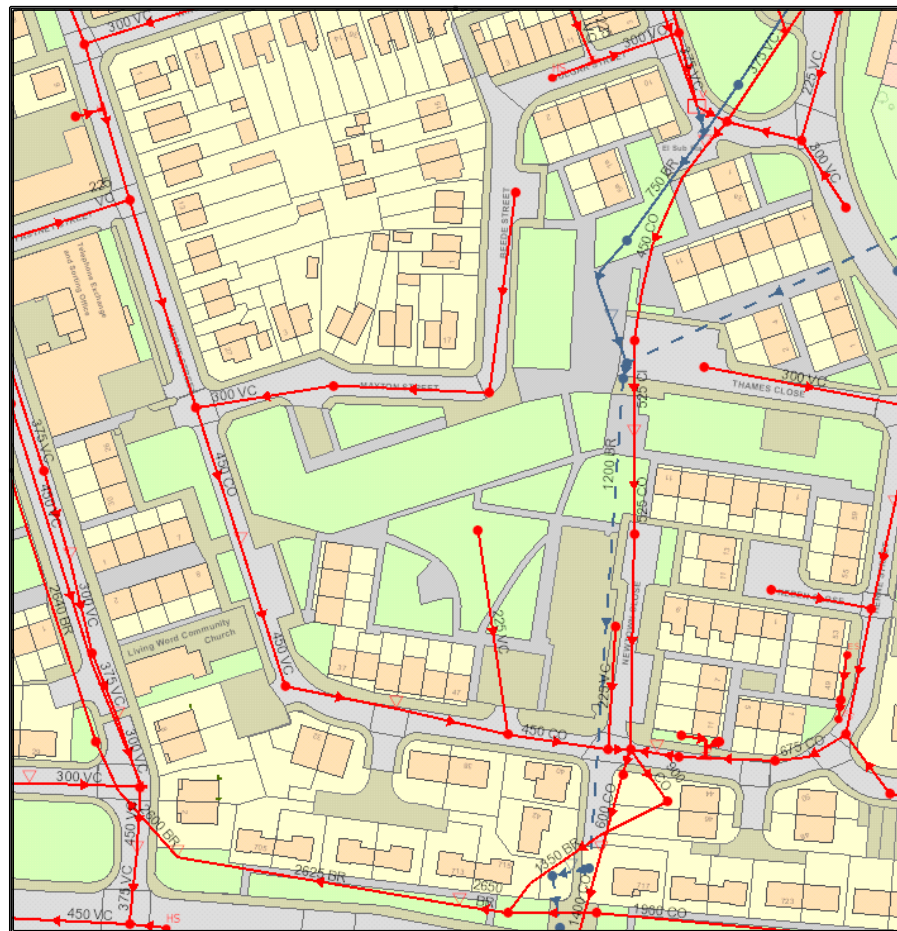


The position of underground apparatus shown on this plan is approximate only and is given in accordance with the best information currently available. The actual positions may be different from those shown on the plan and private pipes, sewers or drains may not be recorded. United Utilities Water Limited will not accept any liability for any damage caused by the actual positions being different from those shown.

© United Utilities Water Limited 2016. The plan is based upon the Ordnance Survey Map with the sanction of the Controller of H.M. Stationery Office, Crown copyright 100022432 and United Utilities Water Limited copyrights are reserved. Unauthorised reproduction will infringe these copyrights.

Received Date 7/2/2019 Response Date 11/2/2019 4 of 24

UU Ref: 1406438

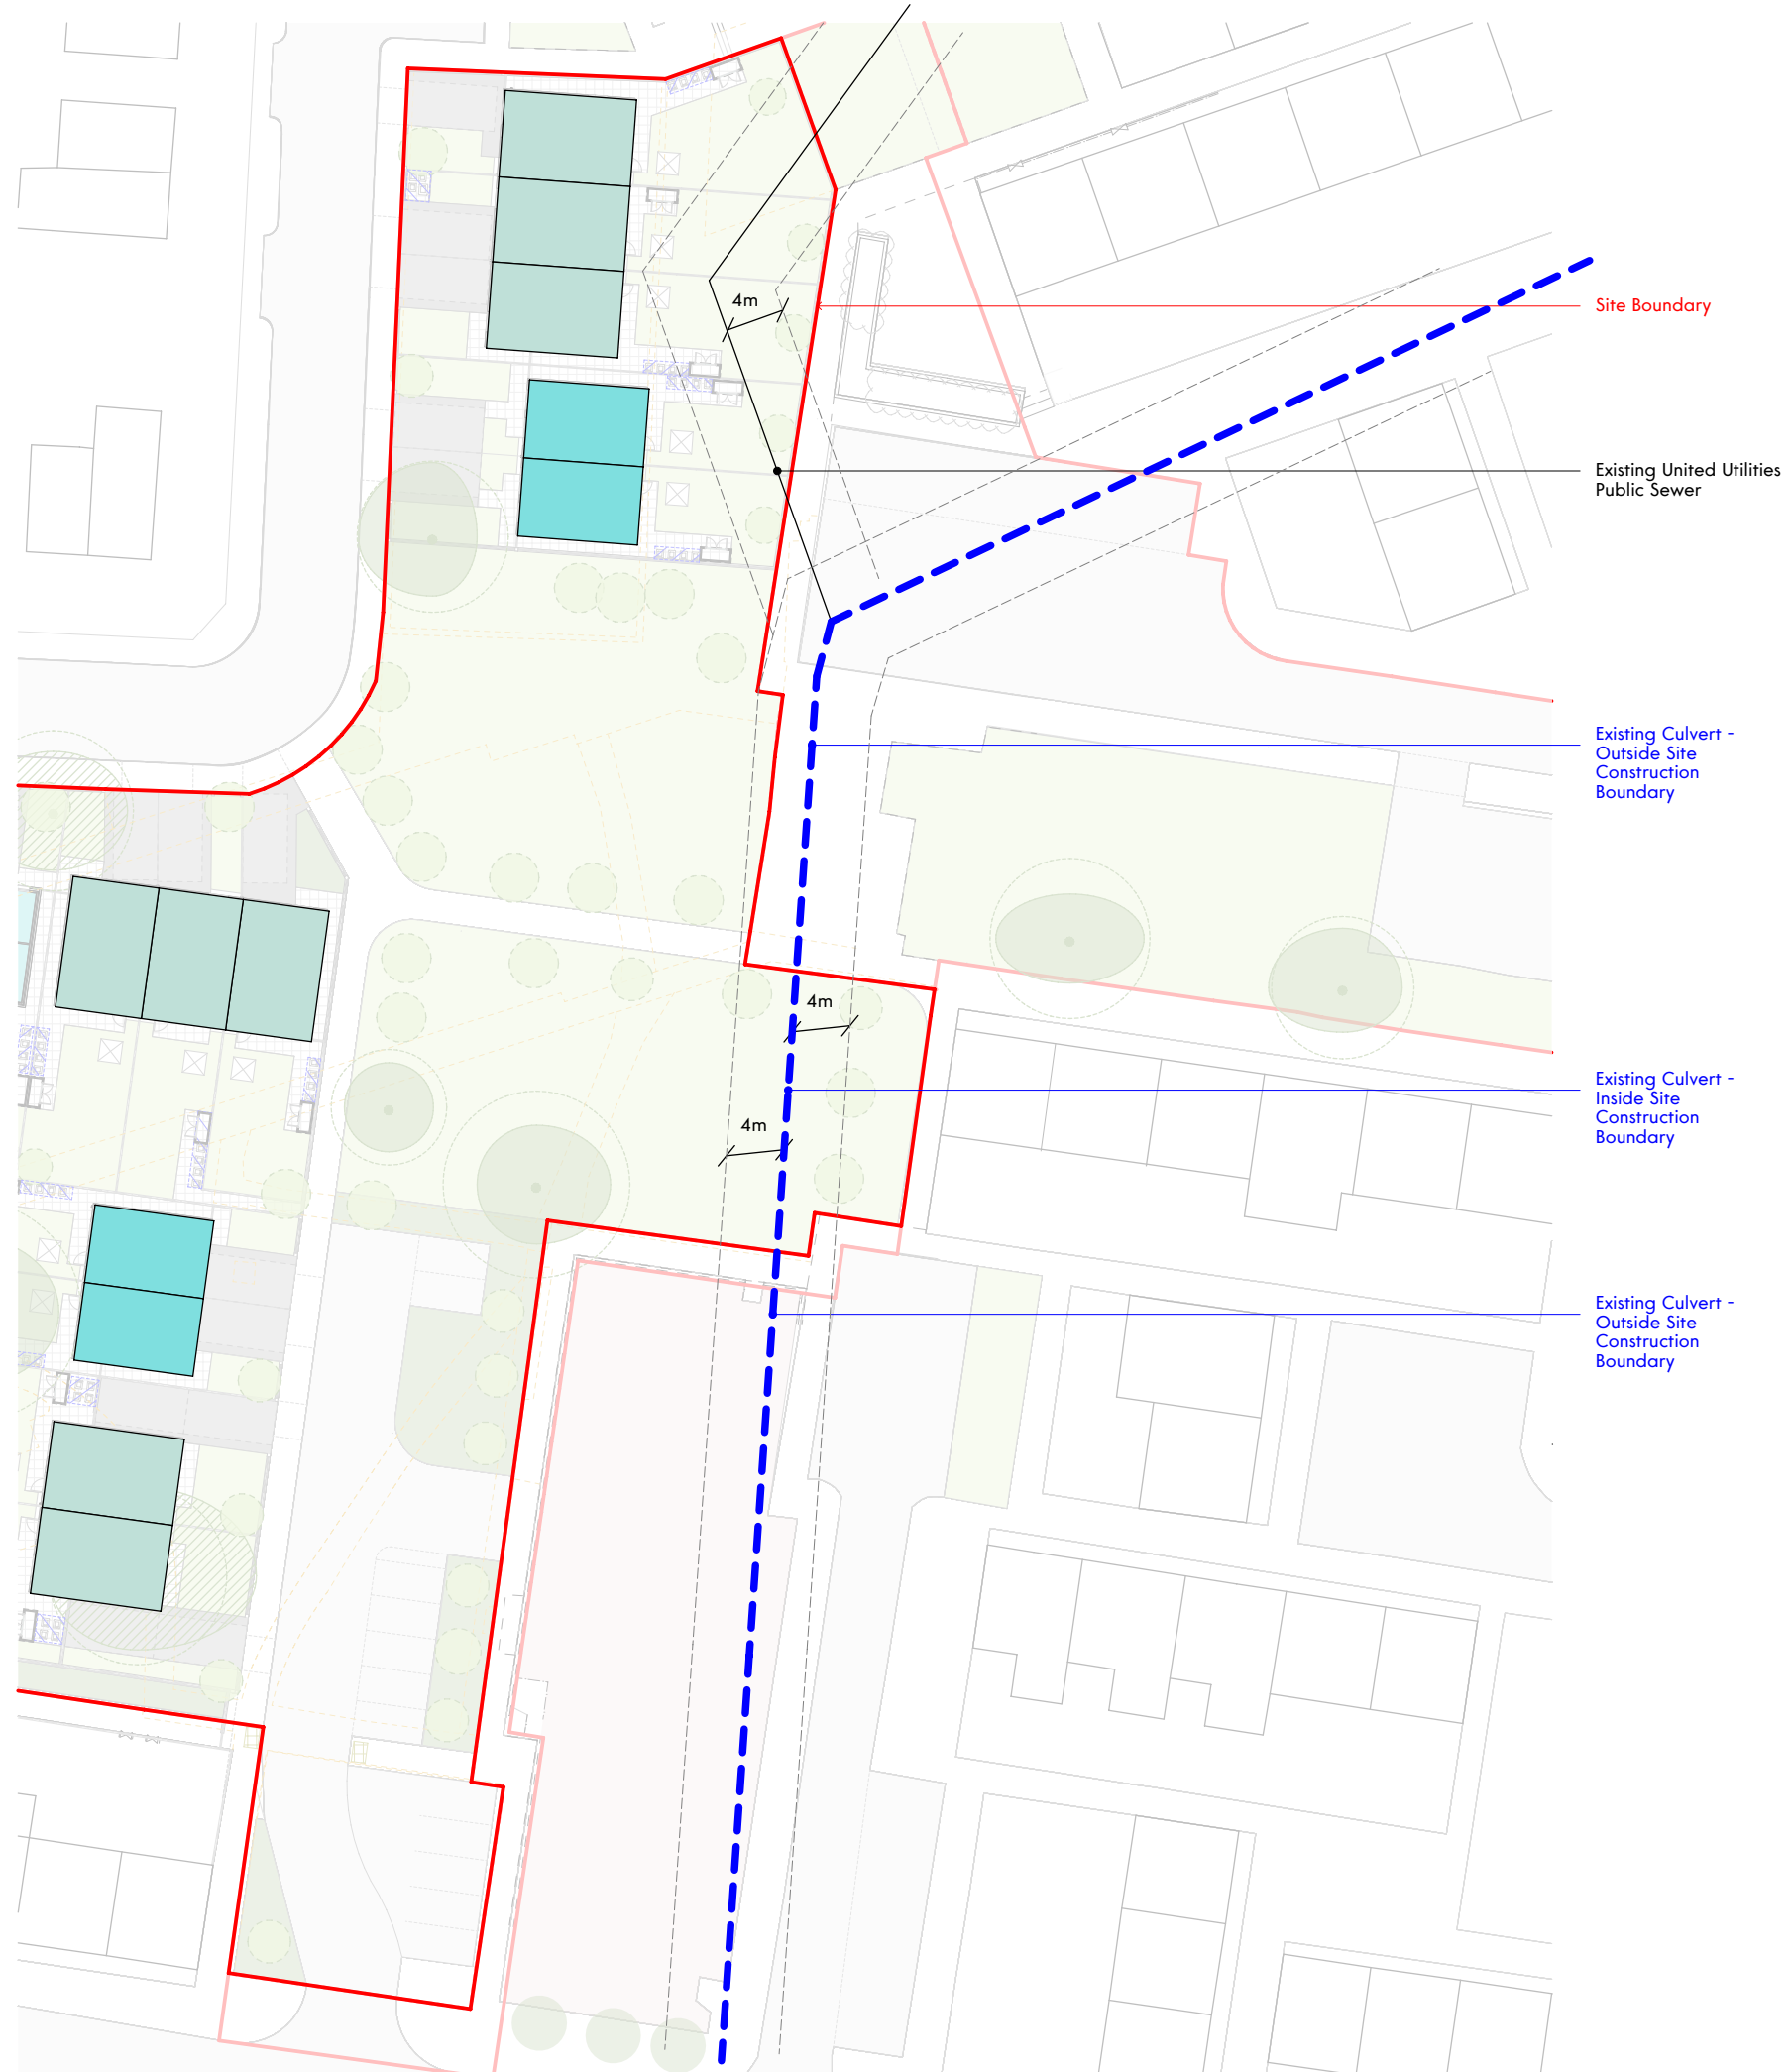

This drawing is the property of CWP Architects. Copyright is reserved by them and the drawing is not to be used for any other purpose without the written consent of CWP Architects. All drawings and specifications should be read in conjunction with the project brief and any other documents referred to in the project brief. The design is subject to the following:

Local Planning Constraints
Planning/Regulatory Requirements
Building Regulations Approval / Fire Engineering
Rights of Light Issues

0 1m 5m 10m
Scale: 1:250 (B1)



Name: 1914-GWP-01-01-DR-A (SK) 74
Scale: 1:250 (B1) Rev / Status: WP / S
Dr/Checked: DT / SW Date of Issue: 01/01/2019

Mayton Street
Mayton St. Site Plan Drainage Overlay