



NOTES:
All dimensions must be checked on site and not scaled from this drawing.

Ref.	Date	Revisions	By
C02	11.06.19	REVISIONS AS CLOUDED	B.C.
C03	10.02.19	THOROUGHFARE LIGHTING UPDATED	B.C.
C04	07.01.21	CAR PARK LUMINAIRE ORIENTATION AMENDED	B.C.
C05	12.02.21	LIGHTING CONTROLS AMENDED	B.C.
C06	13.03.21	EMERGENCY BULKHEADS ADDED	B.C.

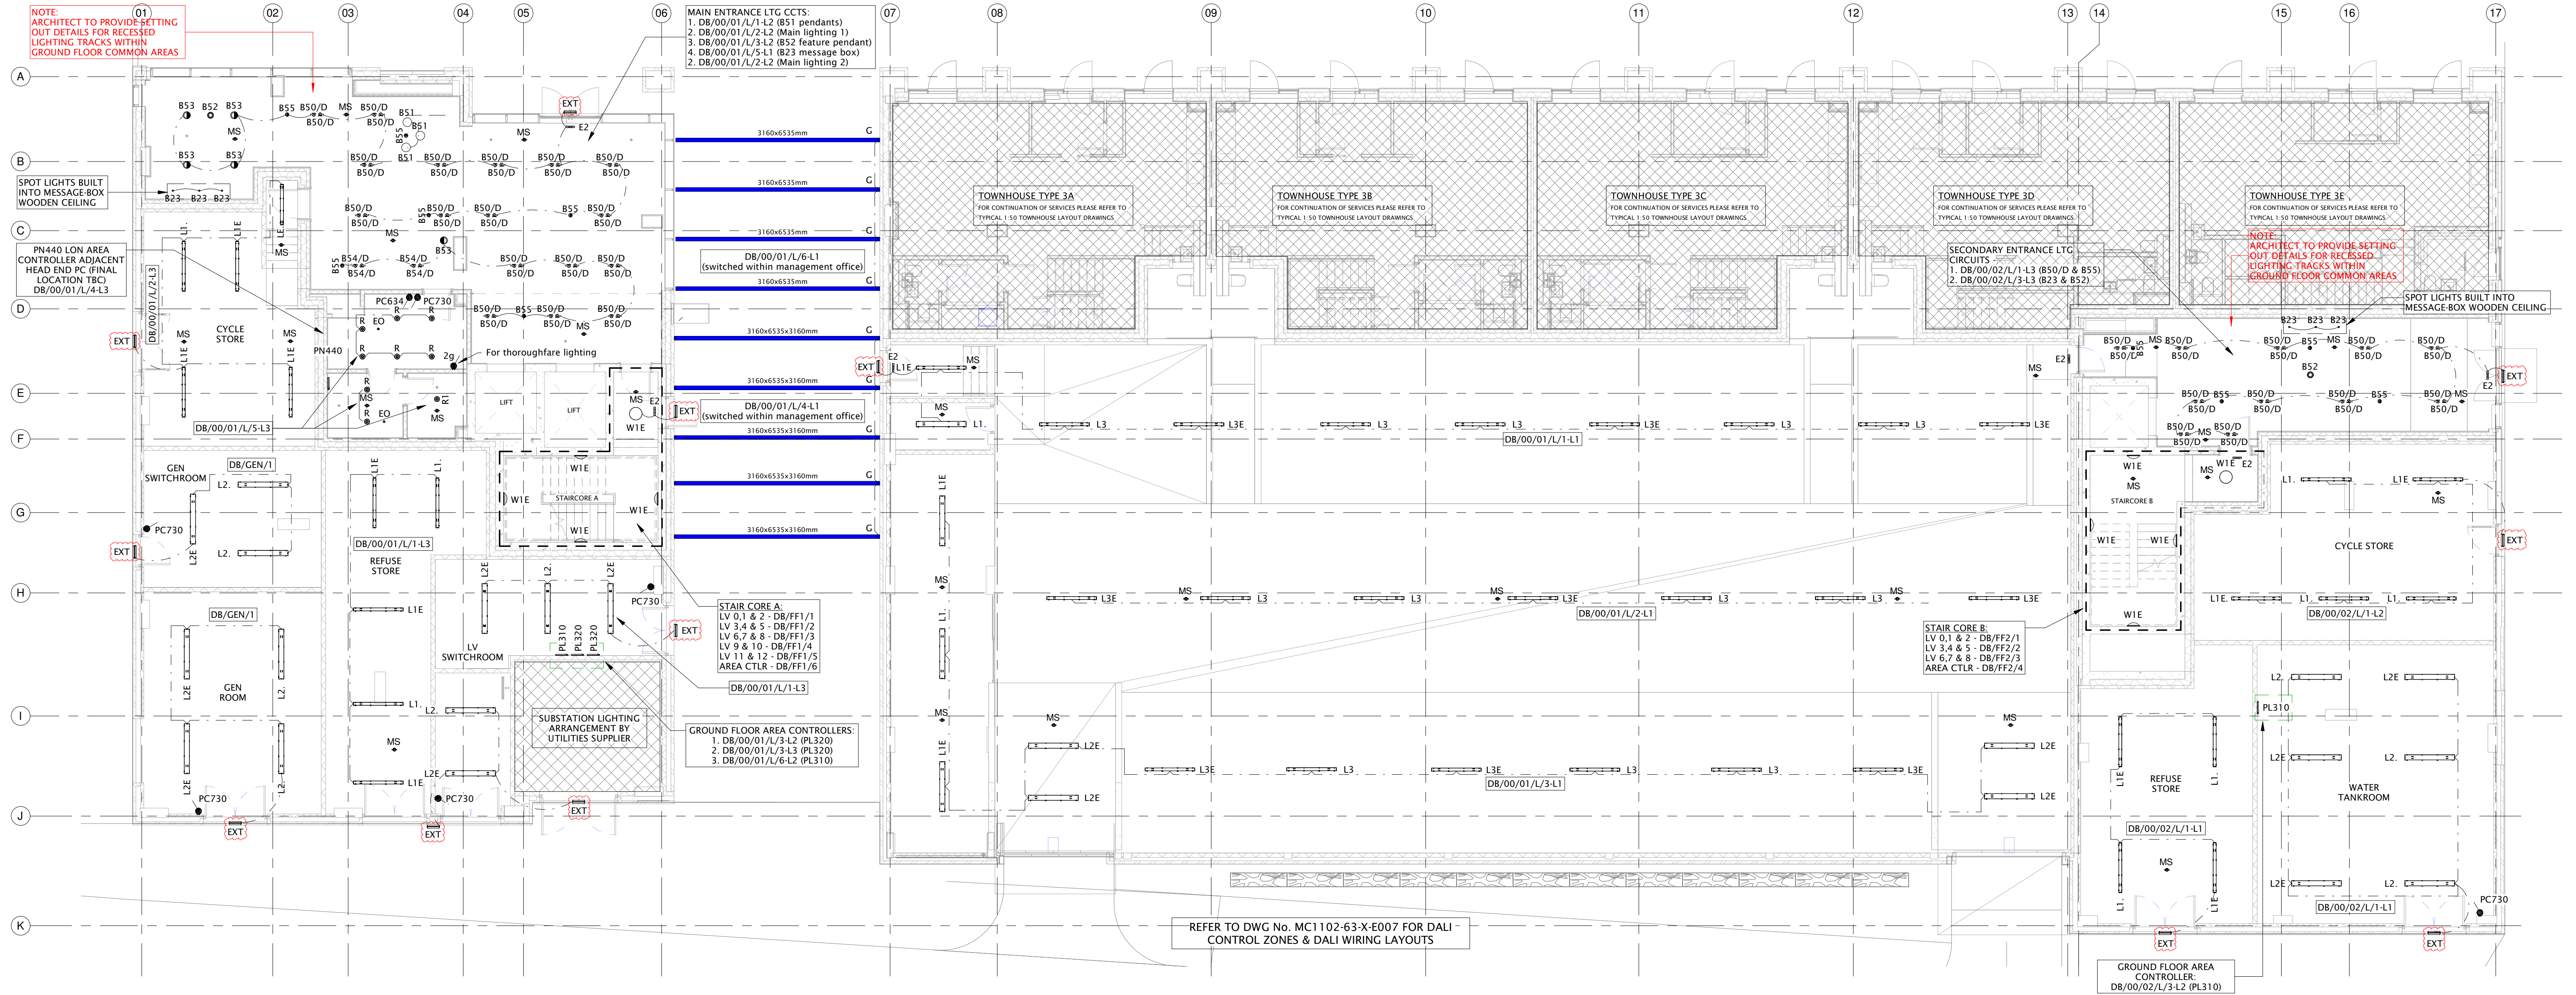


LEVEL 00 - LANDLORD LIGHTING LAYOUT

1 : 100

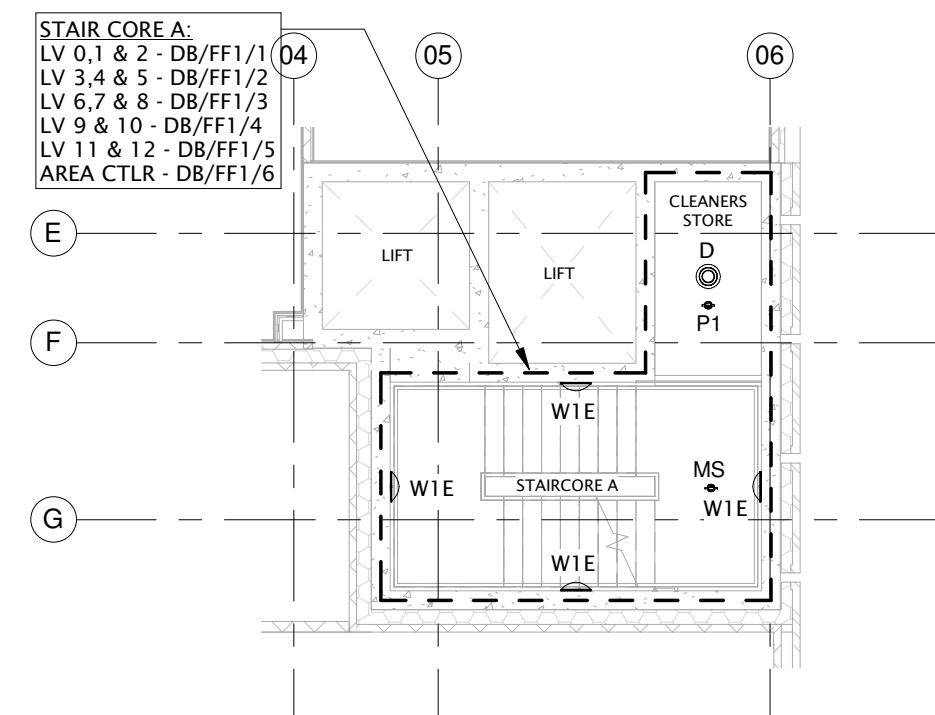

LEVEL 01 STAIRCORE A - LANDLORD LIGHTING LAYOUT

1 : 100

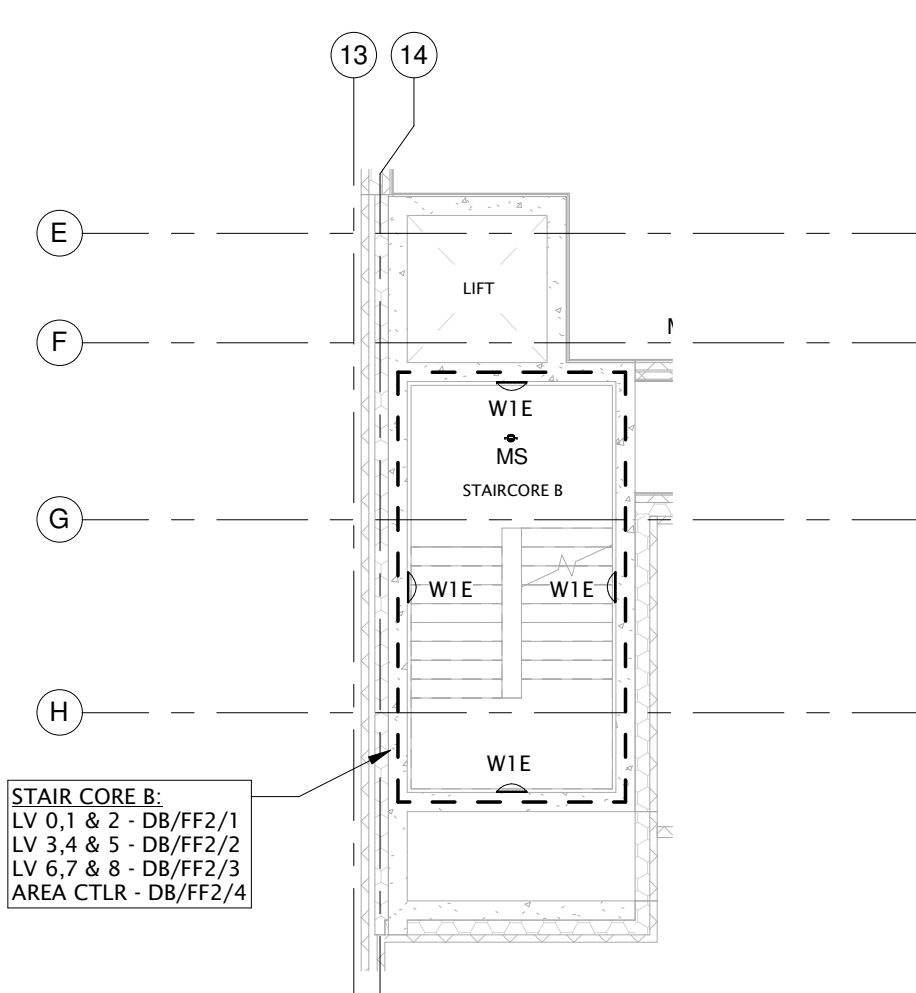

LEVEL 01 STAIRCORE B - LANDLORD LIGHTING LAYOUT

1 : 100

GENERAL NOTES:

1. ALL DIMENSIONS ARE IN MILLIMETRES UNLESS OTHERWISE INDICATED.
2. THIS DRAWING IS TO BE READ IN CONJUNCTION WITH THE DISTRIBUTION BOARD SCHEDULES AND LIGHTING TECHNICAL SUBMITTALS.
3. INTERNAL EMERGENCY EXIT SIGN POSITIONS TO BE ADVISED BY OTHERS IN ACCORDANCE WITH BS5499, INCLUDING ARROW ORIENTATION.
4. PRINCIPLE CONTRACTOR TO ENSURE ALL EMERGENCY EXIT SIGNAGE POSITIONS/ DIRECTION ARROWS ARE AGREED WITH BUILDING CONTROL PRIOR TO CONSTRUCTION.
5. ALL EMERGENCY LIGHT FITTINGS TO BE POWERED FROM LOCAL LIGHT CIRCUIT.
6. ARCHITECT TO CONFIRM SETTING OUT LOCATIONS OF ALL FIXTURES AND PROVIDE REFLECTED CEILING PLANS FOR SITE USE.
7. REFER TO DWG No. MC1102-63-X-E007 FOR DALI CONTROL ZONES & DALI WIRING LAYOUT.

INTERNAL FEATURE LIGHTING LEGEND:

- | | |
|-------|--|
| B50/D | GIMBAL BLACK LED 19W 1860lm DIMMABLE 3000K |
| B51 | SLIM VIBIA 4LED 2.1W 385lm 2700K |
| B52 | FEATURE PENDANT - AGNES CHANDELIER 14 LIGHTS |
| B53 | SPOTLIGHT VLED 200C 300K INTEGRAL EMERGENCY BATTERY |
| B54/D | GIMBAL BLACK LED 19W 1860lm DIMMABLE 3000K (NARROW BEAM) |
| B55 | SELF CONTAINED EMERGENCY LED DOWNLIGHT |

INTERNAL LIGHTING LEGEND:

- | | |
|-------|---------------------------------------|
| B23/D | AST/800/84 ASTORIA 821lm 8W 840 200mA |
| B24 | LILY 2 TR 500lm 5.3W |
| D | LDB/16/HF/C BULKHEAD |
| R | RAV/13W/IP44/OPAL/1360lm |
| R1 | RAV/16.5W/IP44/OPAL/1960lm |
| L | WPR/14/3120/4 32.45W 4187lm |
| L1 | WPR/15/4190/4 32.45W 4187lm |
| L2 | WPR/25/6680/4 45.88W 6681lm |
| L3 | WPR/25/2680/4 19.3W 2678lm |
| W1E | ZMP LED/3217lm EMR |
| EC | LED2/KIT/CORRIDOR OPTIC/MON |
| EO | LED2/KIT/OPEN AREA OPTIC/MON |

'E' DENOTES LUMINAIRE TO C/W 3 HOUR INTEGRAL EMERGENCY BATTERY

EMERGENCY EXIT LEGEND:

- | | |
|-----|--|
| E1 | LED EXIT SIGN WALL MOUNTED ARROW UP |
| E2 | LED EXIT SIGN CEILING MOUNTED ARROW UP |
| E3 | LED EXIT SIGN CEILING MOUNTED ARROW DOWN |
| E4 | LED EXIT SIGN CEILING MOUNTED DOUBLE SIDED |
| E5 | LED EXIT SIGN CEILING MOUNTED ARROW RIGHT |
| E6 | LED EXIT SIGN CEILING MOUNTED ARROW LEFT |
| E7 | LED EXIT SIGN CEILING MOUNTED ARROW LEFT (DIAGONAL DOWN) |
| EXT | LP/CB5532/DA IP65 DALI EMERGENCY BULKHEAD |

EXTERNAL LIGHTING LEGEND:

- | | |
|---|---|
| G | NEVADA RECESSED FLANGE MOUNTED EXTRUSION HOUSING LED STRIP LIGHT (SIZE AS DETAILED) |
|---|---|

LIGHTING CONTROL LEGEND:

- | | |
|-----|----------------------------|
| P1 | INFRARED PRESENCE DETECTOR |
| MW1 | MICROWAVE SENSOR |
| S | SCENE SELECTION PLATE |
| — | CIRCUIT LINE |
| → | SWITCH LEADER |

DALI CONTROL LEGEND:

- | | |
|-------|--|
| PC634 | SCENE SELECT SWITCH (FOR SWITCHING FOH LIGHTING ON/OFF) |
| PC730 | SWITCH WITH DALI ADDRESSABLE INTERFACE |
| PL3** | DALI CONTROLLER w. PSU PL310 - 64 ADDRESSES PL320 - 2x64 ADDRESSES PL330 - 3x64 ADDRESSES PL340 - 4x64 ADDRESSES |
| PN440 | LON AREA CONTROLLER |
| MS | P5432 MULTI-SENSOR |

ameon
Building Services Engineering
Unit 9-10 Olympic Court, Boardmans Way,
Whitehills Business Park, Blackpool, FY4 5GU
Tel: 01253 760160
Fax: 01253 760150
E-mail: info@ameon.co.uk

CONSTRUCTION

Client	Job Title	Drawing Title	Date NOVEMBER 2018
DEX CONSTRUCTION	ANGEL MEADOWS PLOT 5	LEVEL 00 & 01 LANDLORD LIGHTING LAYOUT	Scale @ A1 As indicated
			Drawn by A.T.
			Drawing Number MDW-AMN-00-ZZ-DR-E-6301
			Revision C06