


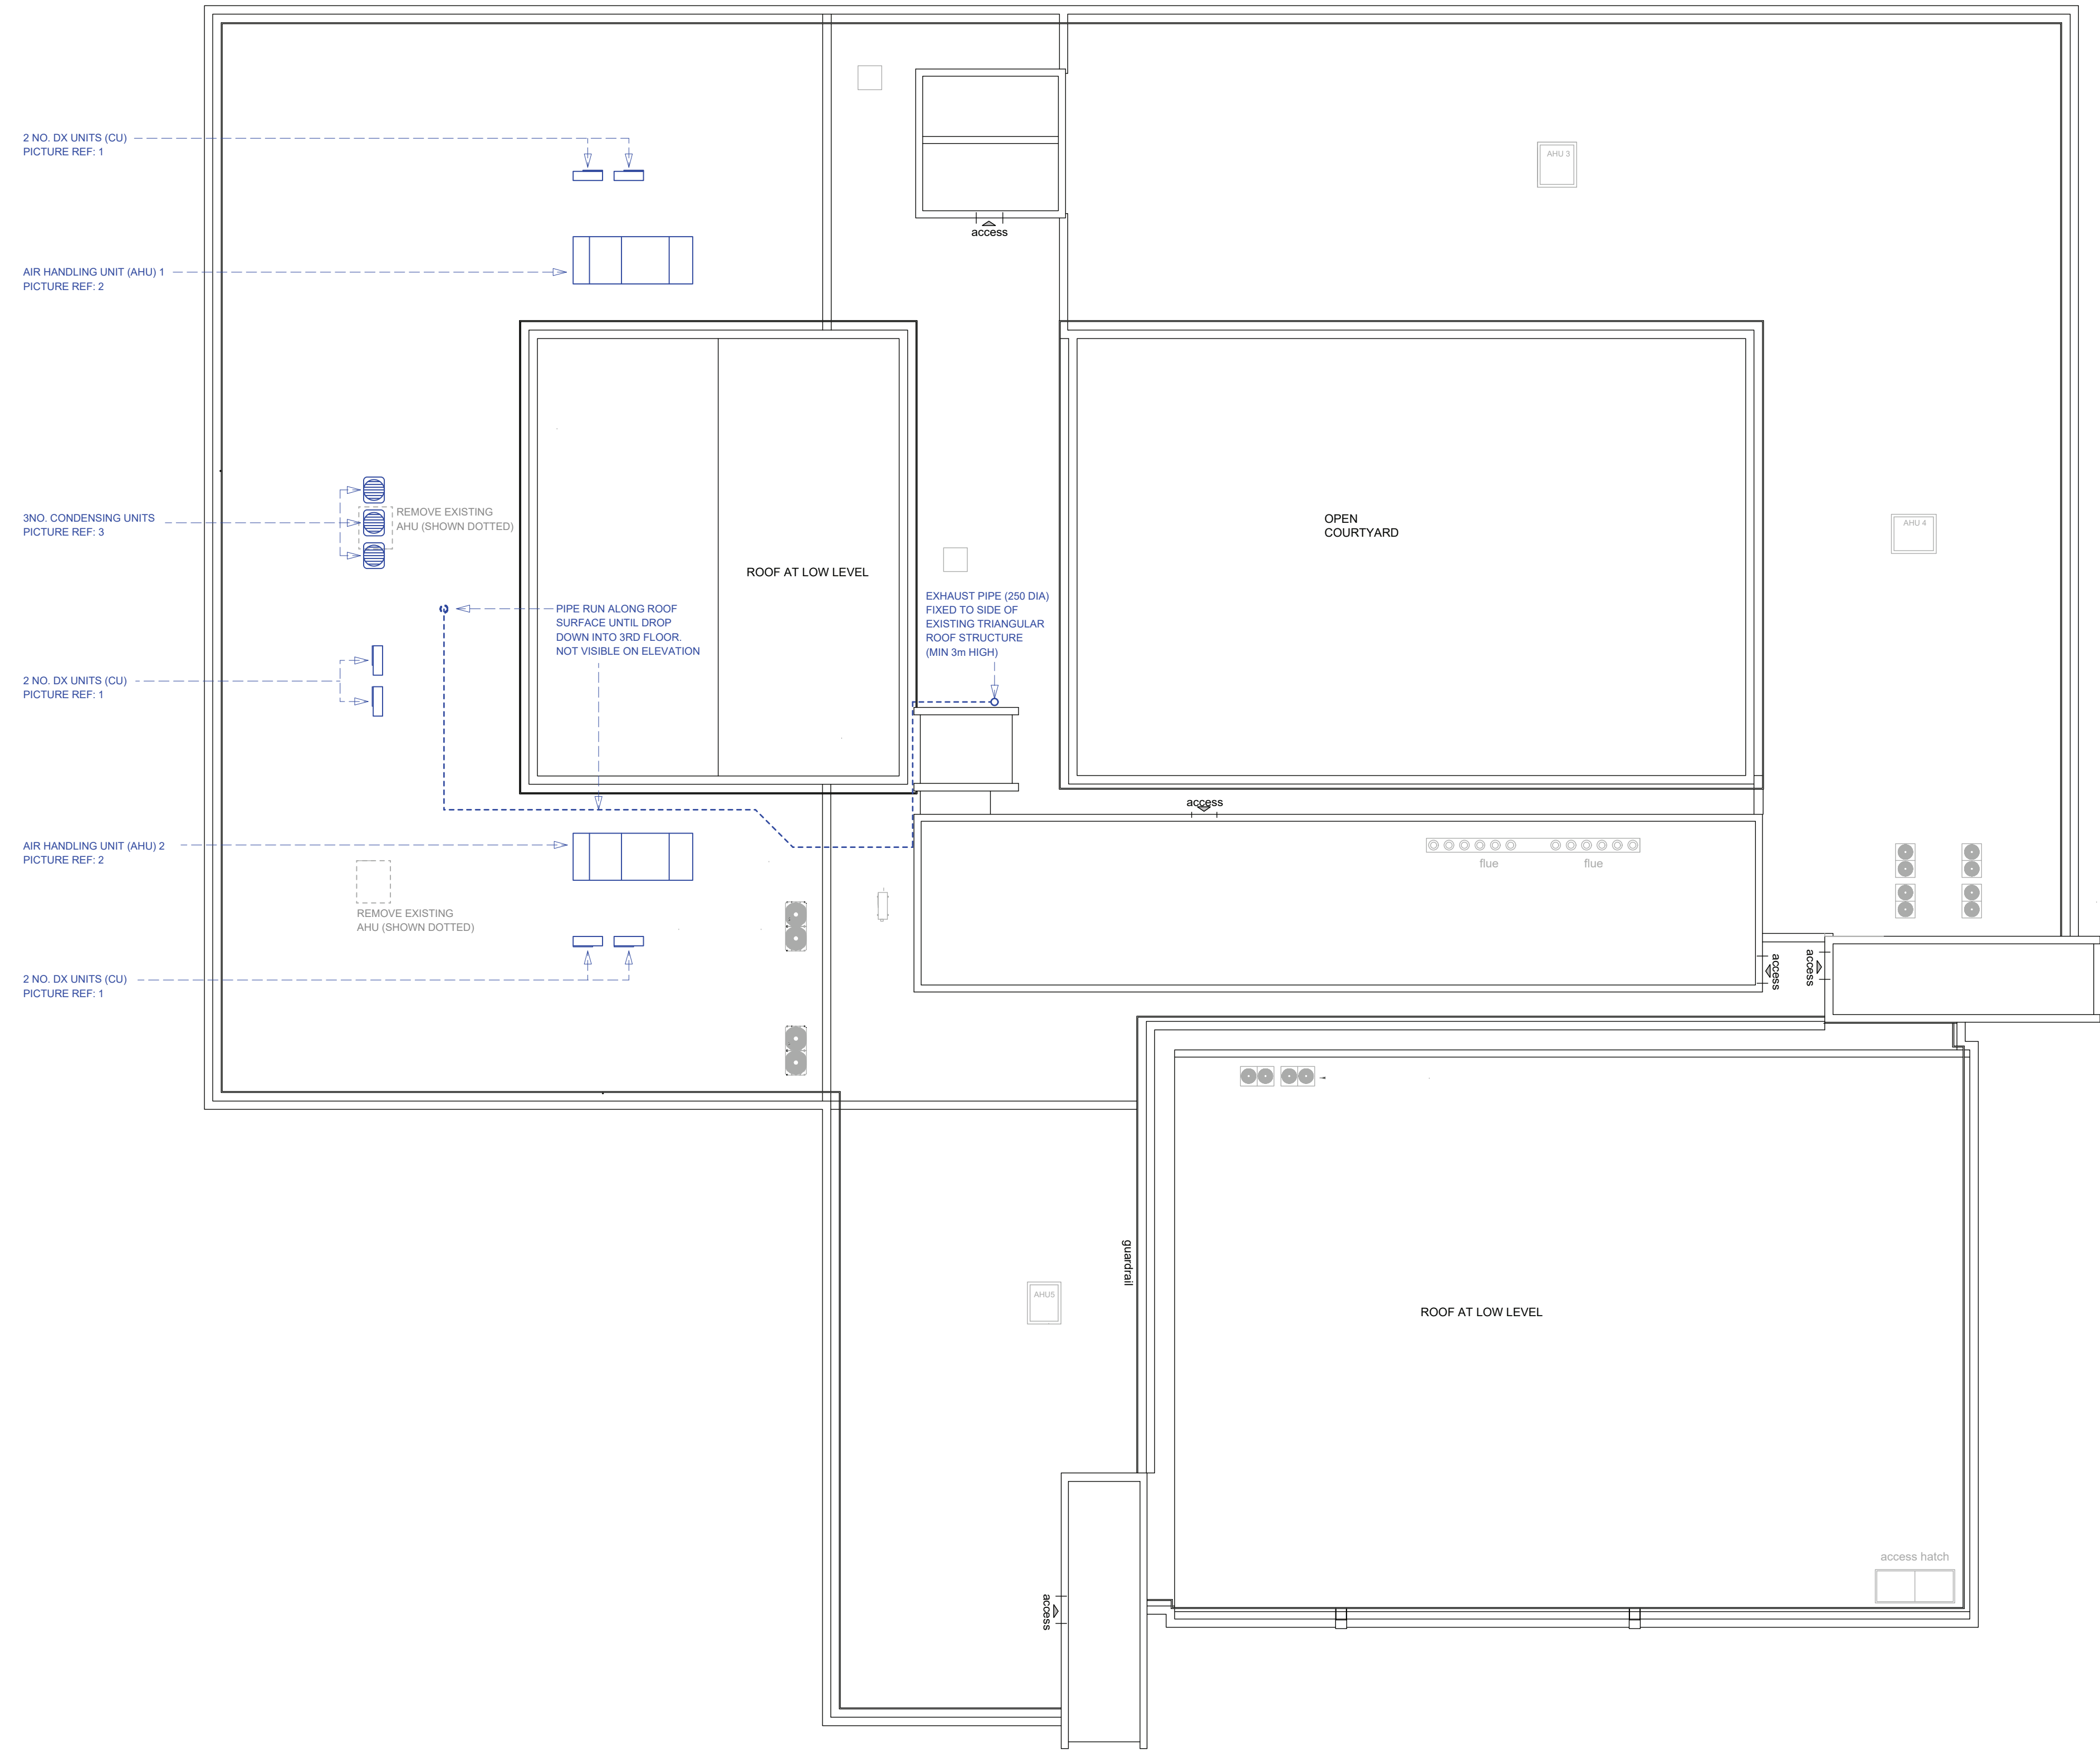

Roof Plan as Proposed (1:150 Scale)



PICTURE REF: 1
DX UNITS (CU)



PICTURE REF: 2
AIR HANDLING UNIT (AHU)



PICTURE REF: 3
CONDENSING UNIT (CU)

© BOWKER SADLER PARTNERSHIP LIMITED
■ THIS DRAWING IS THE SUBJECT OF COPYRIGHT WHICH VESTS IN BOWKER SADLER PARTNERSHIP LIMITED. IT IS AN INFRINGEMENT OF COPYRIGHT TO REPRODUCE THIS DRAWING, BY WHATEVER MEANS, INCLUDING ELECTRONIC, WITHOUT THE EXPRESS WRITTEN CONSENT OF BOWKER SADLER PARTNERSHIP LIMITED WHICH RESERVES ALL ITS RIGHTS
BOWKER SADLER PARTNERSHIP LIMITED ASSERTS ITS RIGHTS TO BE IDENTIFIED AS THE AUTHOR OF THIS DESIGN
■ DRAWING NOT TO BE SCALED.
■ REPORT ERRORS & OMISSIONS TO ARCHITECT.
■ CHECK ALL DIMENSIONS ON SITE
■ DRAWING TO BE READ IN CONJUNCTION WITH THE HEALTH AND SAFETY PLAN AND ALL RELEVANT RISK ASSESSMENTS

NOTE: THIS ANALYSIS IS BASED
UPON A VISUAL SURVEY AND PLANS
PLANS PROVIDED BY MMU IN JUN '20

DIMENSIONS SHOULD BE VERIFIED
ON SITE PRIOR TO INSTALLATION
OF WORKS

REV	DATE	DRN	CHKD
PROJECT Manchester Technology Centre Third Floor Fit-Out			
CLIENT Manchester Metropolitan University			
DRAWING Roof Plan as Proposed			
SCALE 1 : 150	SHEET SIZE @A1	DRAWN DC	CHECKED DL
DATE 22.02.21			
BOWKER SADLERARCHITECTURE A: Hatherlow House, Hatherlow, Romiley, Stockport SK6 3DY T: 0161 406 7333 E: office@bowker-sadler.co.uk W: www.bowker-sadler.co.uk			
JOB No 20-011	DRAWING No 1005	REVISION	
STATUS		Planning	