
 


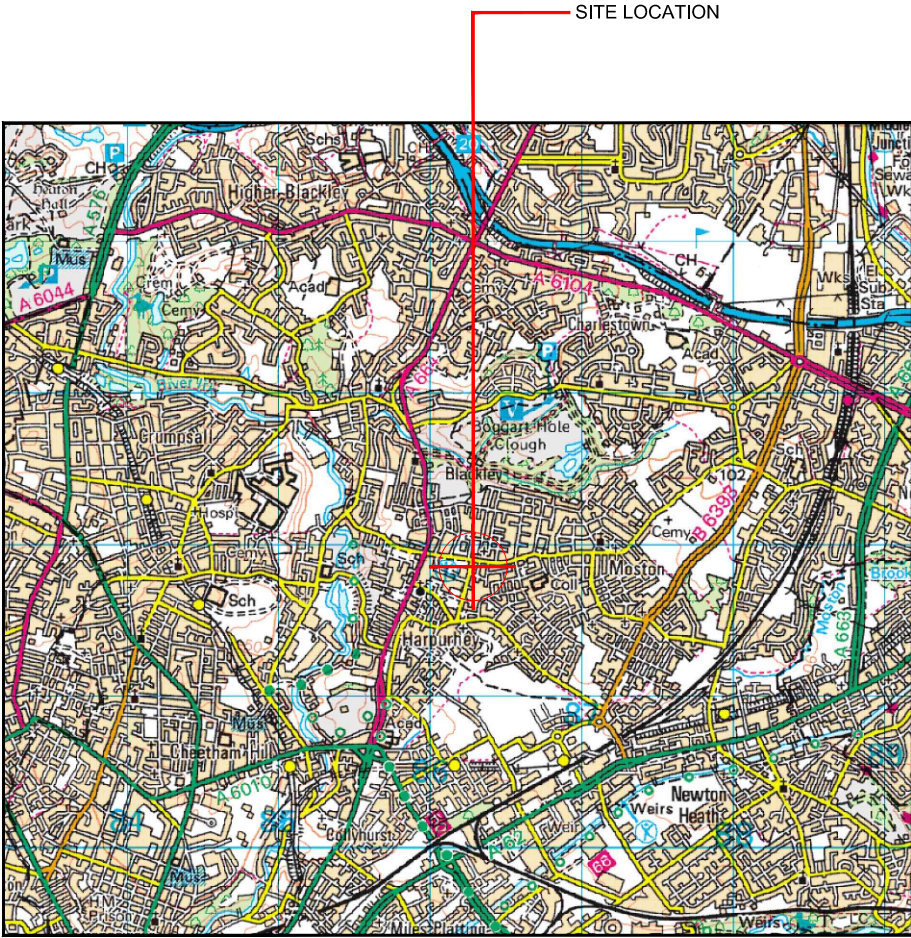


Reproduced by permission of Ordnance Survey on behalf of the Controller of Her Majesty's Stationery Office
All rights reserved. © Crown Copyright licence no. 100022432

SITE AREA PLAN

Scale 1:50000




SITE PHOTOGRAPH

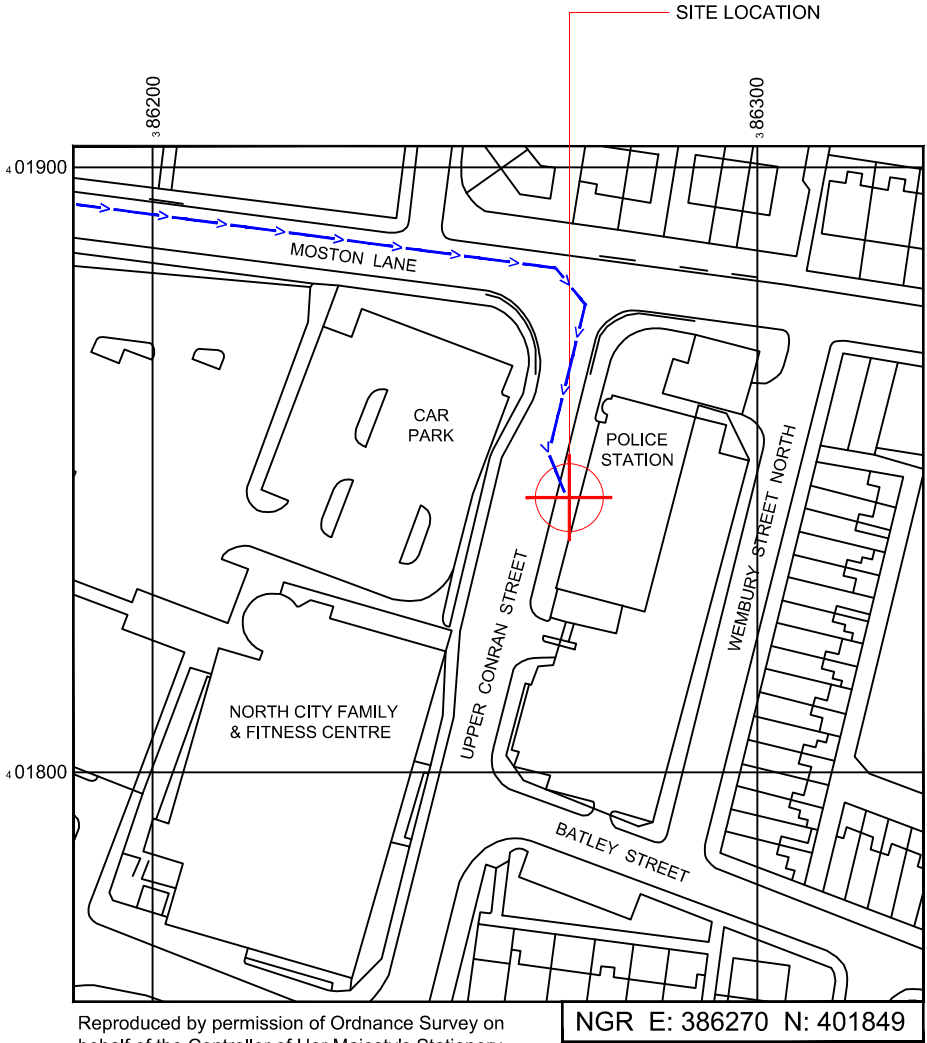

Reproduced by permission of Ordnance Survey on behalf of the Controller of Her Majesty's Stationery Office
All rights reserved. © Crown Copyright licence no. 100022432

SITE LOCATION PLAN

 Scale 1:1250



GOOGLE MAPS QR CODE

GOOGLE MAPS - [Hyperlink to map of the site](#)

GOOGLE STREETVIEW - [Hyperlink to streetview of the site](#)

NOTES:

1. ALL DIMENSIONS IN MM UNLESS OTHERWISE NOTED.

DIRECTIONS TO SITE:
FROM M60 JUNCTION 20 TAKE THE A664 SOUTH TOWARDS HARPURHEY. TURN LEFT AT THE NORTH CITY LIBRARY ONTO MOSTON LANE. TAKE THE SECOND RIGHT ONTO UPPER CONRAN STREET AND THE SITE IS ON THE LEFT HAND SIDE.



Master:	MBNL / EE / H3G:	Project:	Purpose of Issue:	Issue:
M001	MBNL	NTQ	Planning	A
Date:	17/03/2021	Revision / Upgrade Description:		
Drawn:	J.BOOTE	First Issue		
Checked:	J.STOCKDALE			
Approved:	J.STOCKDALE			



Hutchison 3G UK Limited
Star House, 20 Grenfell Road
Macclesfield, SL6 1EH
Tel: 01628 765 000
Fax: 01628 765 001



Hatfield Business Park
Hatfield
Hertfordshire
AL10 9BW
Tel: 01707 315000
Fax: 01707 319001



Mobile Broadband Network Limited
Sixth Floor, Thames Tower, Station Road, Reading, RG1 1LX

Design Consultant & Principal Contractor:

 **WHP Telecoms**
Unit 1 Maple Park,
Low Fields Avenue, Leeds
LS12 6HH
Tel: 01133023550
e-mail: info@whptelecoms.com

Site Name:	UPPER CONRAN STREET SW		
Site ID:	1622474		
Address:	UPPER CONRAN STREET, MANCHESTER, GREATER MANCHESTER, M9 4DA		
Title:	002 SITE LOCATION PLAN		
Project:	NTQ		
Purpose of Issue:	PLANNING		
EE Cell ID:	76341	MBNL Cell ID:	MAN402
3UK Cell ID:	M0797		
Master Drawing No:	1622474_MAN402_76341_M0797_M001		Issue:
			A




100mm

50mm


10mm

Asset Reference	Asset Description:	Asset Status:	Antenna / Dish / MHA / RRU / Equipment Access Description:	Asset Reference	Asset Description:	Asset Status:	Antenna / Dish / MHA / RRU / Equipment Access Description:
CAB1	Cabinet	Proposed	Unrestricted access	A1-A4	Antenna	Proposed	Cherry Picker Access
CAB2	Cabinet	Proposed	Unrestricted access	B1-B4	Antenna	Proposed	Cherry Picker Access
CAB3	Cabinet	Proposed	Unrestricted access	C1-C4	Antenna	Proposed	Cherry Picker Access
CAB4	Cabinet	Proposed	Unrestricted access	TD1	Dish	Proposed	Cherry Picker Access
CAB5	Cabinet	Proposed	Unrestricted access	TD2	Dish	Proposed	Cherry Picker Access
CAB6	Cabinet	Proposed	Unrestricted access				
CAB7	Cabinet	Proposed	Unrestricted access				
CAB8	Cabinet	Proposed	Unrestricted access				

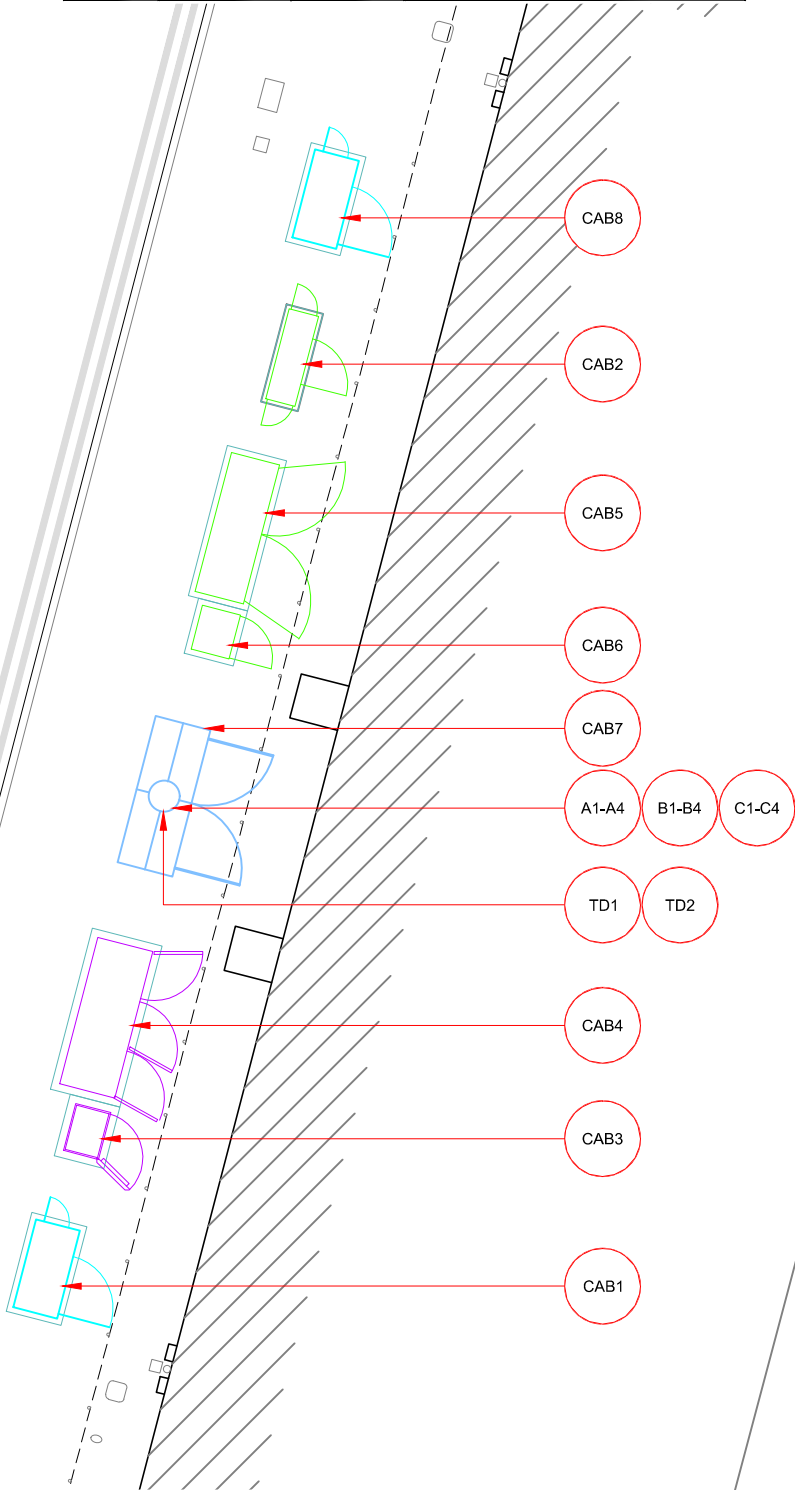

ACCESS PLAN

 Scale 1:100



NOTES:

1. ALL DIMENSIONS IN MM UNLESS OTHERWISE NOTED.

DEFINED ACCESS ROUTE DESCRIPTION FROM SITE ENTRANCE TO THE EQUIPMENT: N/A

Master:	MBNL / EE / H3G:	Project:	Purpose of Issue:	Issue:
M001	MBNL	NTQ	Planning	A
Date:	17/03/2021	Revision / Upgrade Description:		
Drawn:	J.BOOTE	First Issue		
Checked:	J.STOCKDALE			
Approved:	J.STOCKDALE			



Hutchison 3G UK Limited
Star House, 20 Grenfell Road
Mordenhead, SLS 1EH
Tel: 01628 765 000
Fax: 01628 765 001

H3G Base Station Information line:
0845 6043000
Available 9am-6pm Monday to Friday



Hatfield Business Park
Hatfield
Hertfordshire
AL10 9BW

Tel: 01707 315000
Fax: 01707 319001



Mobile Broadband Network Limited
Sixth Floor, Thames Tower, Station Road, Reading, RG1 1LX


Design Consultant & Principal Contractor:



WHP Telecoms
Unit 1 Maple Park,
Low Fields Avenue, Leeds
LS12 6HH

Tel: 01133023550
e-mail: info@whptelecoms.com

Site Name:		
UPPER CONRAN STREET SW		
Site ID:		
1622474		
Address:		
UPPER CONRAN STREET, MANCHESTER, GREATER MANCHESTER, M9 4DA		
Title:		
003 ACCESS PLAN		
Project:		
NTQ		
Purpose of Issue:		
PLANNING		
EE Cell ID:	MBNL Cell ID:	3UK Cell ID:
76341	MAN402	M0797
Master Drawing No:		Issue:
1622474_MAN402_76341_M0797_M001		A

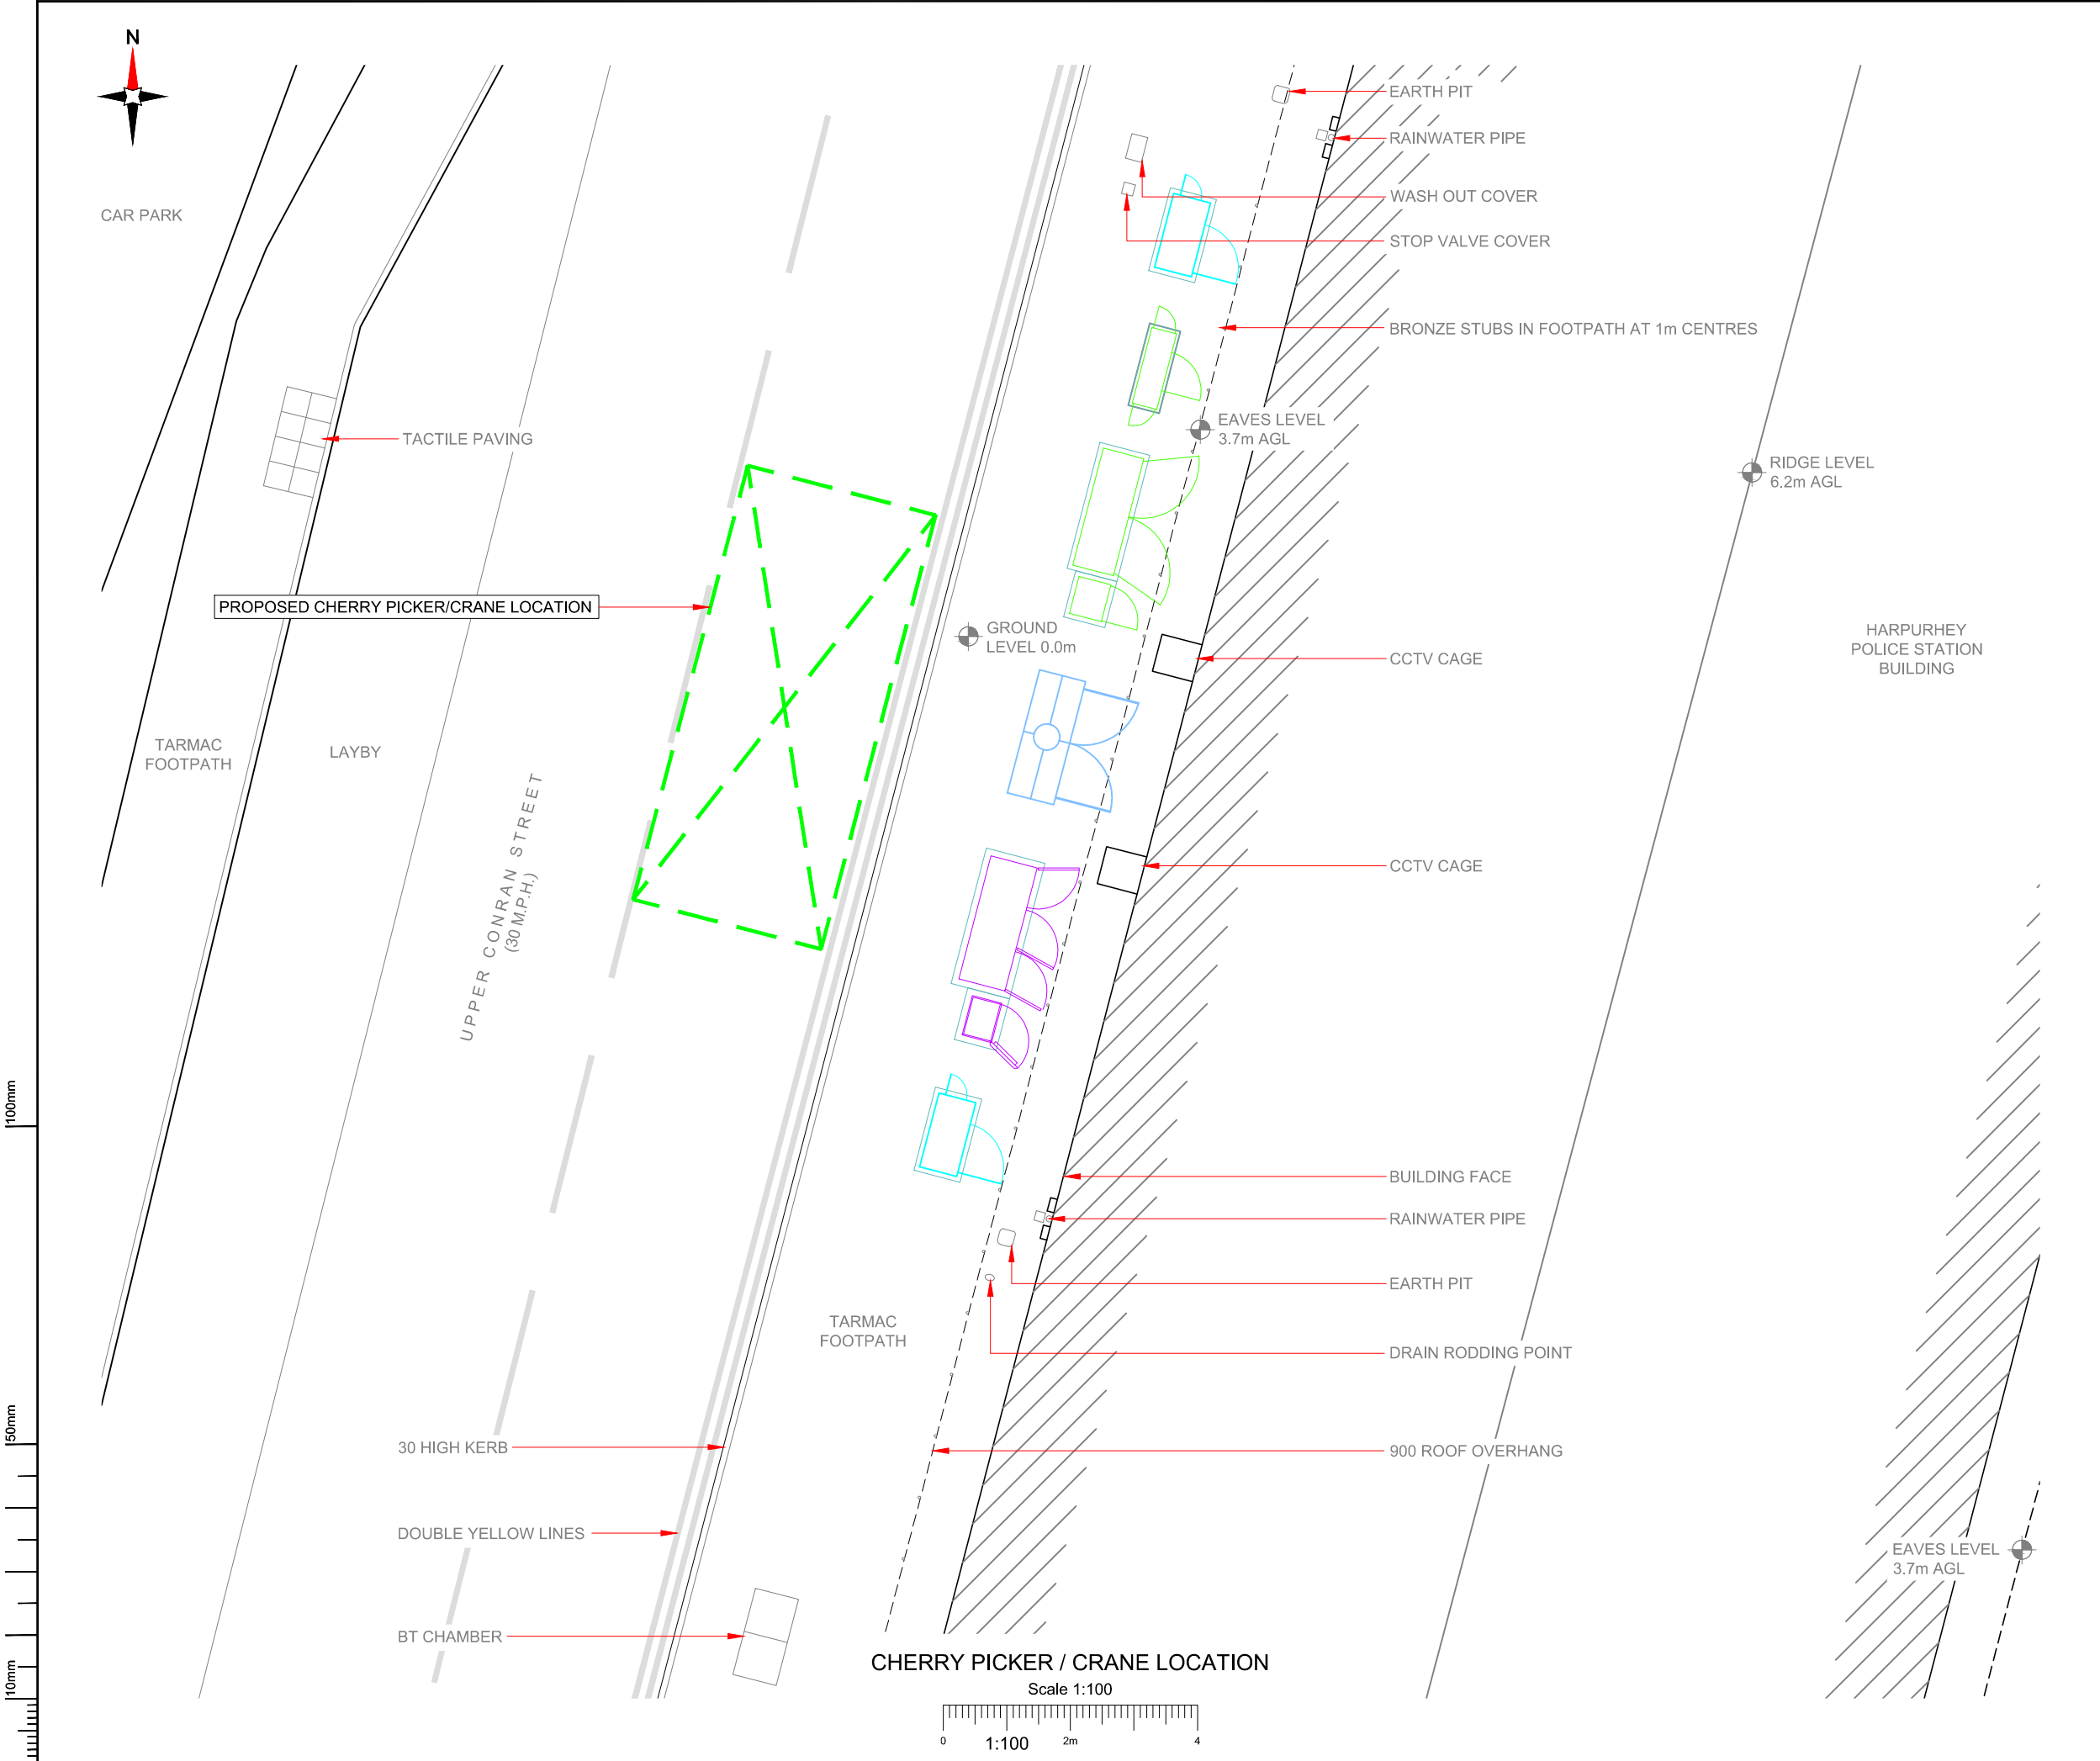

NOTES:

1. ALL DIMENSIONS IN MM UNLESS OTHERWISE NOTED.

PROPOSED CRANE OR CHERRY PICKER LOCATION:

Master:	MBNL / EE / H3G:	Project:	Purpose of Issue:	Issue:
M001	MBNL	NTQ	Planning	A
Date:	17/03/2021	Revision / Upgrade Description:		
Drawn:	J.BOOTE	First Issue		
Checked:	J.STOCKDALE			
Approved:	J.STOCKDALE			

Hutchison 3G UK Limited
Star House, 20 Grenfell Road
Mordenhead, SL8 1EH
Tel: 01628 765 000
Fax: 01628 765 001

H3G Base Station Information line:
0845 6043000
Available 9am-5pm Monday to Friday

Hatfield Business Park
Hatfield
Hertfordshire
AL10 9BW

Tel: 01707 315000
Fax: 01707 319001

Mobile Broadband Network Limited
Sixth Floor, Thames Tower, Station Road, Reading, RG1 1LX

Design Consultant & Principal Contractor:

WHP

WHP Telecoms
Unit 1 Maple Park,
Low Fields Avenue, Leeds
LS12 6HH

Tel: 01133023550
e-mail: info@whptelecoms.com

Site Name:

UPPER CONRAN STREET SW

Site ID:

1622474

Address:

UPPER CONRAN STREET,
MANCHESTER,
GREATER MANCHESTER,
M9 4DA

Title:

005 CHERRY PICKER & CRANE LOCATION

Project:

NTQ

Purpose of Issue:

PLANNING


EE Cell ID:	MBNL Cell ID:	3UK Cell ID:
76341	MAN402	M0797

Master Drawing No:

1622474_MAN402_76341_M0797_M001

Issue:

A

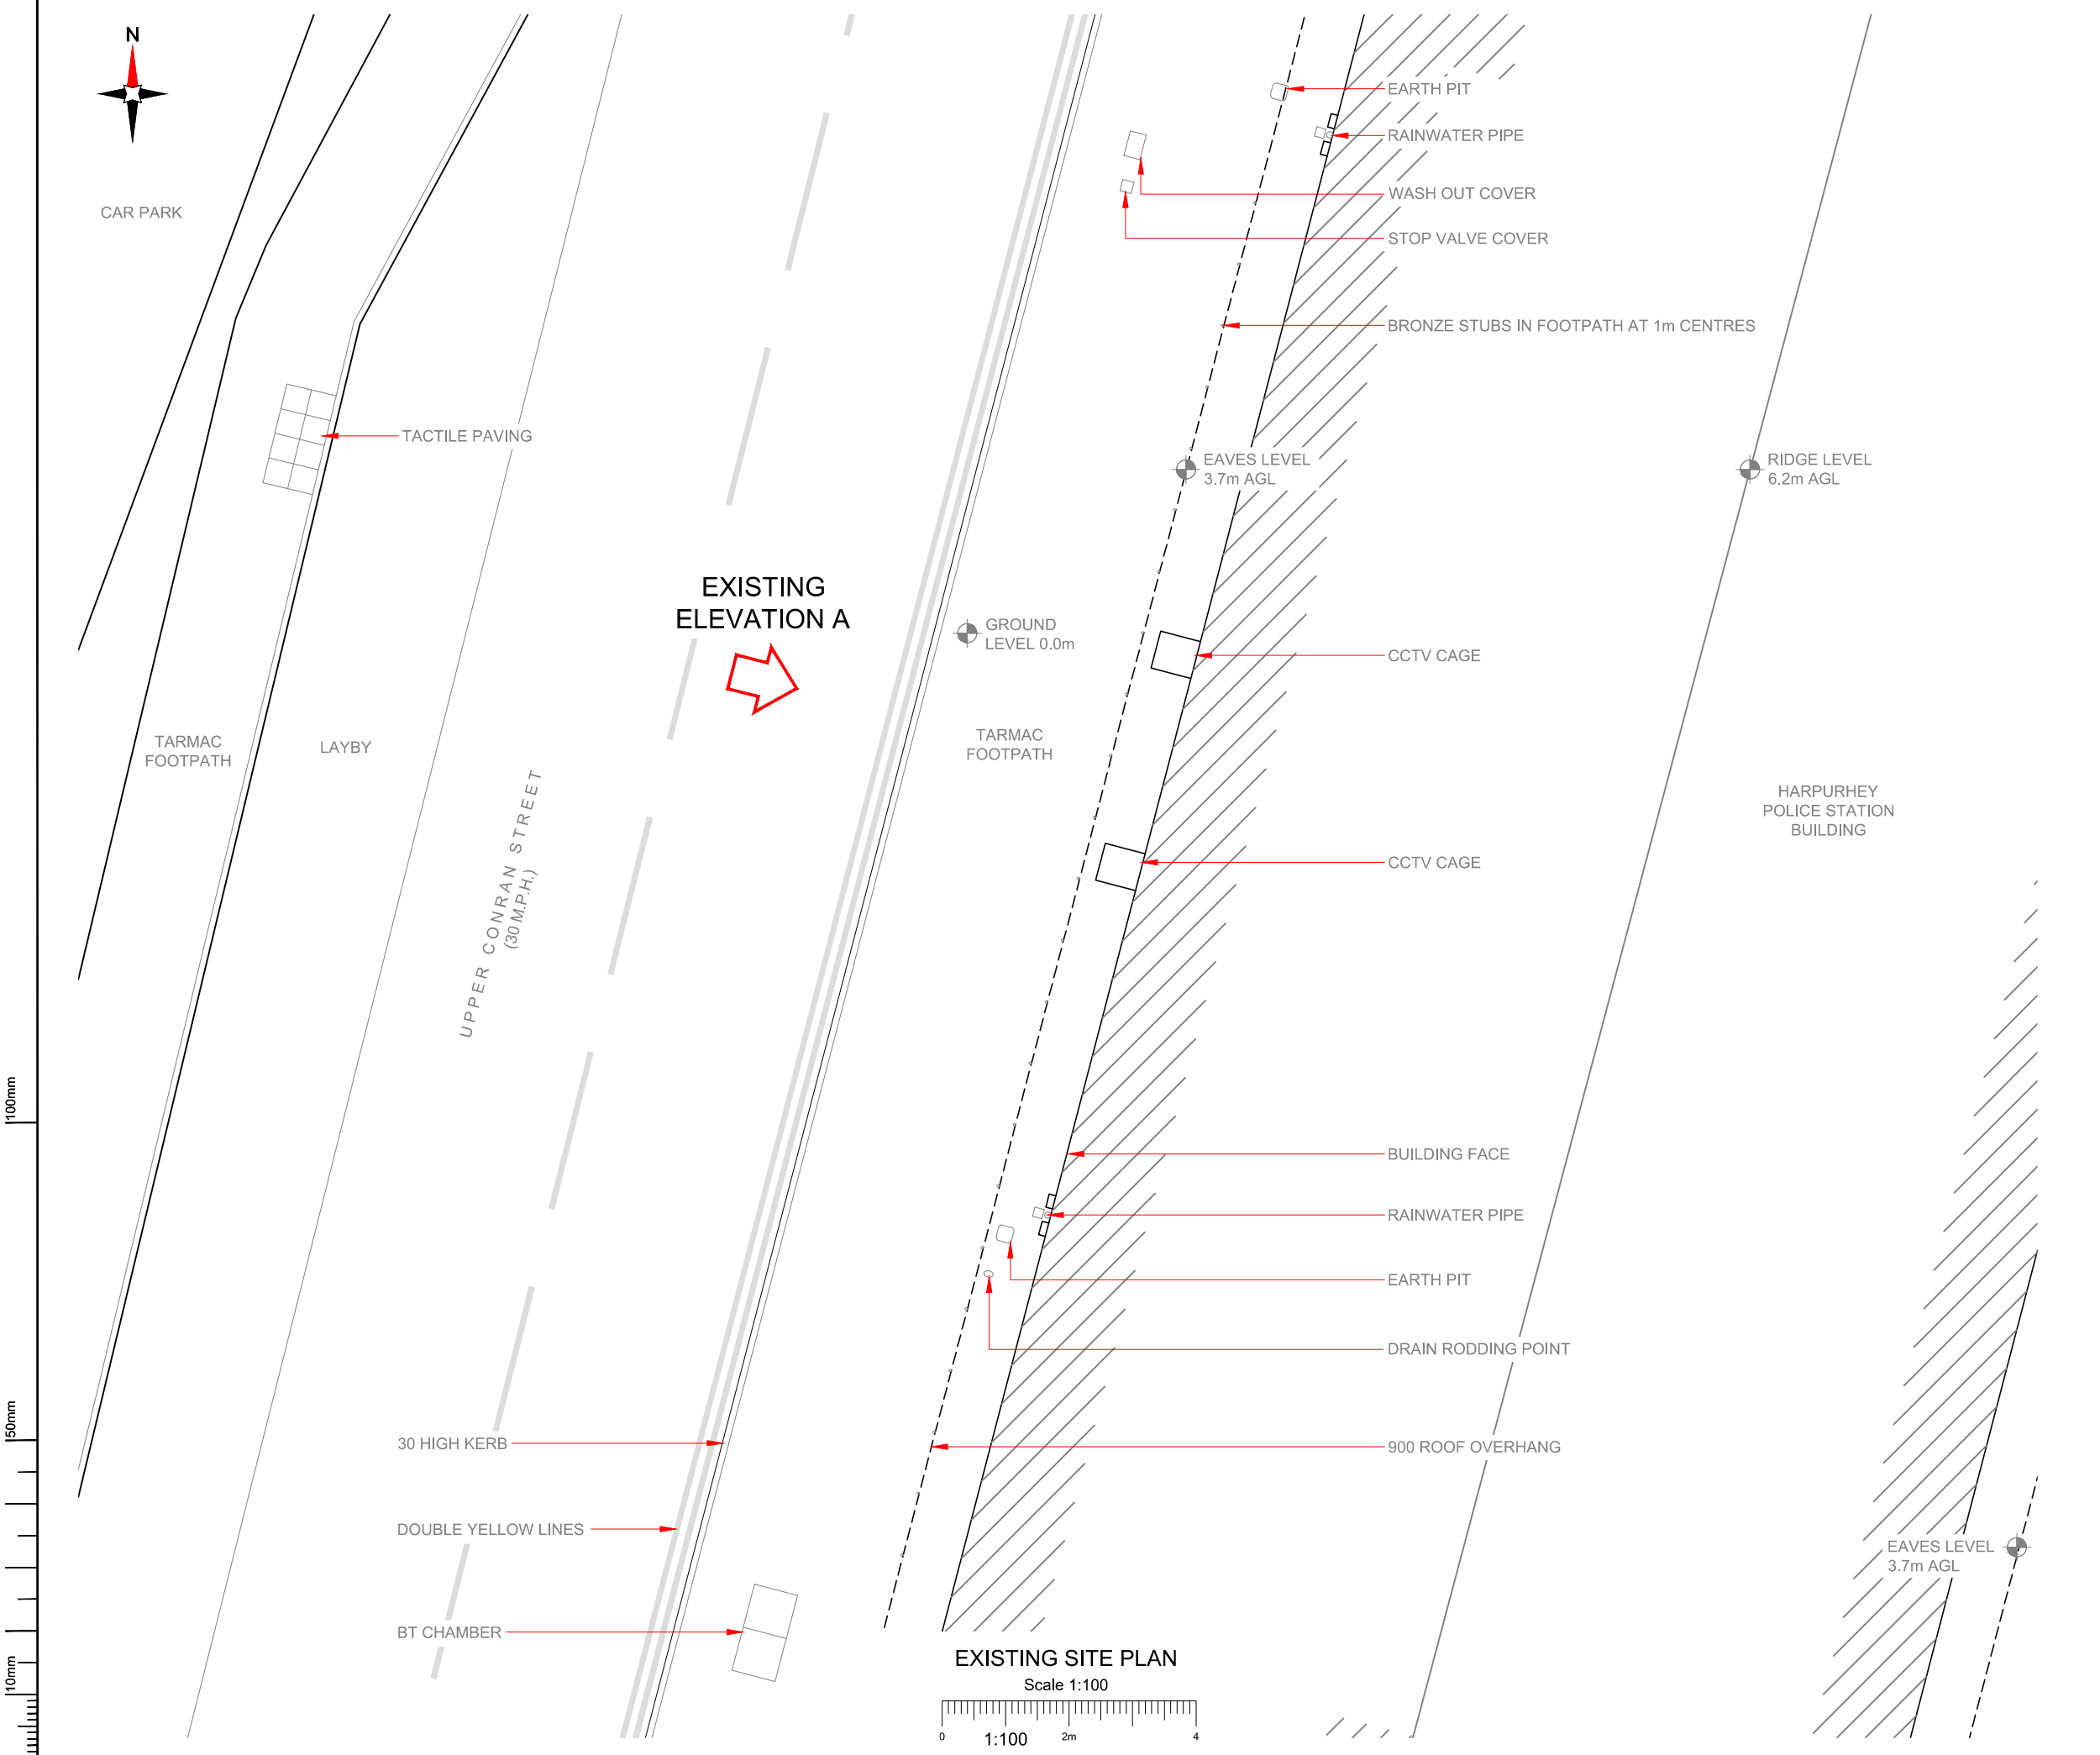

NOTES:

1. ALL DIMENSIONS IN MM UNLESS OTHERWISE NOTED.

Master:	MBNL / EE / H3G:	Project:	Purpose of Issue:	Issue:
M001	MBNL	NTQ	Planning	A
Date:	17/03/2021	Revision / Upgrade Description:		
Drawn:	J.BOOTE	First Issue		
Checked:	J.STOCKDALE			
Approved:	J.STOCKDALE			

Hutchison 3G UK Limited
Star House, 20 Grenfell Road
Mordenhead, SL6 1EH
Tel: 01628 765 000
Fax: 01628 765 001

H3G Base Station Information line:
0845 6043000
Available 9am-6pm Monday to Friday

Hatfield Business Park
Hatfield
Hertfordshire
AL10 9BW

Tel: 01707 315000
Fax: 01707 319001

Mobile Broadband Network Limited
Sixth Floor, Thames Tower, Station Road, Reading, RG1 1LX

Design Consultant & Principal Contractor:

WHP

WHP Telecoms
Unit 1 Maple Park,
Low Fields Avenue, Leeds
LS12 6HH

Tel: 01133023550
e-mail: info@whptelecoms.com

Site Name:

UPPER CONRAN STREET SW

Site ID:

1622474

Address:

UPPER CONRAN STREET,
MANCHESTER,
GREATER MANCHESTER,
M9 4DA

Title:

100 EXISTING SITE PLAN

Project:

NTQ

Purpose of Issue:

PLANNING



EE Cell ID:	MBNL Cell ID:	3UK Cell ID:
76341	MAN402	M0797

Master Drawing No:	Issue:
1622474_MAN402_76341_M0797_M001	A

100mm

50mm

10mm

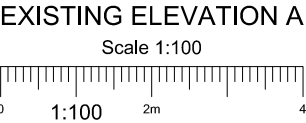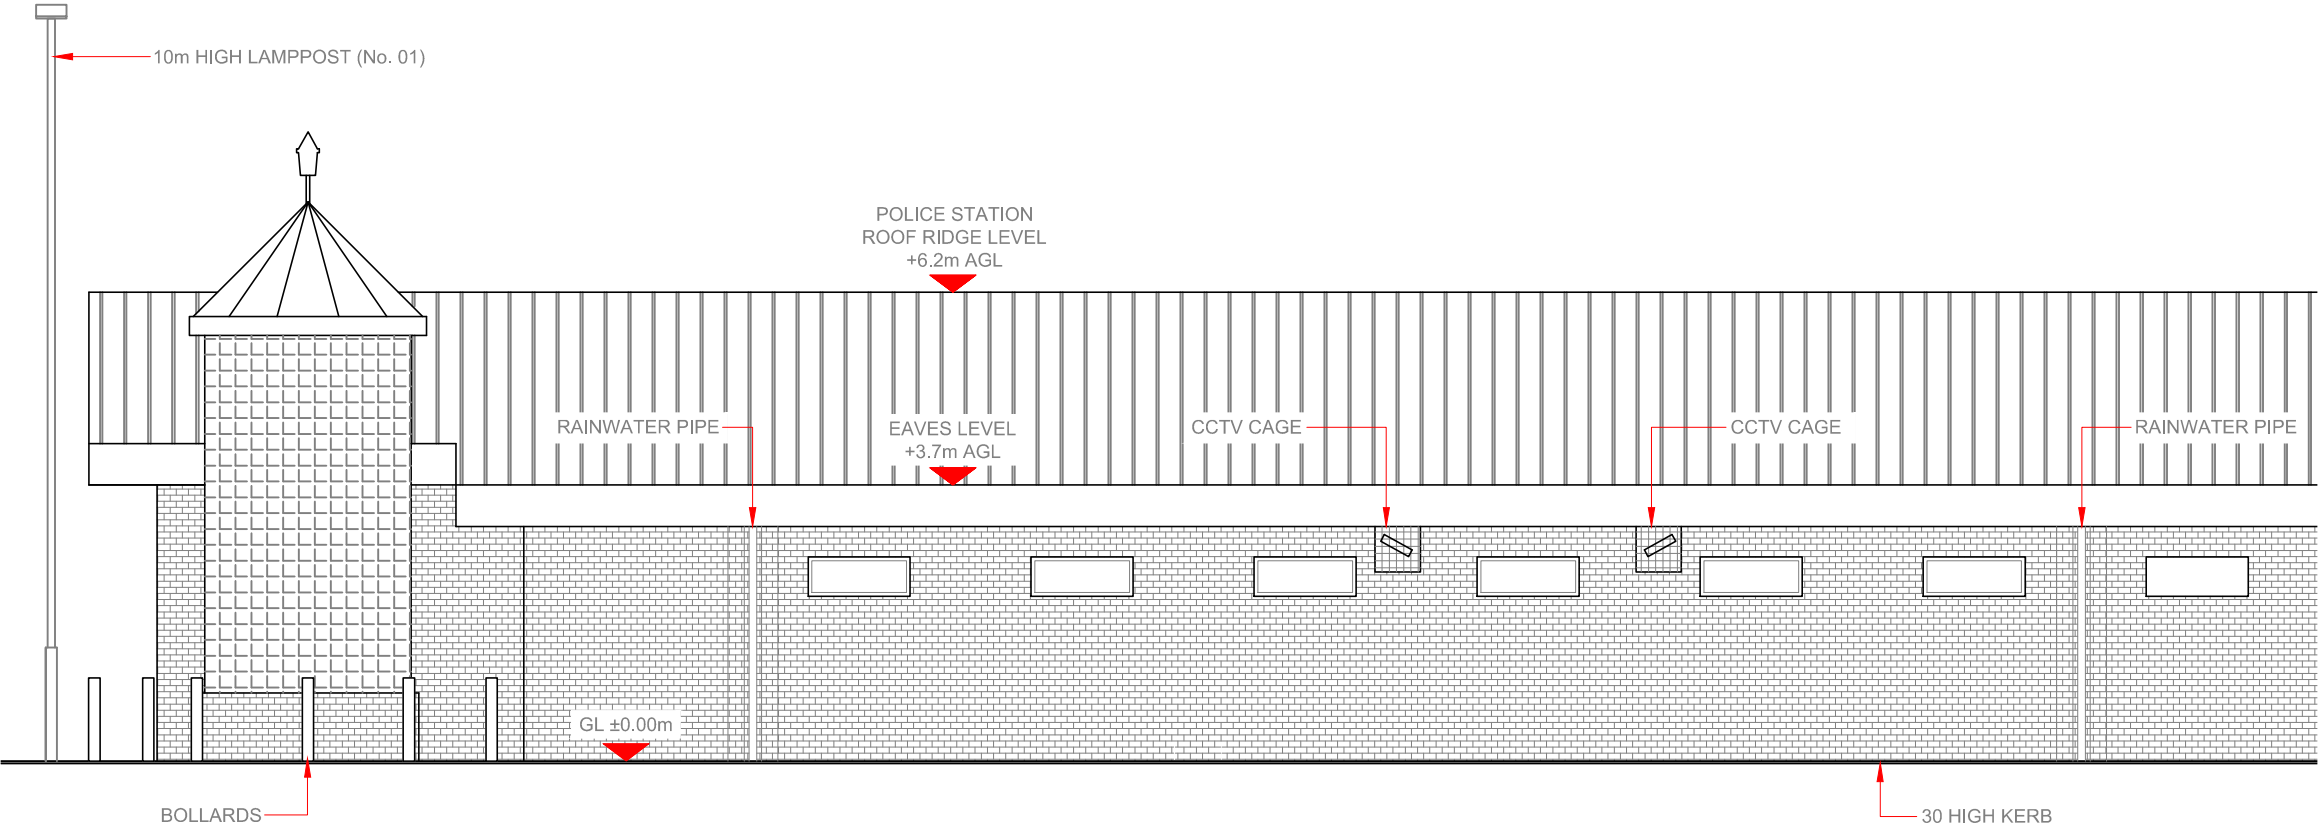

- NOTES:
- ALL DIMENSIONS IN MM UNLESS OTHERWISE NOTED.

Master:	MBNL / EE / H3G:	Project:	NTQ	Purpose of Issue:	Issue:
M001	MBNL			Planning	A
Date:	17/03/2021	Revision / Upgrade Description:			
Drawn:	J.BOOOTE	First Issue			
Checked:	J.STOCKDALE				
Approved:	J.STOCKDALE				



Hutchison 3G UK Limited
Star House, 20 Grenfell Road
Maidenhead, SL6 1EH
Tel: 01628 765 000
Fax: 01628 765 001

H3G Base Station Information line:
0845 6043000
Available 9am-6pm Monday to Friday



Hatfield Business Park
Hatfield
Hertfordshire
AL10 9BW

Tel: 01707 315000
Fax: 01707 319001



Mobile Broadband Network Limited
Sixth Floor, Thames Tower, Station Road, Reading, RG1 1LX

Design Consultant & Principal Contractor:



WHP Telecoms
Unit 1 Maple Park,
Low Fields Avenue, Leeds
LS12 6HH

Tel: 01133023550
e-mail: info@whptelecoms.com

Site Name:
UPPER CONRAN STREET SW

Site ID:
1622474


Address:
UPPER CONRAN STREET,
MANCHESTER,
GREATER MANCHESTER,
M9 4DA

Title:
150 EXISTING ELEVATION A

Project:
NTQ

Purpose of Issue:
PLANNING

EE Cell ID:	MBNL Cell ID:	3UK Cell ID:
76341	MAN402	M0797
Master Drawing No: 1622474_MAN402_76341_M0797_M001		
Issue: A		

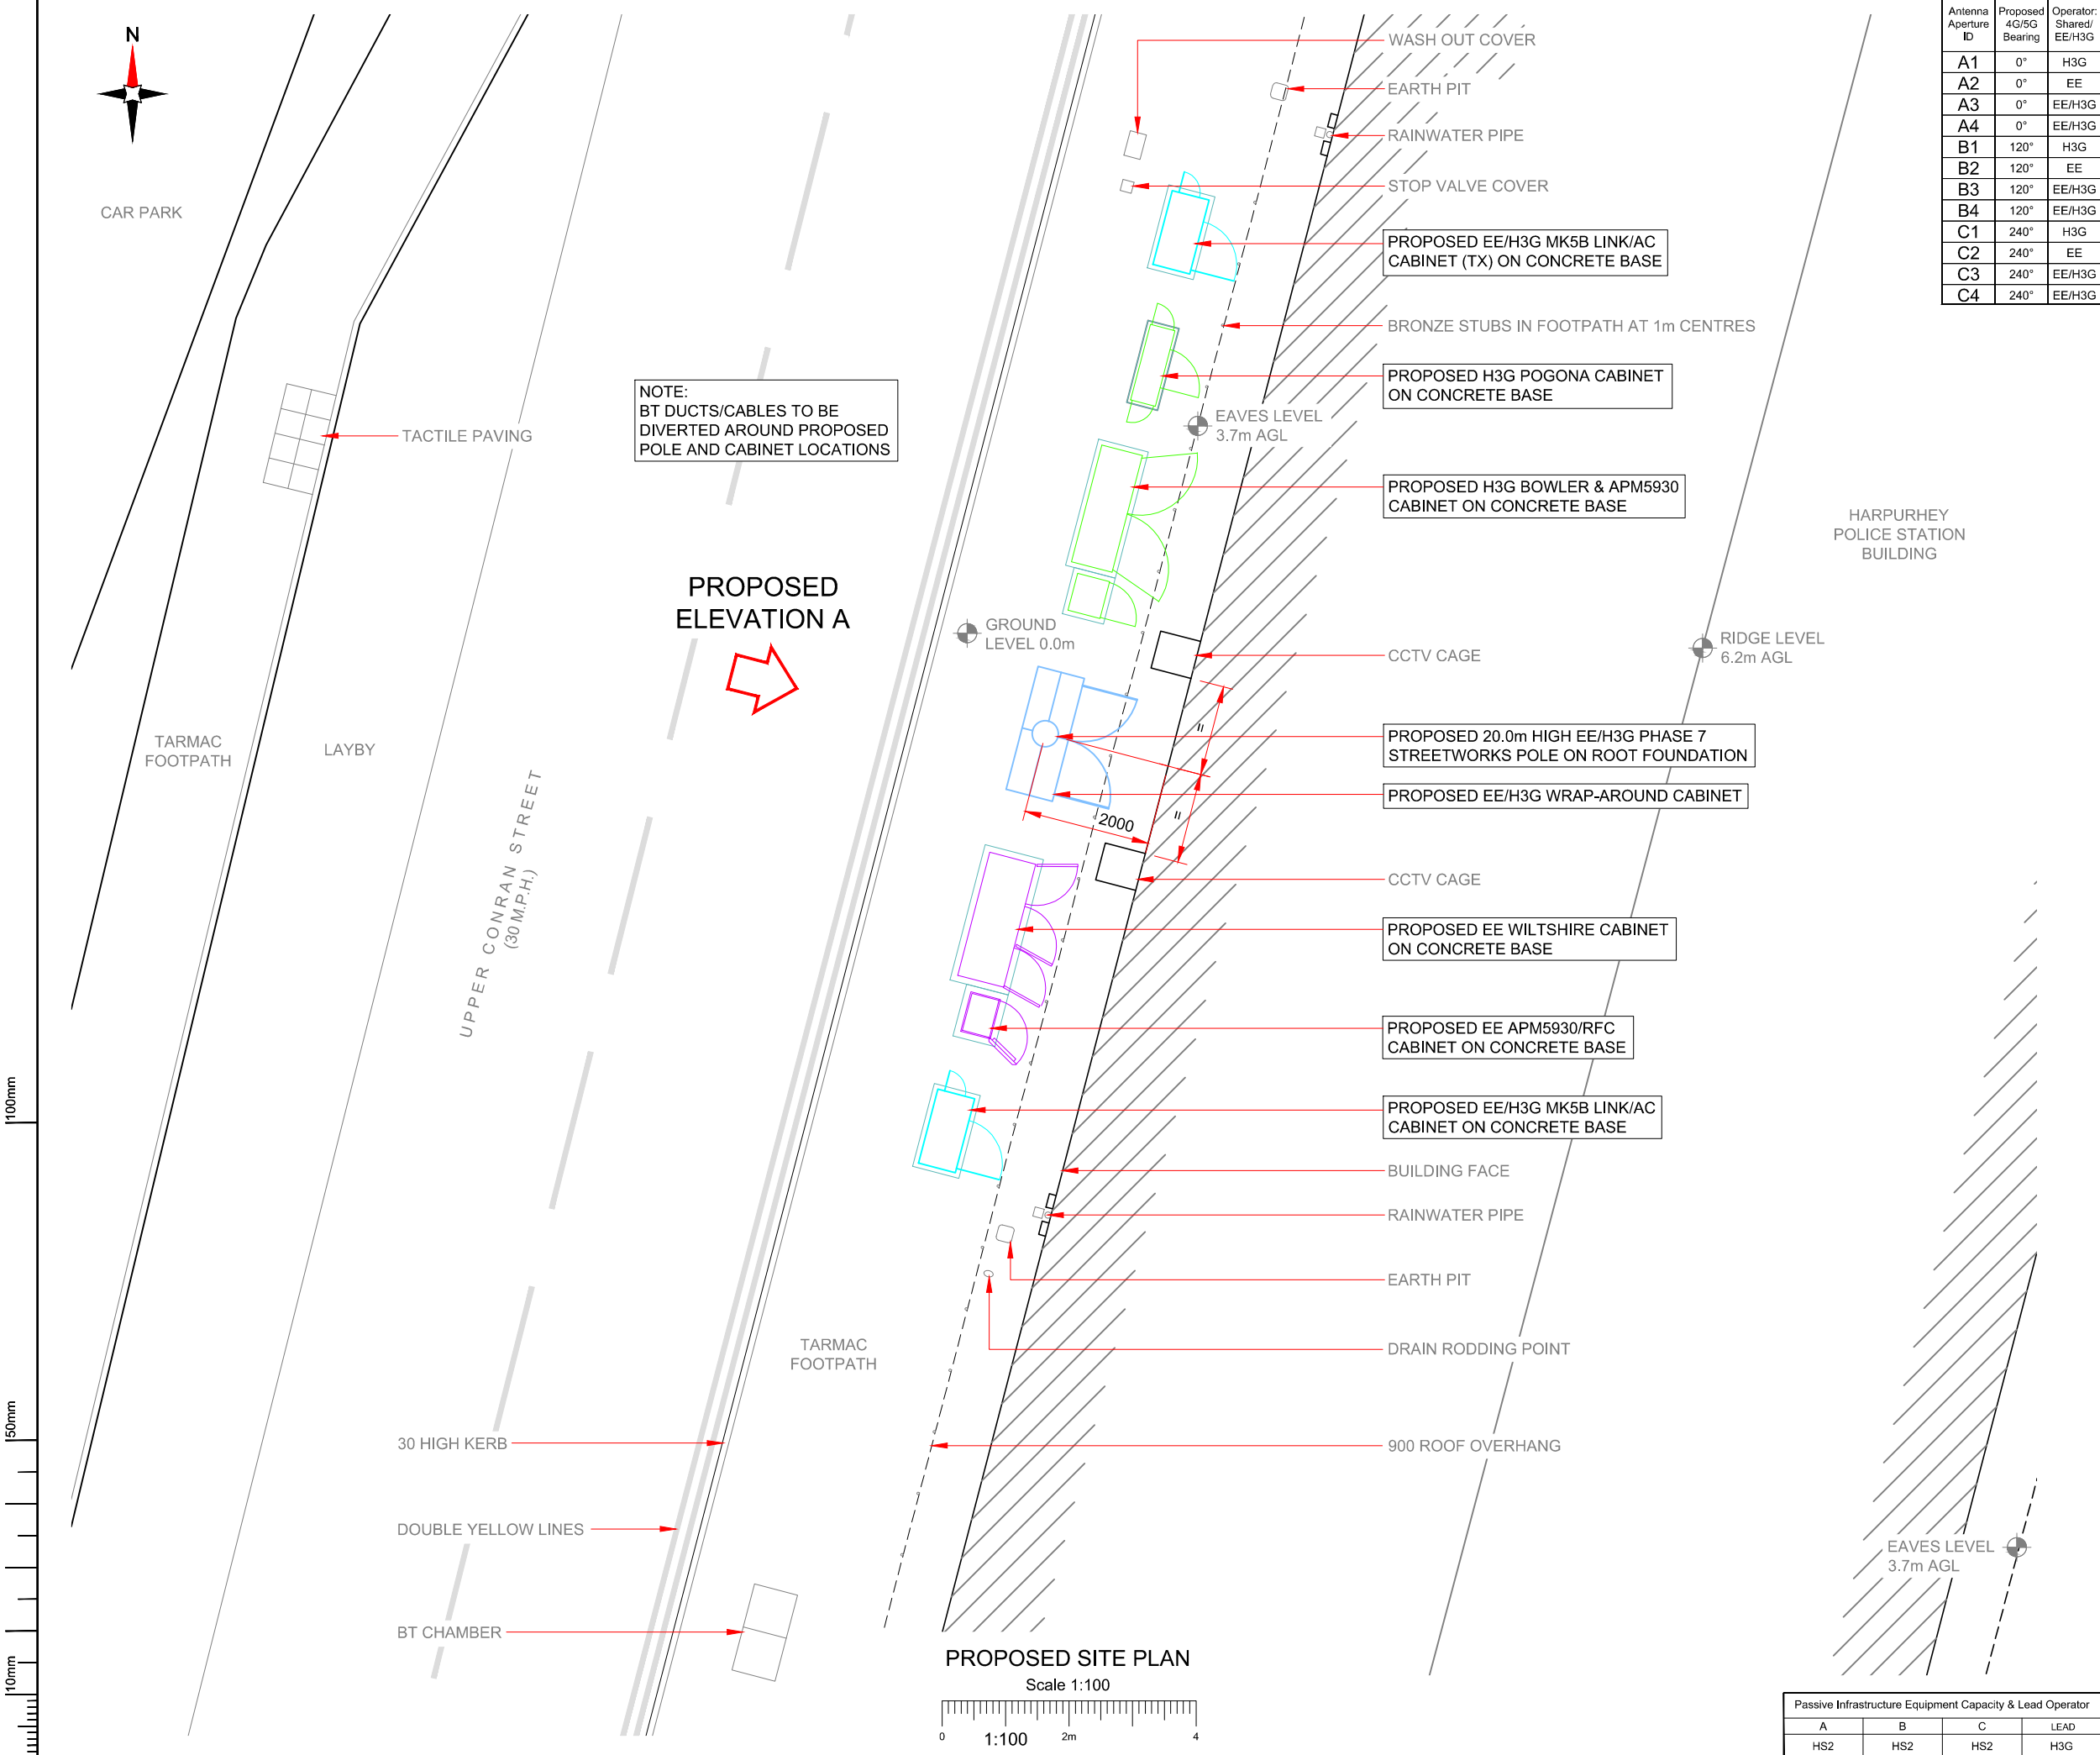

Antenna Aperture ID	Proposed 4G/5G Bearing	Operator: Shared/ EE/H3G
A1	0°	H3G
A2	0°	EE
A3	0°	EE/H3G
A4	0°	EE/H3G
B1	120°	H3G
B2	120°	EE
B3	120°	EE/H3G
B4	120°	EE/H3G
C1	240°	H3G
C2	240°	EE
C3	240°	EE/H3G
C4	240°	EE/H3G

NOTES:

1. ALL DIMENSIONS IN MM UNLESS OTHERWISE NOTED.

Master:	MBNL / EE / H3G:	Project:	Purpose of Issue:	Issue:
M001	MBNL	NTQ	Planning	A
Date:	17/03/2021	Revision / Upgrade Description:		
Drawn:	J.BOOTE	First Issue		
Checked:	J.STOCKDALE			
Approved:	J.STOCKDALE			



Hutchison 3G UK Limited
Star House, 20 Grenfell Road
Maidenhead, SL6 1EH
Tel: 01628 765 500
Fax: 01628 765 501



Hatfield Business Park
Hatfield
Hertfordshire
AL10 9BW
Tel: 01707 315000
Fax: 01707 319001



Mobile Broadband Network Limited
Sixth Floor, Thames Tower, Station Road, Reading, RG1 1LX

Design Consultant & Principal Contractor:



WHP Telecoms
Unit 1 Maple Park,
Low Fields Avenue, Leeds
LS12 6HH
Tel: 01133023550
e-mail: info@whptelecoms.com

Site Name:

UPPER CONRAN STREET SW

Site ID:

1622474

Address:

UPPER CONRAN STREET,
MANCHESTER,
GREATER MANCHESTER,
M9 4DA

Title:

215 PROPOSED SITE PLAN

Project:

NTQ


Purpose of Issue:

PLANNING

EE Cell ID:	MBNL Cell ID:	3UK Cell ID:
76341	MAN402	M0797

Master Drawing No:	Issue:
1622474_MAN402_76341_M0797_M001	A

Passive Infrastructure Equipment Capacity & Lead Operator			
A	B	C	LEAD
HS2	HS2	HS2	H3G

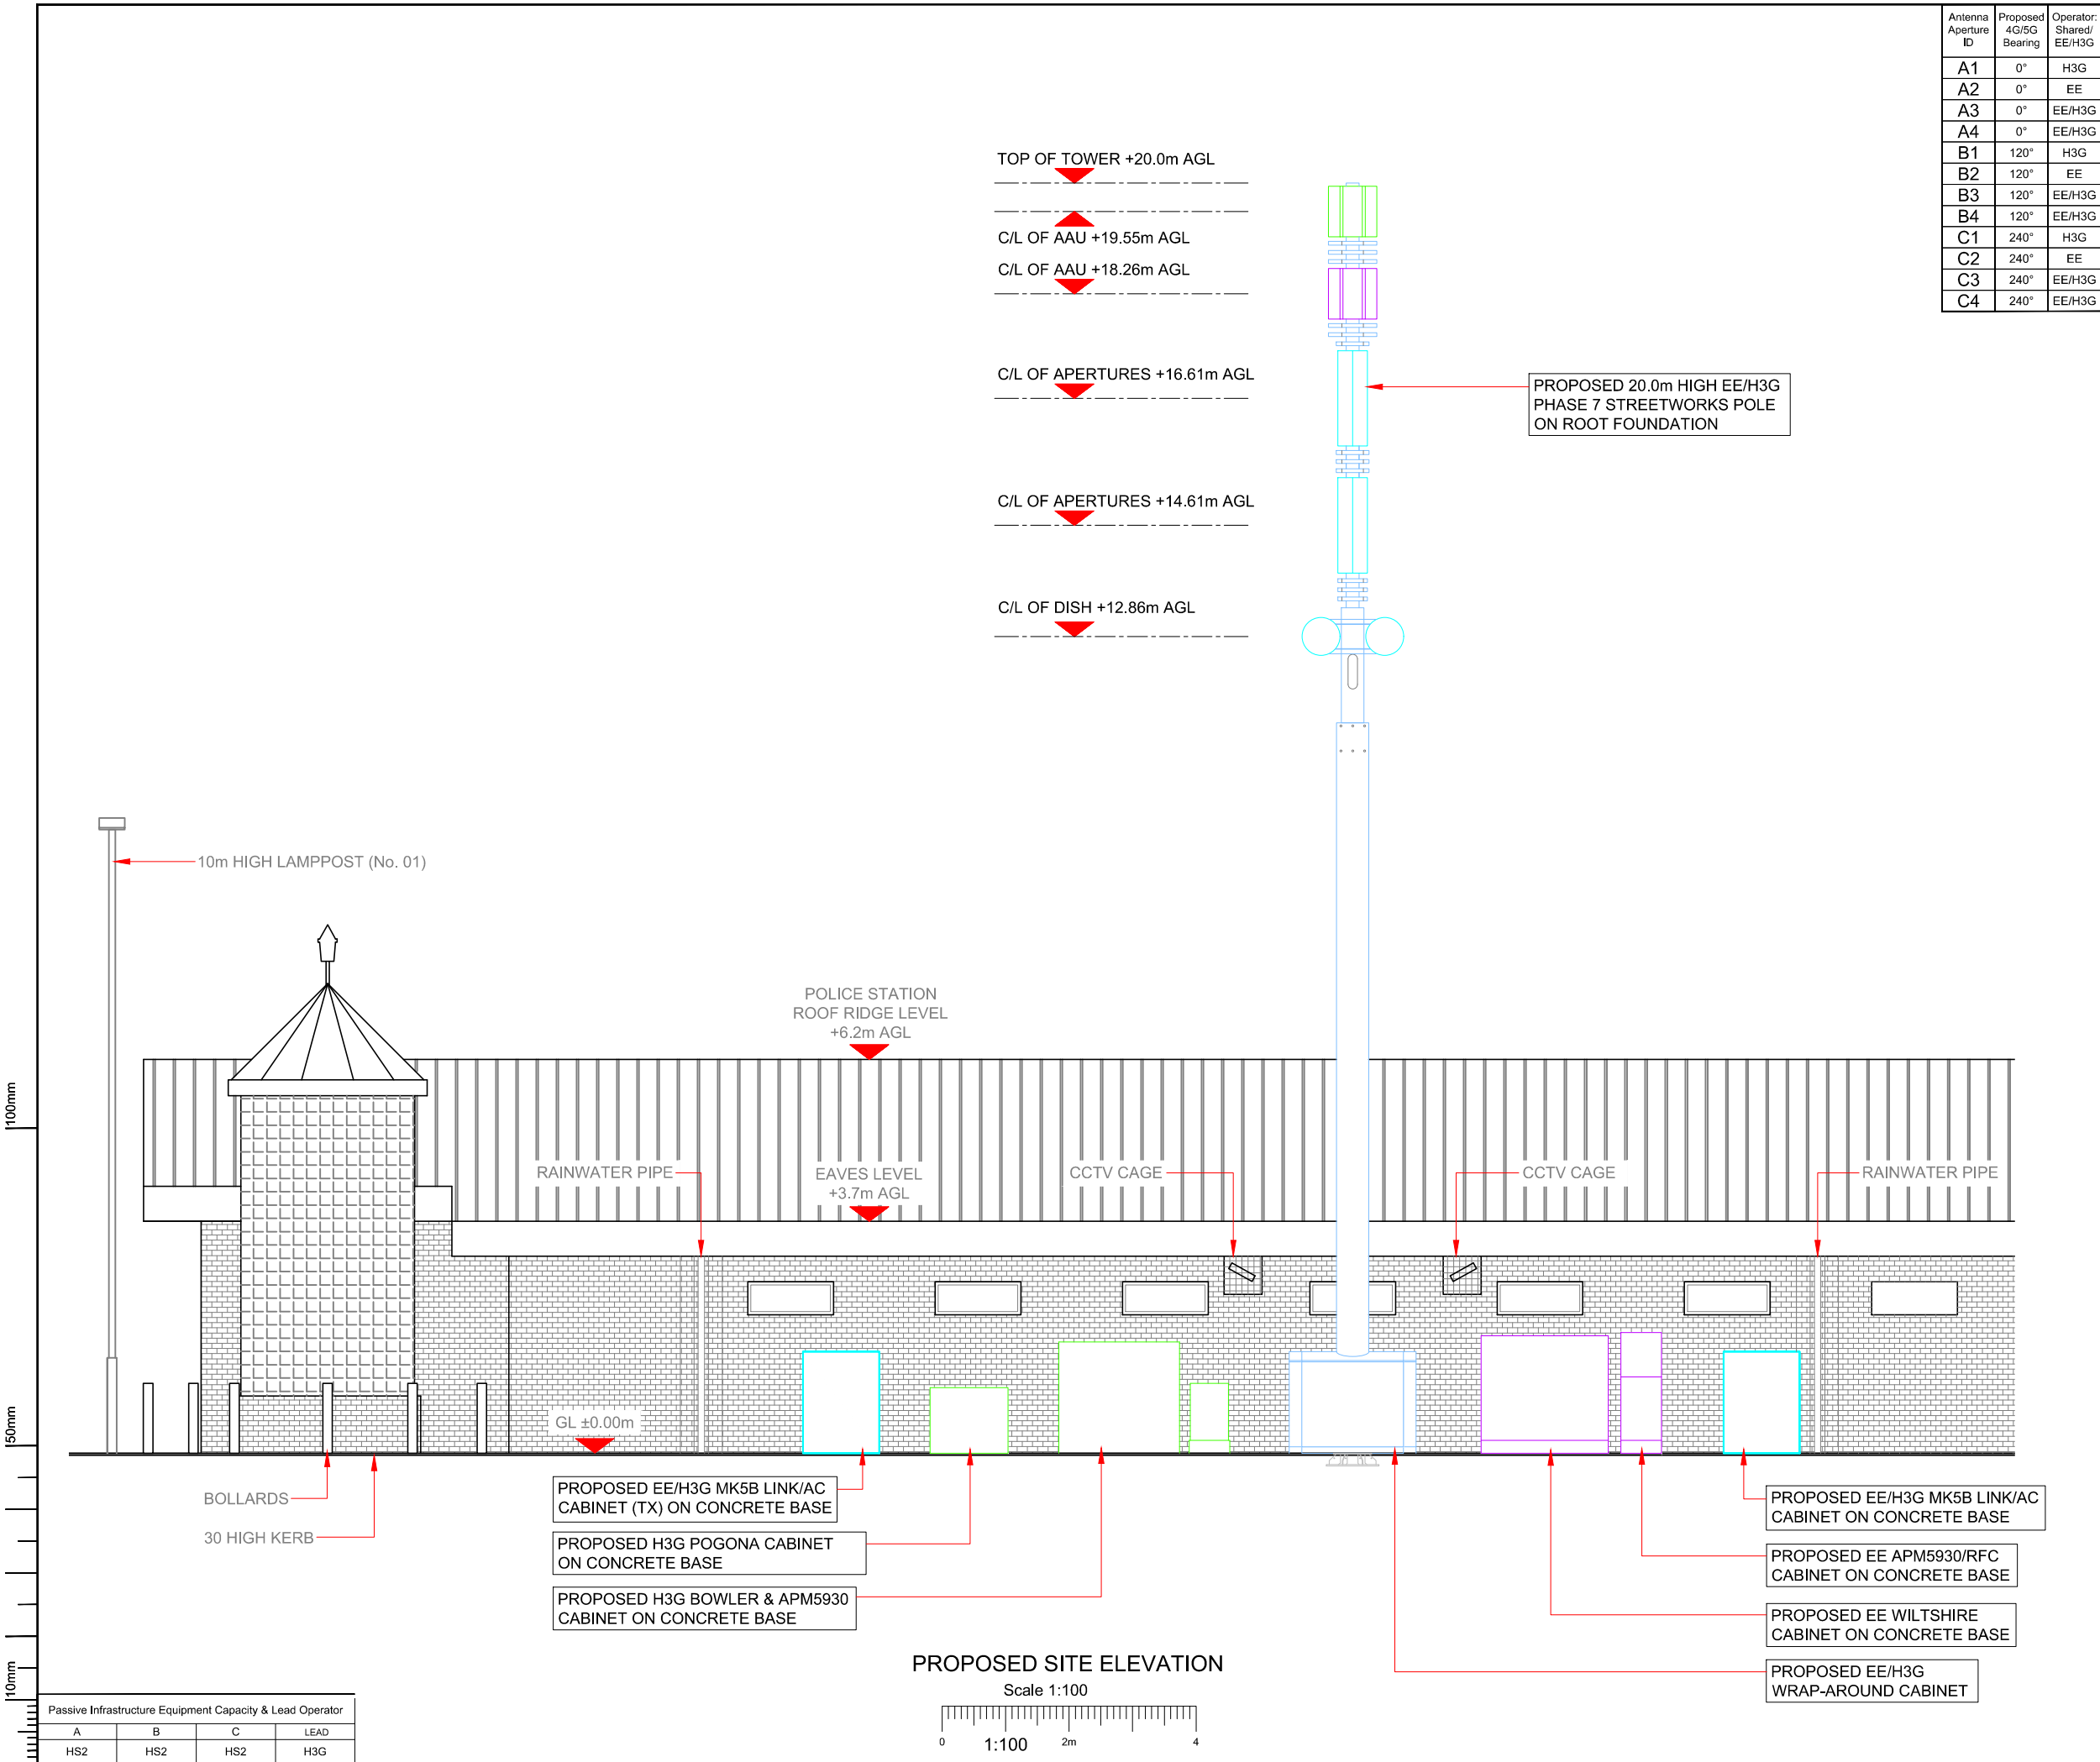

Antenna Aperture ID	Proposed 4G/5G Bearing	Operator: Shared/ EE/H3G
A1	0°	H3G
A2	0°	EE
A3	0°	EE/H3G
A4	0°	EE/H3G
B1	120°	H3G
B2	120°	EE
B3	120°	EE/H3G
B4	120°	EE/H3G
C1	240°	H3G
C2	240°	EE
C3	240°	EE/H3G
C4	240°	EE/H3G

NOTES:

1. ALL DIMENSIONS IN MM UNLESS OTHERWISE NOTED.

Master: M001	MBNL / EE / H3G	Project: NTQ	Purpose of Issue: Planning	Issue: A
Date: 17/03/2021	Drawn: J.BOOOTE	Revision / Upgrade Description: First Issue		
Checked: J.STOCKDALE	Approved: J.STOCKDALE			



Hutchison 3G UK Limited
Star House, 20 Grenfell Road
Macclesfield, SK10 1EH
Tel: 01628 765 000
Fax: 01628 765 001



Hatfield Business Park
Hatfield
Hertfordshire
AL10 9BW
Tel: 01707 315000
Fax: 01707 319001



Mobile Broadband Network Limited
Sixth Floor, Thames Tower, Station Road, Reading, RG1 1LX

Design Consultant & Principal Contractor:



WHP Telecoms
Unit 1 Maple Park,
Low Fields Avenue, Leeds
LS12 6HH

Tel: 01133023550
e-mail: info@whptelecoms.com

Site Name:
UPPER CONRAN STREET SW

Site ID:
1622474

Address:
UPPER CONRAN STREET,
MANCHESTER,
GREATER MANCHESTER,
M9 4DA

Title:
265 PROPOSED SITE ELEVATION

Project:
NTQ

Purpose of Issue:
PLANNING

EE Cell ID: 76341	MBNL Cell ID: MAN402	3UK Cell ID: M0797
----------------------	-------------------------	-----------------------

Master Drawing No: 1622474_MAN402_76341_M0797_M001	Issue: A
---	-------------

三

三

v1.8

Support Structure Schedule													
Structure ID	Status	Equipment Description / Type	Structure Manufacturer	Height AGL (m)	Colour (RAL Colour)	Headframe Details	Foundation / Support Grillage / Host Structure Details	Support Bolt Details	MBNL Ref:	Comments			
ST1	PROPOSED	PHASE 7 POLE	-	20.00m	GOOSE GREY BS4800 00A05	-	ROOT	-	-				
Equipment Schedule													
Equipment ID	Quantity	Status	Equipment Description / Type	Equipment Manufacturer	Dimensions (W x D x H)	Weight (kg)	Colour (RAL Colour)	Material	Location	Power	Power cable length (m)	MBNL Ref:	Comments
CAB1	1	PROPOSED	MK5B LINK AC	-	1200x600x1600	-	GREY	STEEL	OUTDOOR	-	-	-	
CAB2	1	PROPOSED	H3G - POGONA	COMMScope	1230x402x1033	-	GREY	STEEL	OUTDOOR	-	-	-	
CAB3	1	PROPOSED	EE - APM5930 & RFC	HUAWEI	600x480x1700	-	GREY	STEEL	OUTDOOR	-	-	-	ON 200 HIGH PLINTH
CAB4	1	PROPOSED	EE - WILTSHIRE	-	2000x755x1650	-	GREY	STEEL	OUTDOOR	-	-	-	ON 200 HIGH PLINTH
CAB5	1	PROPOSED	H3G - BOWLER	COMMScope	1900x600x1752	-	GREY	STEEL	OUTDOOR	-	-	-	
CAB6	1	PROPOSED	H3G - APM5930	HUAWEI	600x480x1000	-	GREY	STEEL	OUTDOOR	-	-	-	ON 200 HIGH PLINTH
CAB7	1	PROPOSED	WRAPAROUND	-	2000x750x1600	-	GREY	STEEL	OUTDOOR	-	-	-	
CAB8	1	PROPOSED	MK5B LINK AC	-	1200x600x1600	-	GREY	STEEL	OUTDOOR	-	-	-	TX LOCATION
Power Schedule													
Supply Status		Type	Supplier	Supply Type	Location	Comments							
PROPOSED		DNO	-	3 PHASE 80A	MK5B LINK/AC CABINET	-							

NOTES:

1. ALL DIMENSIONS IN MM UNLESS OTHERWISE NOTED.

Master: M001

Date: 17/03/2021

Drawn: J.BOOTE

Checked: J.STOCKDALE

Approved: J.STOCKDALE

MBNL / EE / H3G: MBNL

Revision / Upgrade Description: First Issue

Project: NTQ

Purpose of Issue: Planning

Issue: A



Hutchison 3G UK Limited

Star House, 20 Grenfell Road

Maidenhead, SL6 1EH

Tel: 01628 765 000

Fax: 01628 765 001

H3G Base Station Information line:

0845 6043000

Available 9am-6pm Monday to Friday



Hatfield Business Park

Hatfield

Hertfordshire

AL10 9BW

Tel: 01707 315000

Fax: 01707 319001



Mobile Broadband Network Limited

Sixth Floor, Thames Tower, Station Road, Reading, RG1 1LX

Design Consultant & Principal Contractor:



WHP Telecoms

Unit 1 Maple Park,

Low Fields Avenue, Leeds

LS12 6HH

Tel: 01133023550

e-mail: info@whptelecoms.com

Site Name:

UPPER CONRAN STREET SW

Site ID:

1622474

Address:

UPPER CONRAN STREET,
MANCHESTER,
GREATER MANCHESTER,
M9 4DA

Title:

305 EQUIPMENT SCHEDULES & SUPPORT STRUCTURE DETAILS

Project:

NTQ

Purpose of Issue:

PLANNING

EE Cell ID: 76341

MBNL Cell ID: MAN402

3UK Cell ID: M0797

Master Drawing No:

1622474_MAN402_76341_M0797_M001

Issue:

A

100mm

50mm

10mm