


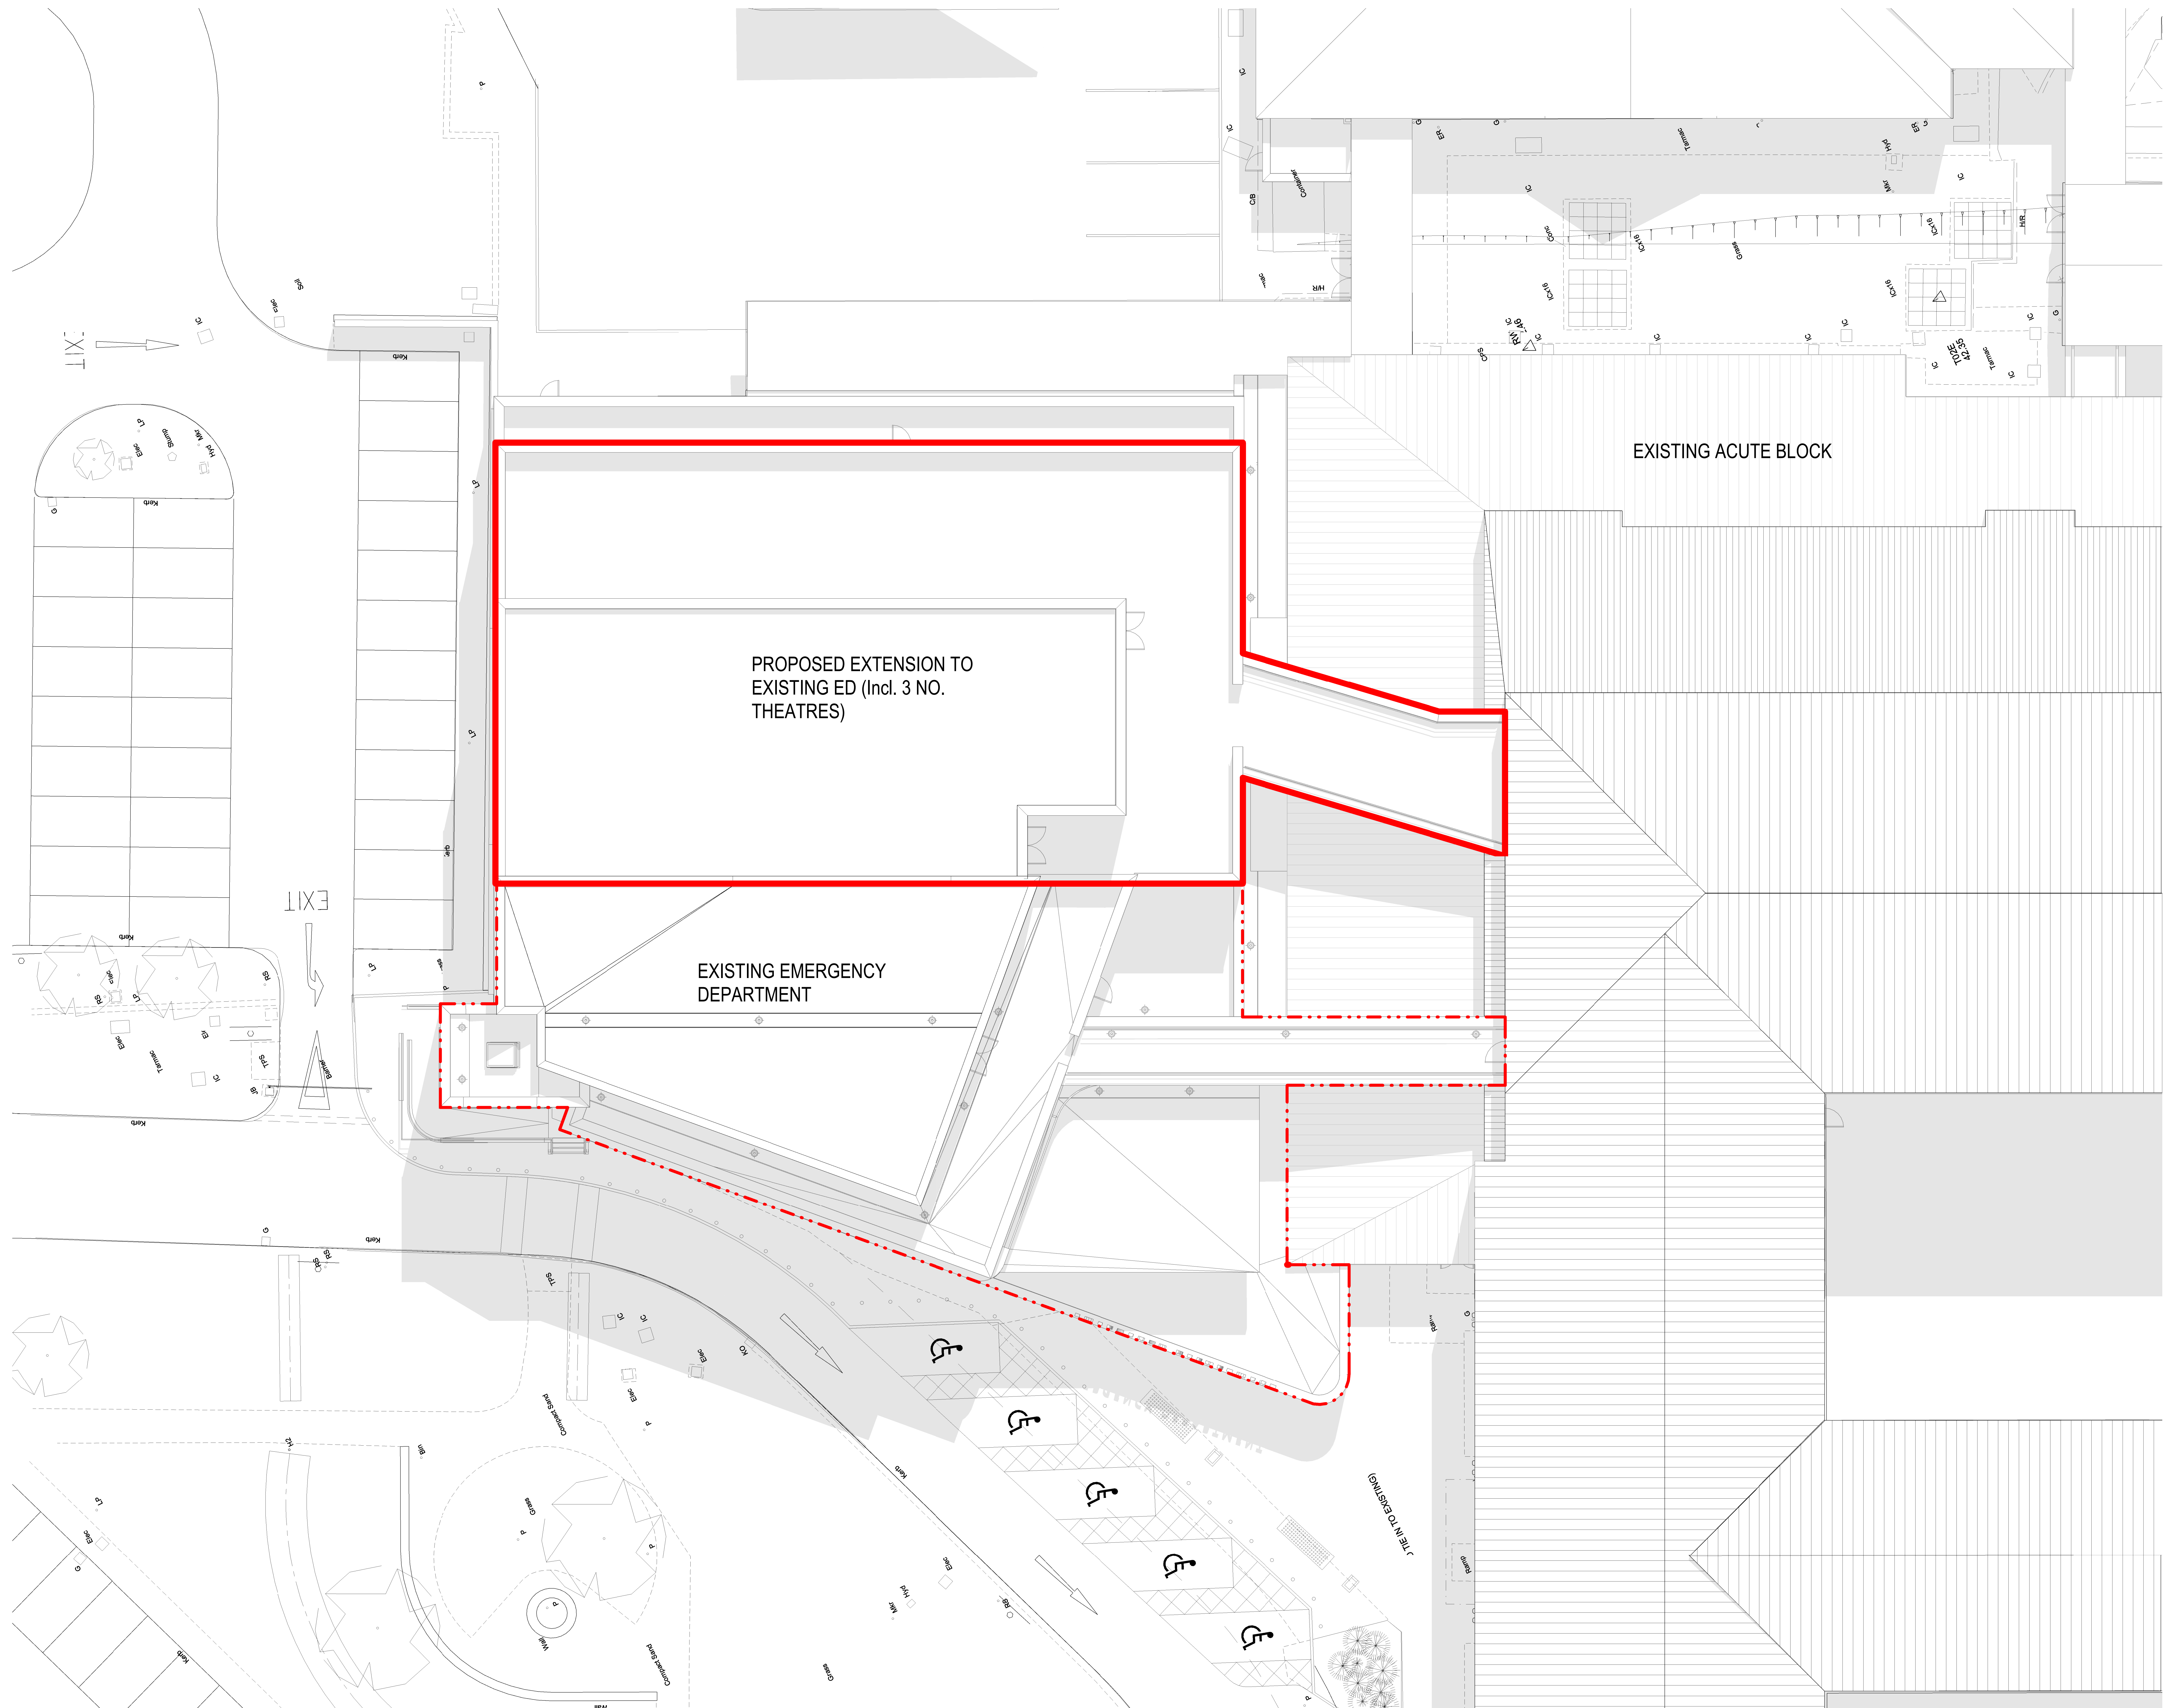

Notes:

- This drawing is copyright.
- Do not scale dimensions from this drawing.
- This drawing is to be read in conjunction with all other relevant drawings.
- All dimensions on this drawing are to be rounded to the nearest millimetre.
- Use drawing only for purposes listed below.
- This drawing may not remain colour.

Scale Bar:

0 5m 5m 5m

Scale: 1:100

North Point

Key Plan:

Hazard

HAZARDOUS

To avoid significant hazards or information that is unusual

To be read in conjunction with all other consultant's drawings

Refer to CDM Schedule XXXX-48-WB-XX-SHA-SIA-200-XXXX

The following external model files are included within this drawing:

Sign	Date	Revision Notes	Drawn By	Reviewed
[INSERT CLIENT / CONTRACTOR LOGO OR NAME HERE (IF REQUIRED)]				
		www.ibigroup.com		
Drawing Title WYTHENSHAWE HOSPITAL ED; ADDITIONAL THEATRES				
Drawing Title PROPOSED ROOF PLAN				
Job Number 124278 Standard 1:100	Date 13/11/2020	Security Classification BL PLANNING	Drawn By BL Reviewed By MH	
Job Number 124278-IBI-01-01-PL-A-200-0004		Revision	Circularity	