


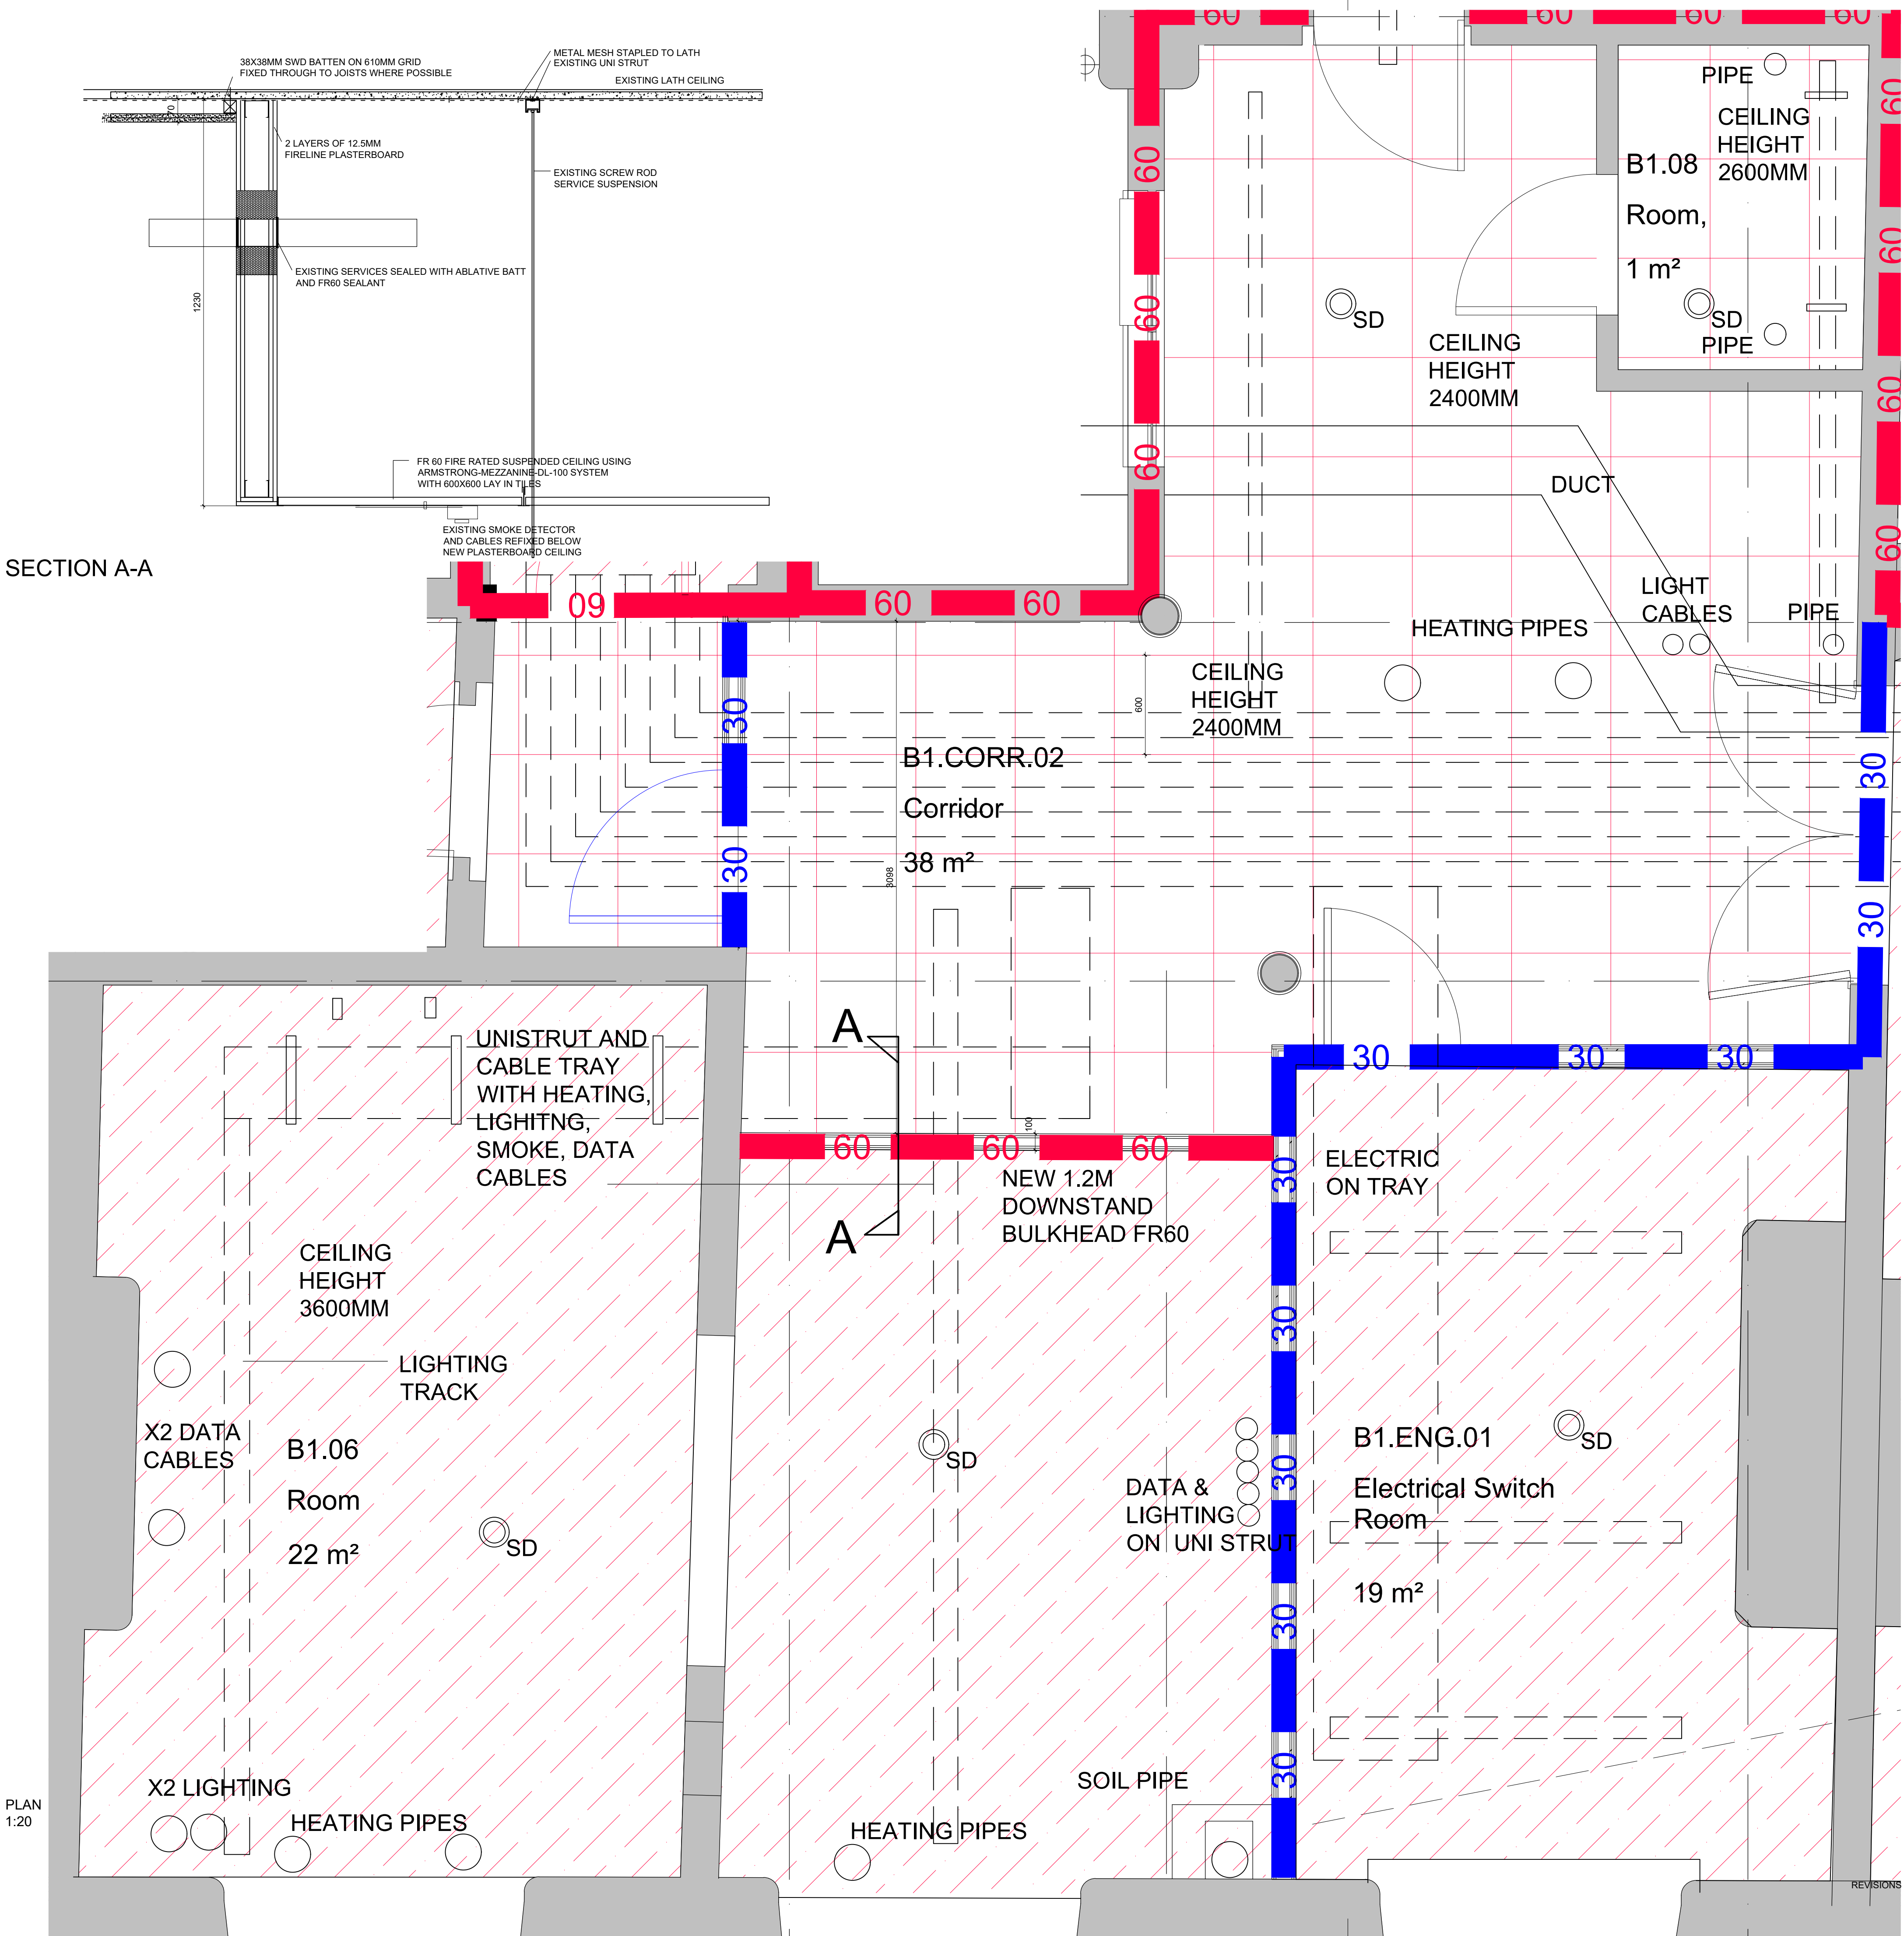


SECTION A-A

PLAN
1:20



KEY

KEY

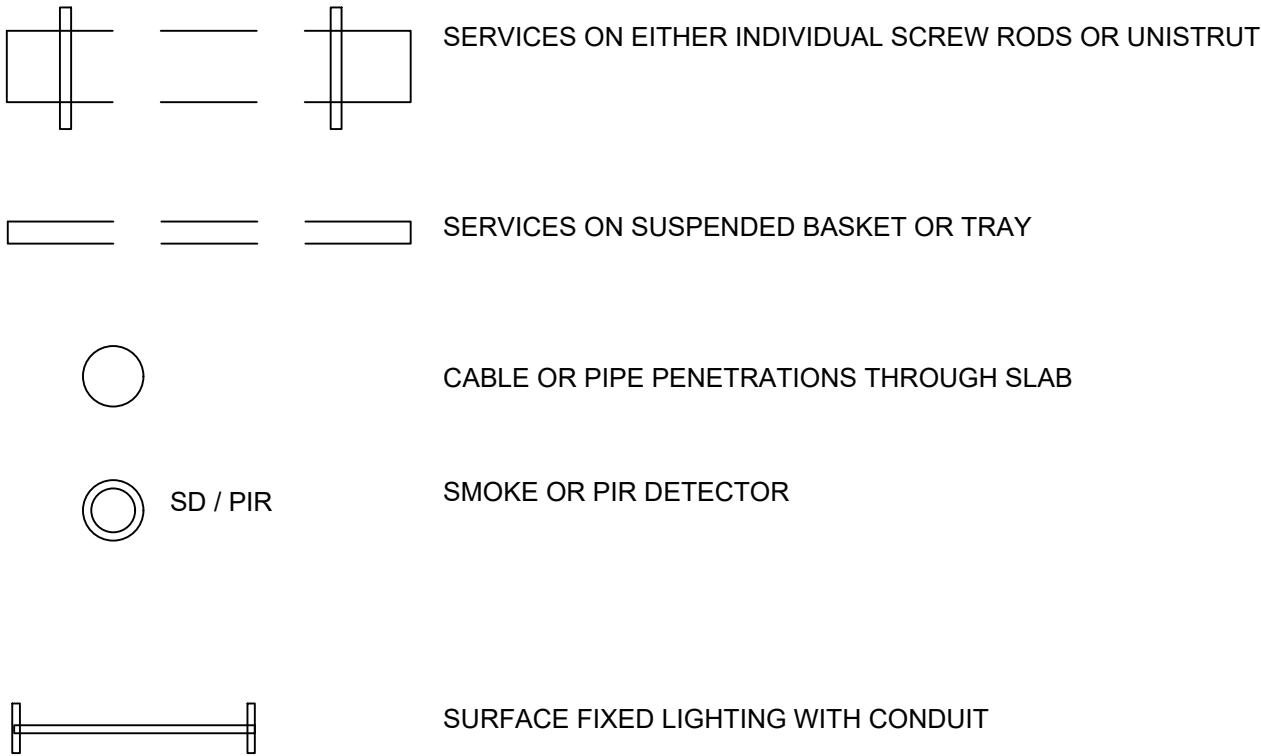

- NOTES:
1. ALL SMOKE DETECTORS WILL REQUIRE TEMPORARY REMOVAL FOR REFITTING AGAINST NEW CEILING LINING.
 2. UNI STRUT AND SCREW RODS TO REMAIN IN PLACE FOR FITTING NEW CEILING AROUND WITH FR SEALANT AROUND RODS.
 3. NEW WALLS AROUND SERVICES WILL REQUIRE SEALING WITH ABLATIVE BATTS AND FR SEALANT.
 4. ALL ELECTRICAL PENETRATIONS (UPTO 40MMØ I.E DATA, SMOKE LIGHTING) AROUND EXISTING SERVICES WILL REQUIRE FR SEALANT.
 5. ALL MECHANICAL SERVICES ABOVE 40MM Ø (I.E. HEATING PIPES, SOIL/RWP PIPES) WILL REQUIRE A FR60 FIRE COLLAR FITTING IN THE NEW CEILING.

TYPE 2
AREA OF LATH AND PLASTER CEILING TO BE UNDERDRAWN USING:
METAL MESH, (CHICKEN WIRE) FIXED IN ACCORDANCE WITH MANUFACTURER INSTRUCTIONS. 38X38MM SWD BATTENS (OR MF GRID AT 610MM CENTRES), 2 LAYERS OF 12.5MM FIRELINE PLASTERBOARD, ALL BOARD JOINTS AND JUNCTIONS FILLED WITH BONDING.

TYPE 1
AREA OF LATH AND PLASTER CEILING TO BE UNDERDRAWN USING:
METAL MESH, (CHICKEN WIRE) FIXED IN ACCORDANCE WITH MANUFACTURER INSTRUCTIONS FR60 FIRE RATED DEMOUNTABLE SUSPENDED MF CEILING GRID WITH LAY IN TILES. VOID DETECTION WILL NOT BE REQUIRED.

CLIENT	Manchester Metropolitan University
PROJECT	Ormond Building
TITLE	PROPOSED REFLECTED CEILING PLAN B1.CORR.02, B1.ENG.02, B1.06, B1.08
NUMBER	20608_P278
REVISION	A
STATUS	PLANNING
SCALE	1:20 @A1
DATE	05/03/21
DRAWN BY	SK
CHECKED BY	SG

A	SMOKE_DETECTOR_VOID_REMOVED	04/21	SK	LM
-	DRAWING_ISSUE	31/03/21	SK	LM

DATE, DRAWN: CHECK

seven.

SEVENARCHITECTURE.CO.UK
Studios at:
61 Oxford Street,
MANCHESTER, M1 6EQ
t: 0161 226 9655
Clarendon House, Victoria Avenue,
HARROGATE, HG1 1DY
t: 01423 709 907
Gallery 6, Doc Victoria,
CAERNARFON, LL55 1SQ
t: 01286 685 253
24 Grenville Street,
LONDON, EC1N 6SS
t: 0203 036 0691