


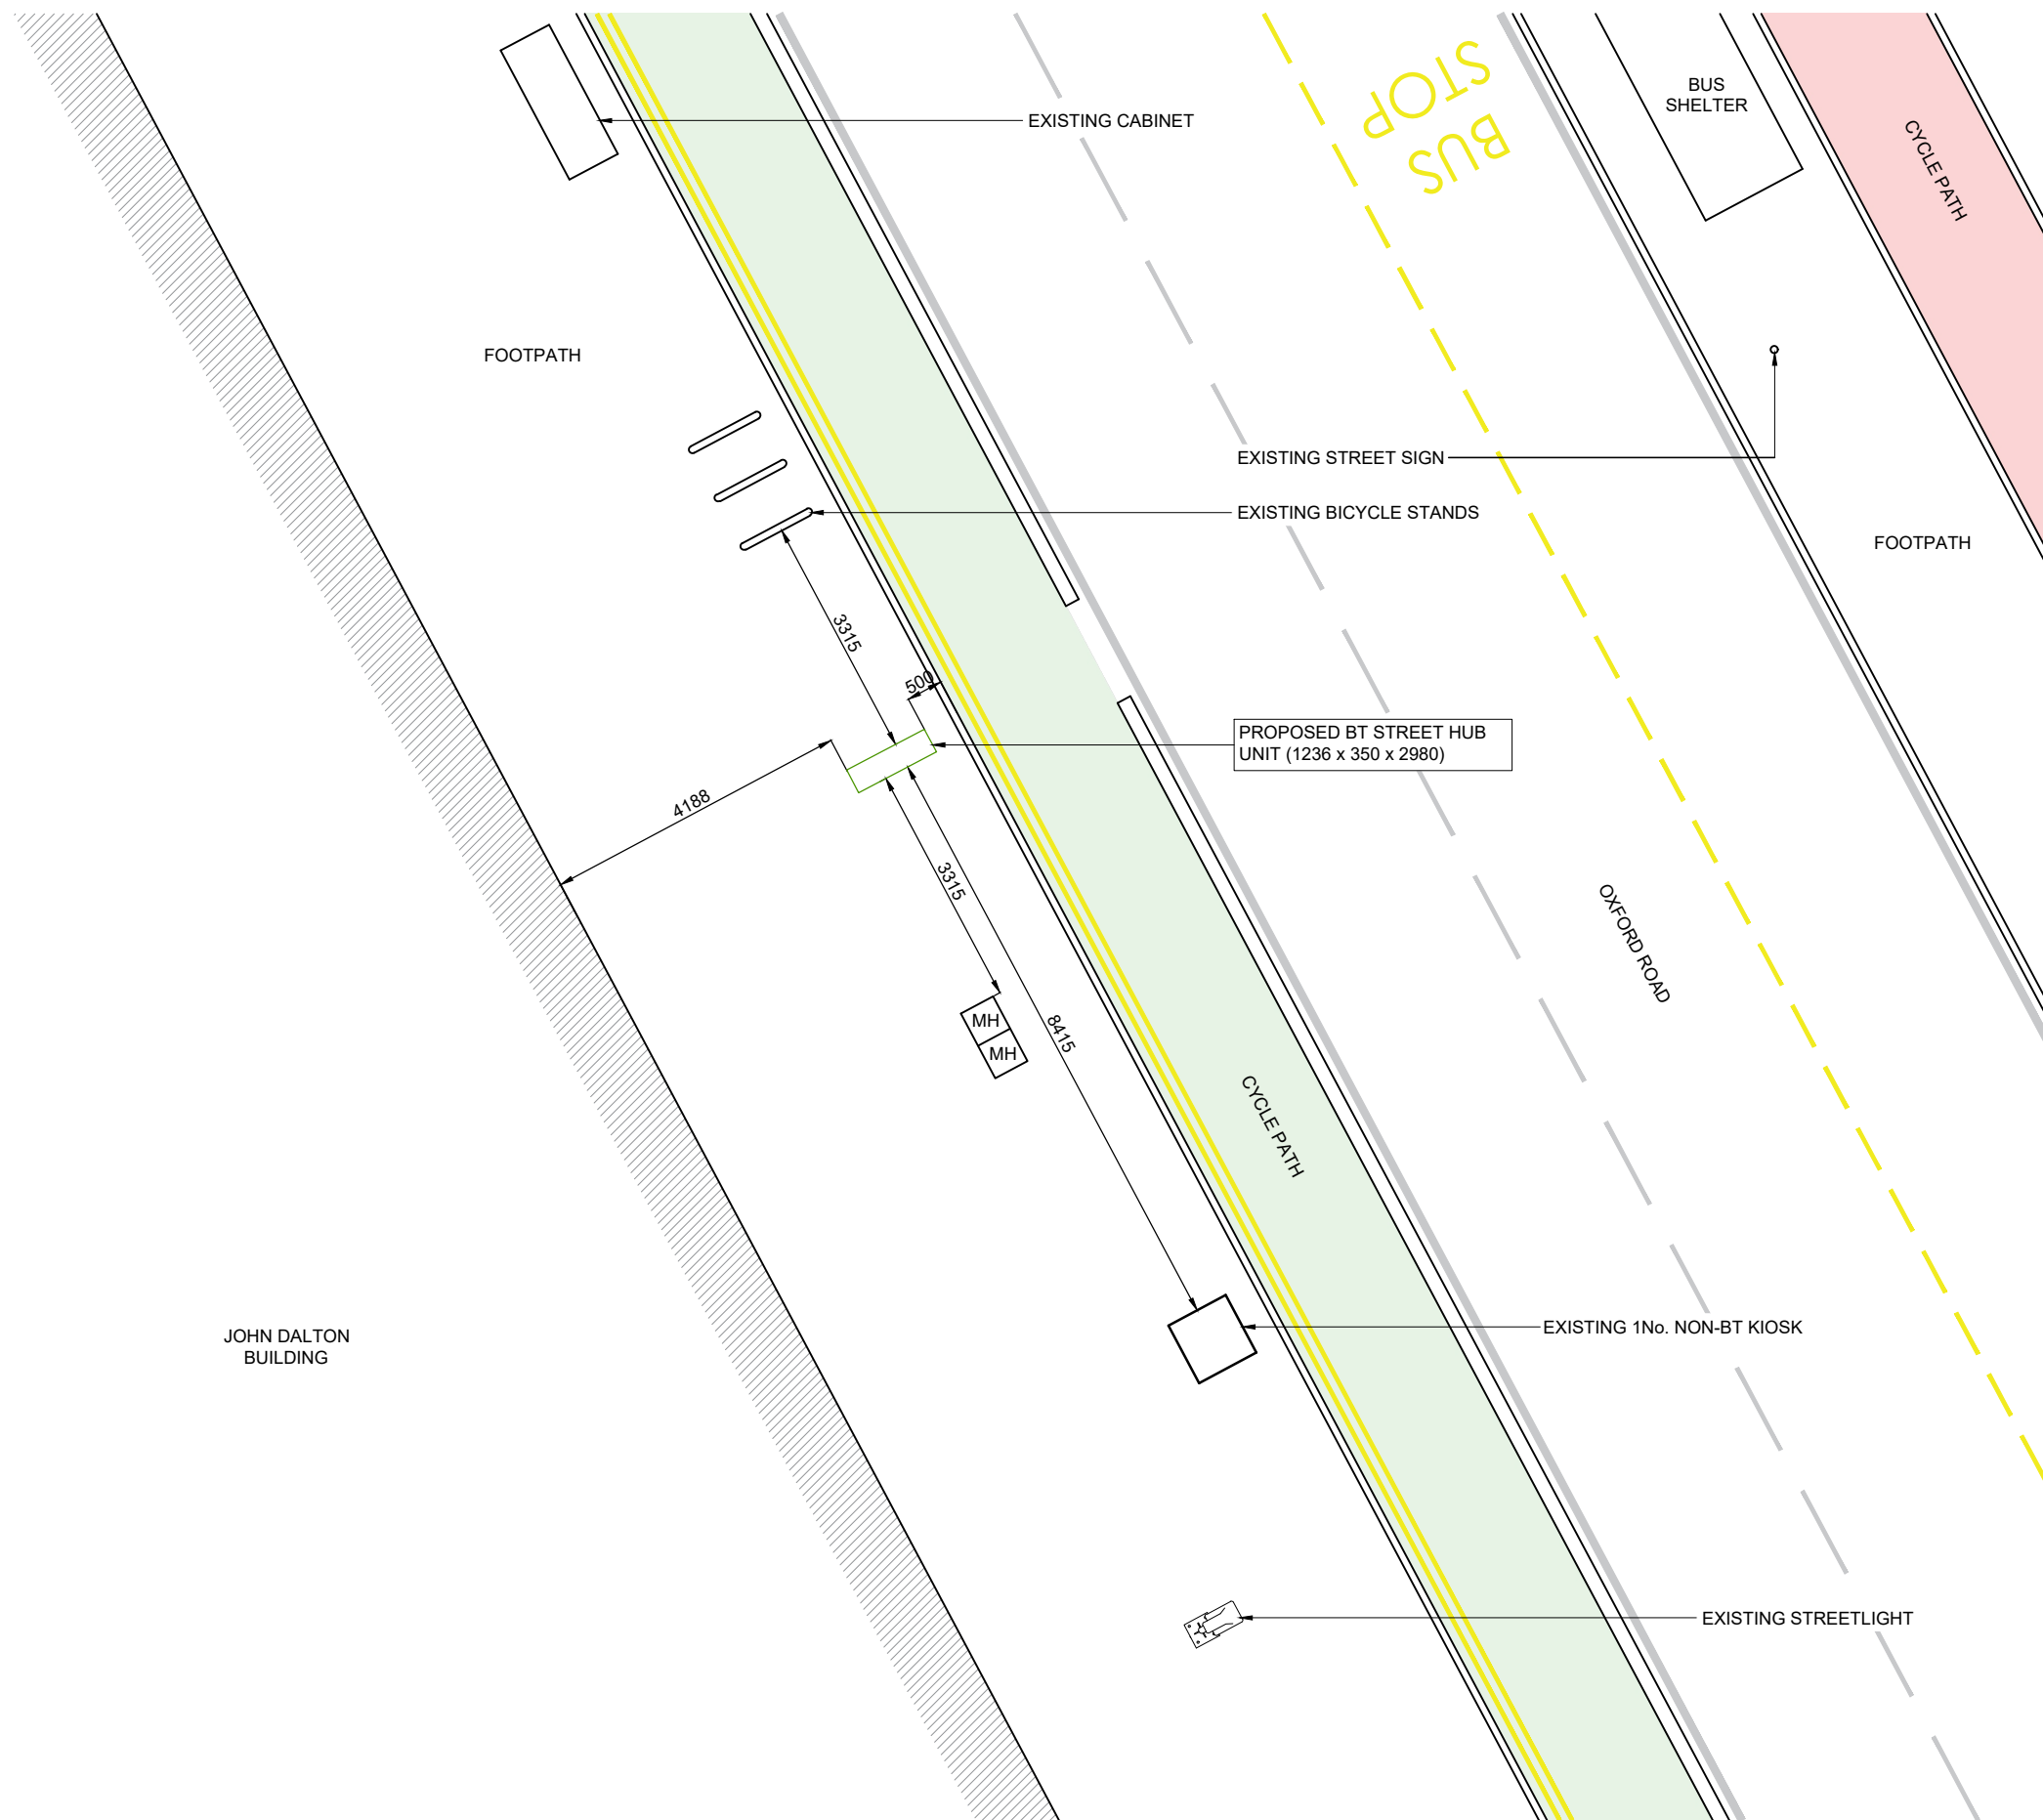

PROPOSED SITE PLAN
SCALE 1:100

GENERAL NOTES

Use written dimensions only, do not scale from drawing. Use latest revision of all referenced information.

A	24.04.21	Amend - New BT Streethub Structure	MD	JE
Rev	Date	Description	Drawn	Chkd

MONO CONSULTANTS LIMITED
70-76 Steam Packet House
Cross Street
Manchester, M2 4JG
t. 44 (0)161 839 8839
www.monoconsultants.com

Drg Status
PLANNING

Cell No. & Name
MAN022

Site Name & Address
OS JOHN DALTON BUILDING, OPP
TESCO EXPRESS)
OXFORD ROAD,
MANCHESTER,
M1 7ED

Drawing Title
PROPOSED SITE PLAN

Scale	1:100	Date	24.04.2021
Drawn By	MD	Checked By	JE
Drawing Number	002	Revision	A