


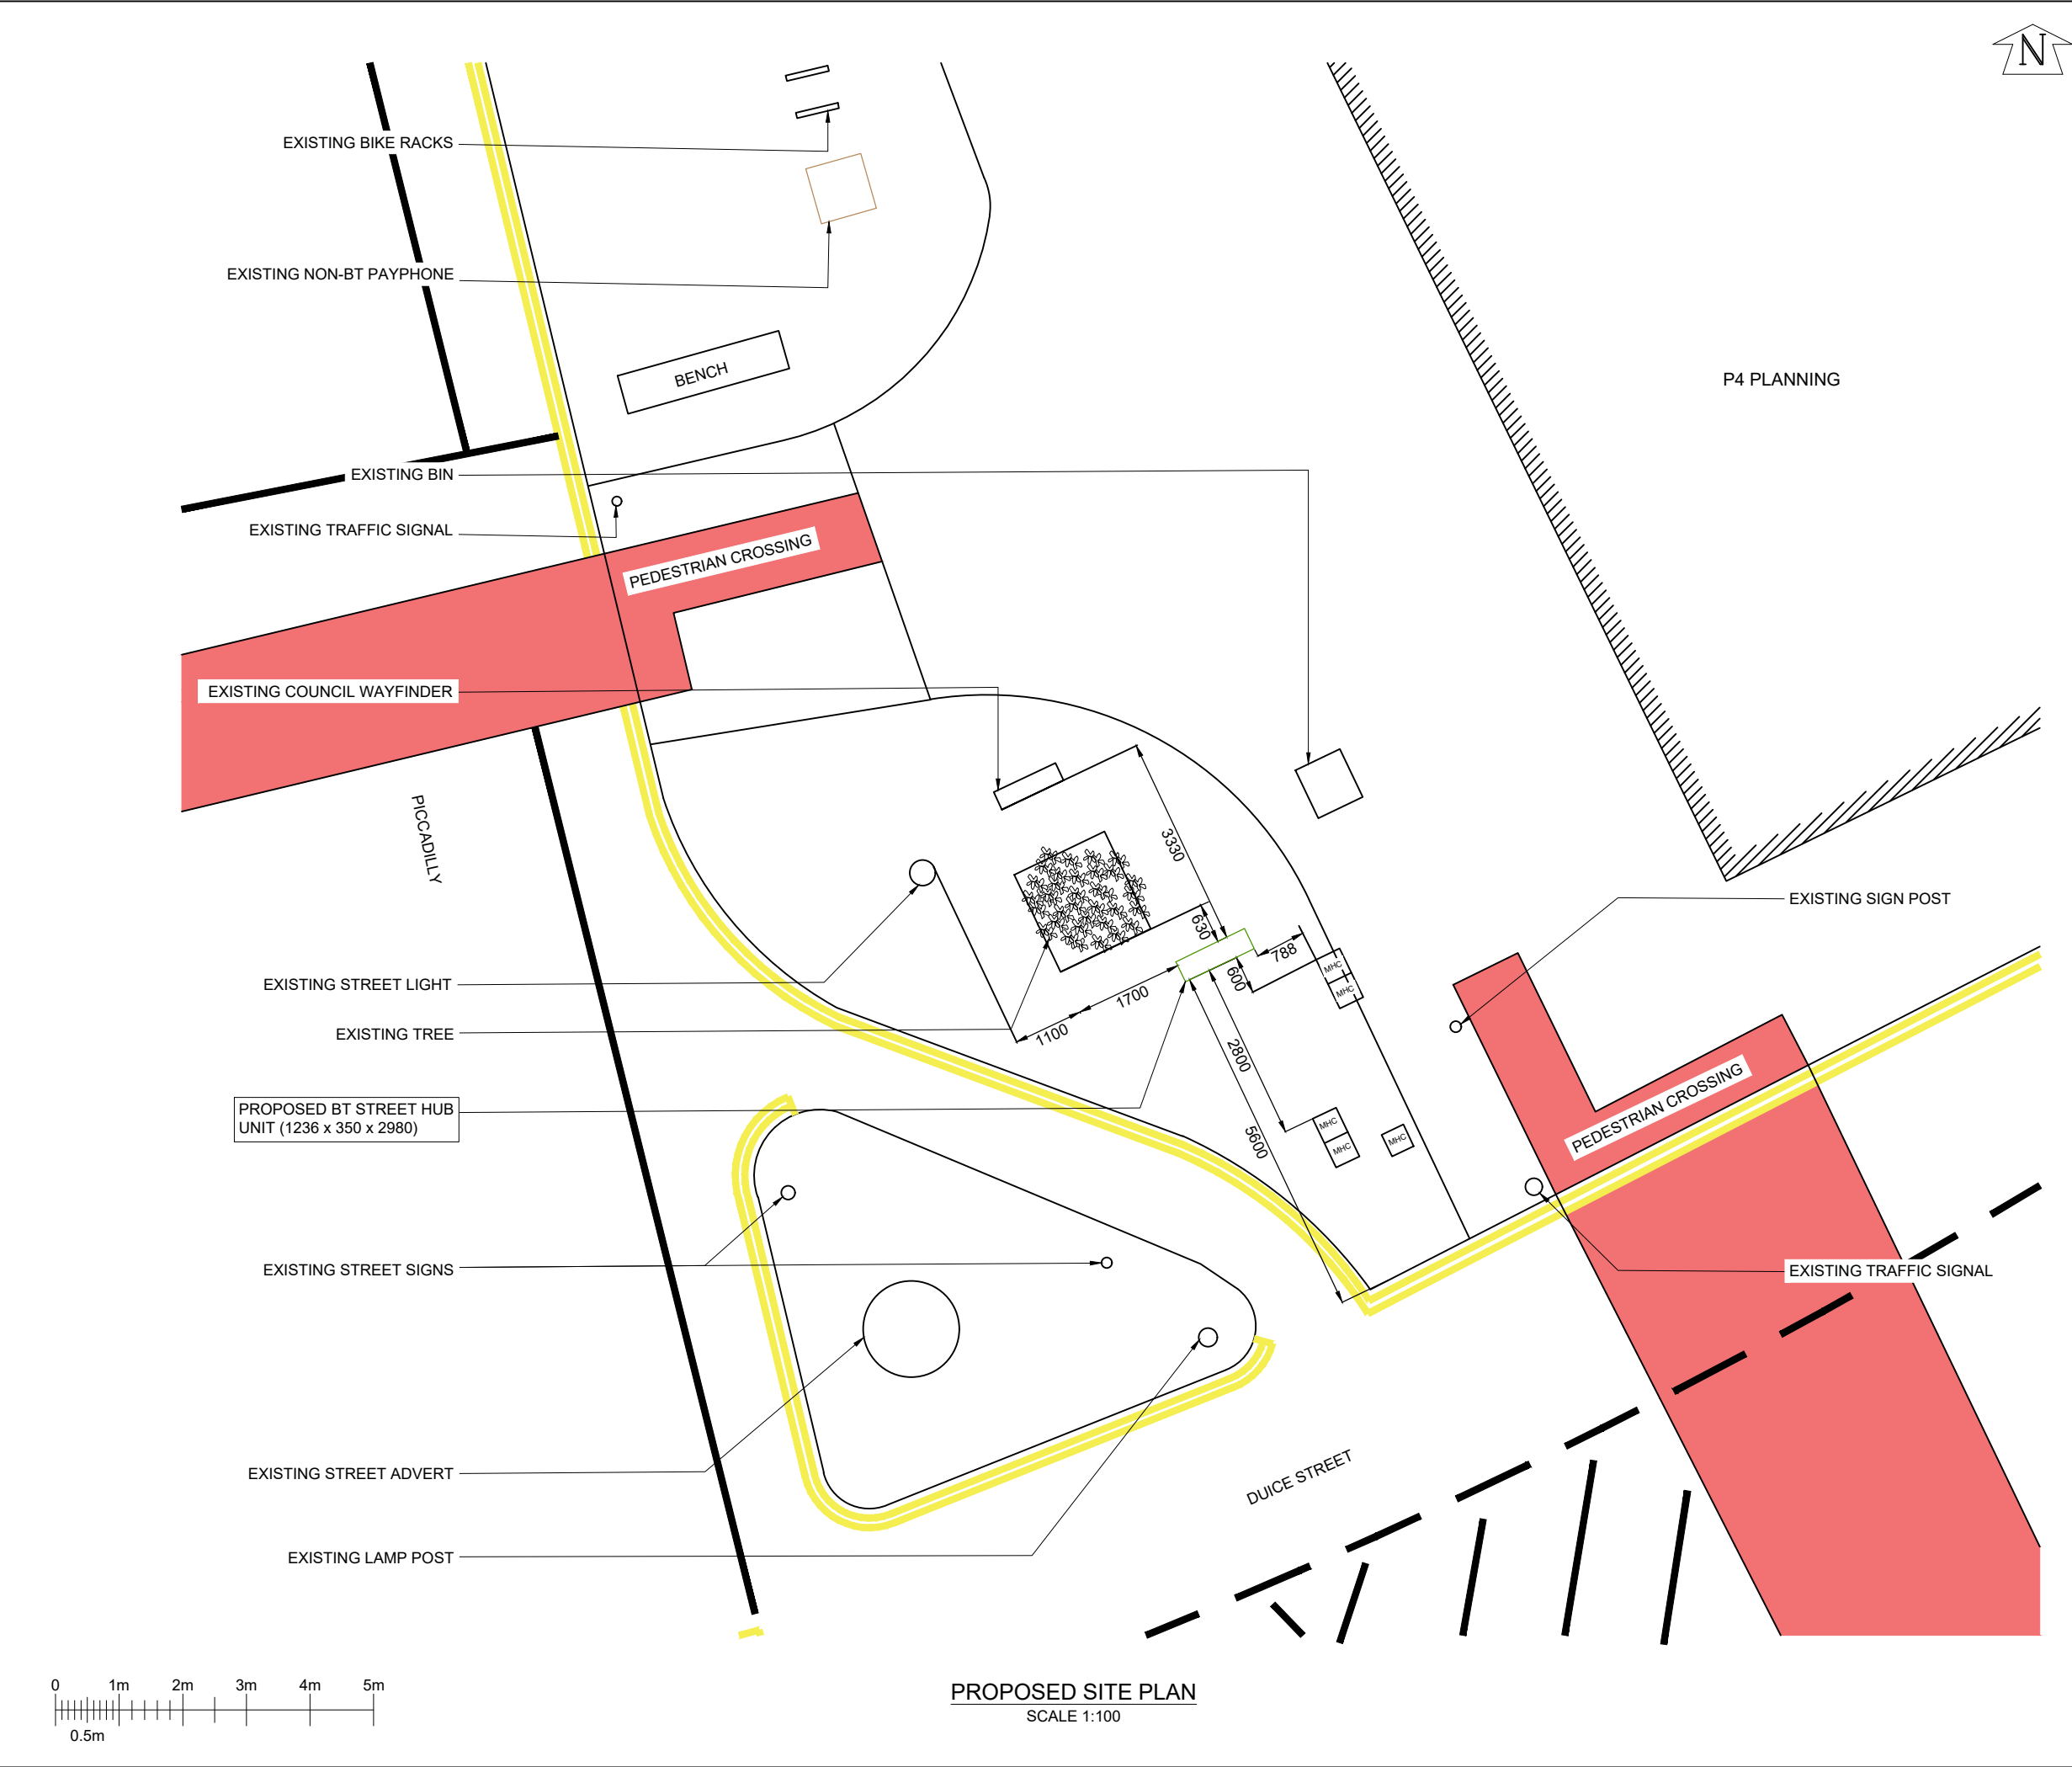

GENERAL NOTES

Use written dimensions only, do not scale from drawing. Use latest revision of all referenced information.

A	24.04.21	Amend - New BT Streethub Structure	MD	JE
Rev	Date	Description	Drawn	Chkd

MONO CONSULTANTS LIMITED
70-76 Steam Packet House
Cross Street
Manchester, M2 4JG
t. 44 (0)161 839 8839
www.monoconsultants.com

Drg Status
PLANNING

Cell No. & Name
MAN 025

Site Name & Address
**PICCADILLY
(OS RODWELL TOWER,
JCN DUCIE ST.,
M1 2HY.**

Drawing Title
PROPOSED SITE PLAN

Scale	1:100	Date	24.04.21
Drawn By	MD	Checked By	JE

Drawing Number 002	Revision A
------------------------------	----------------------