


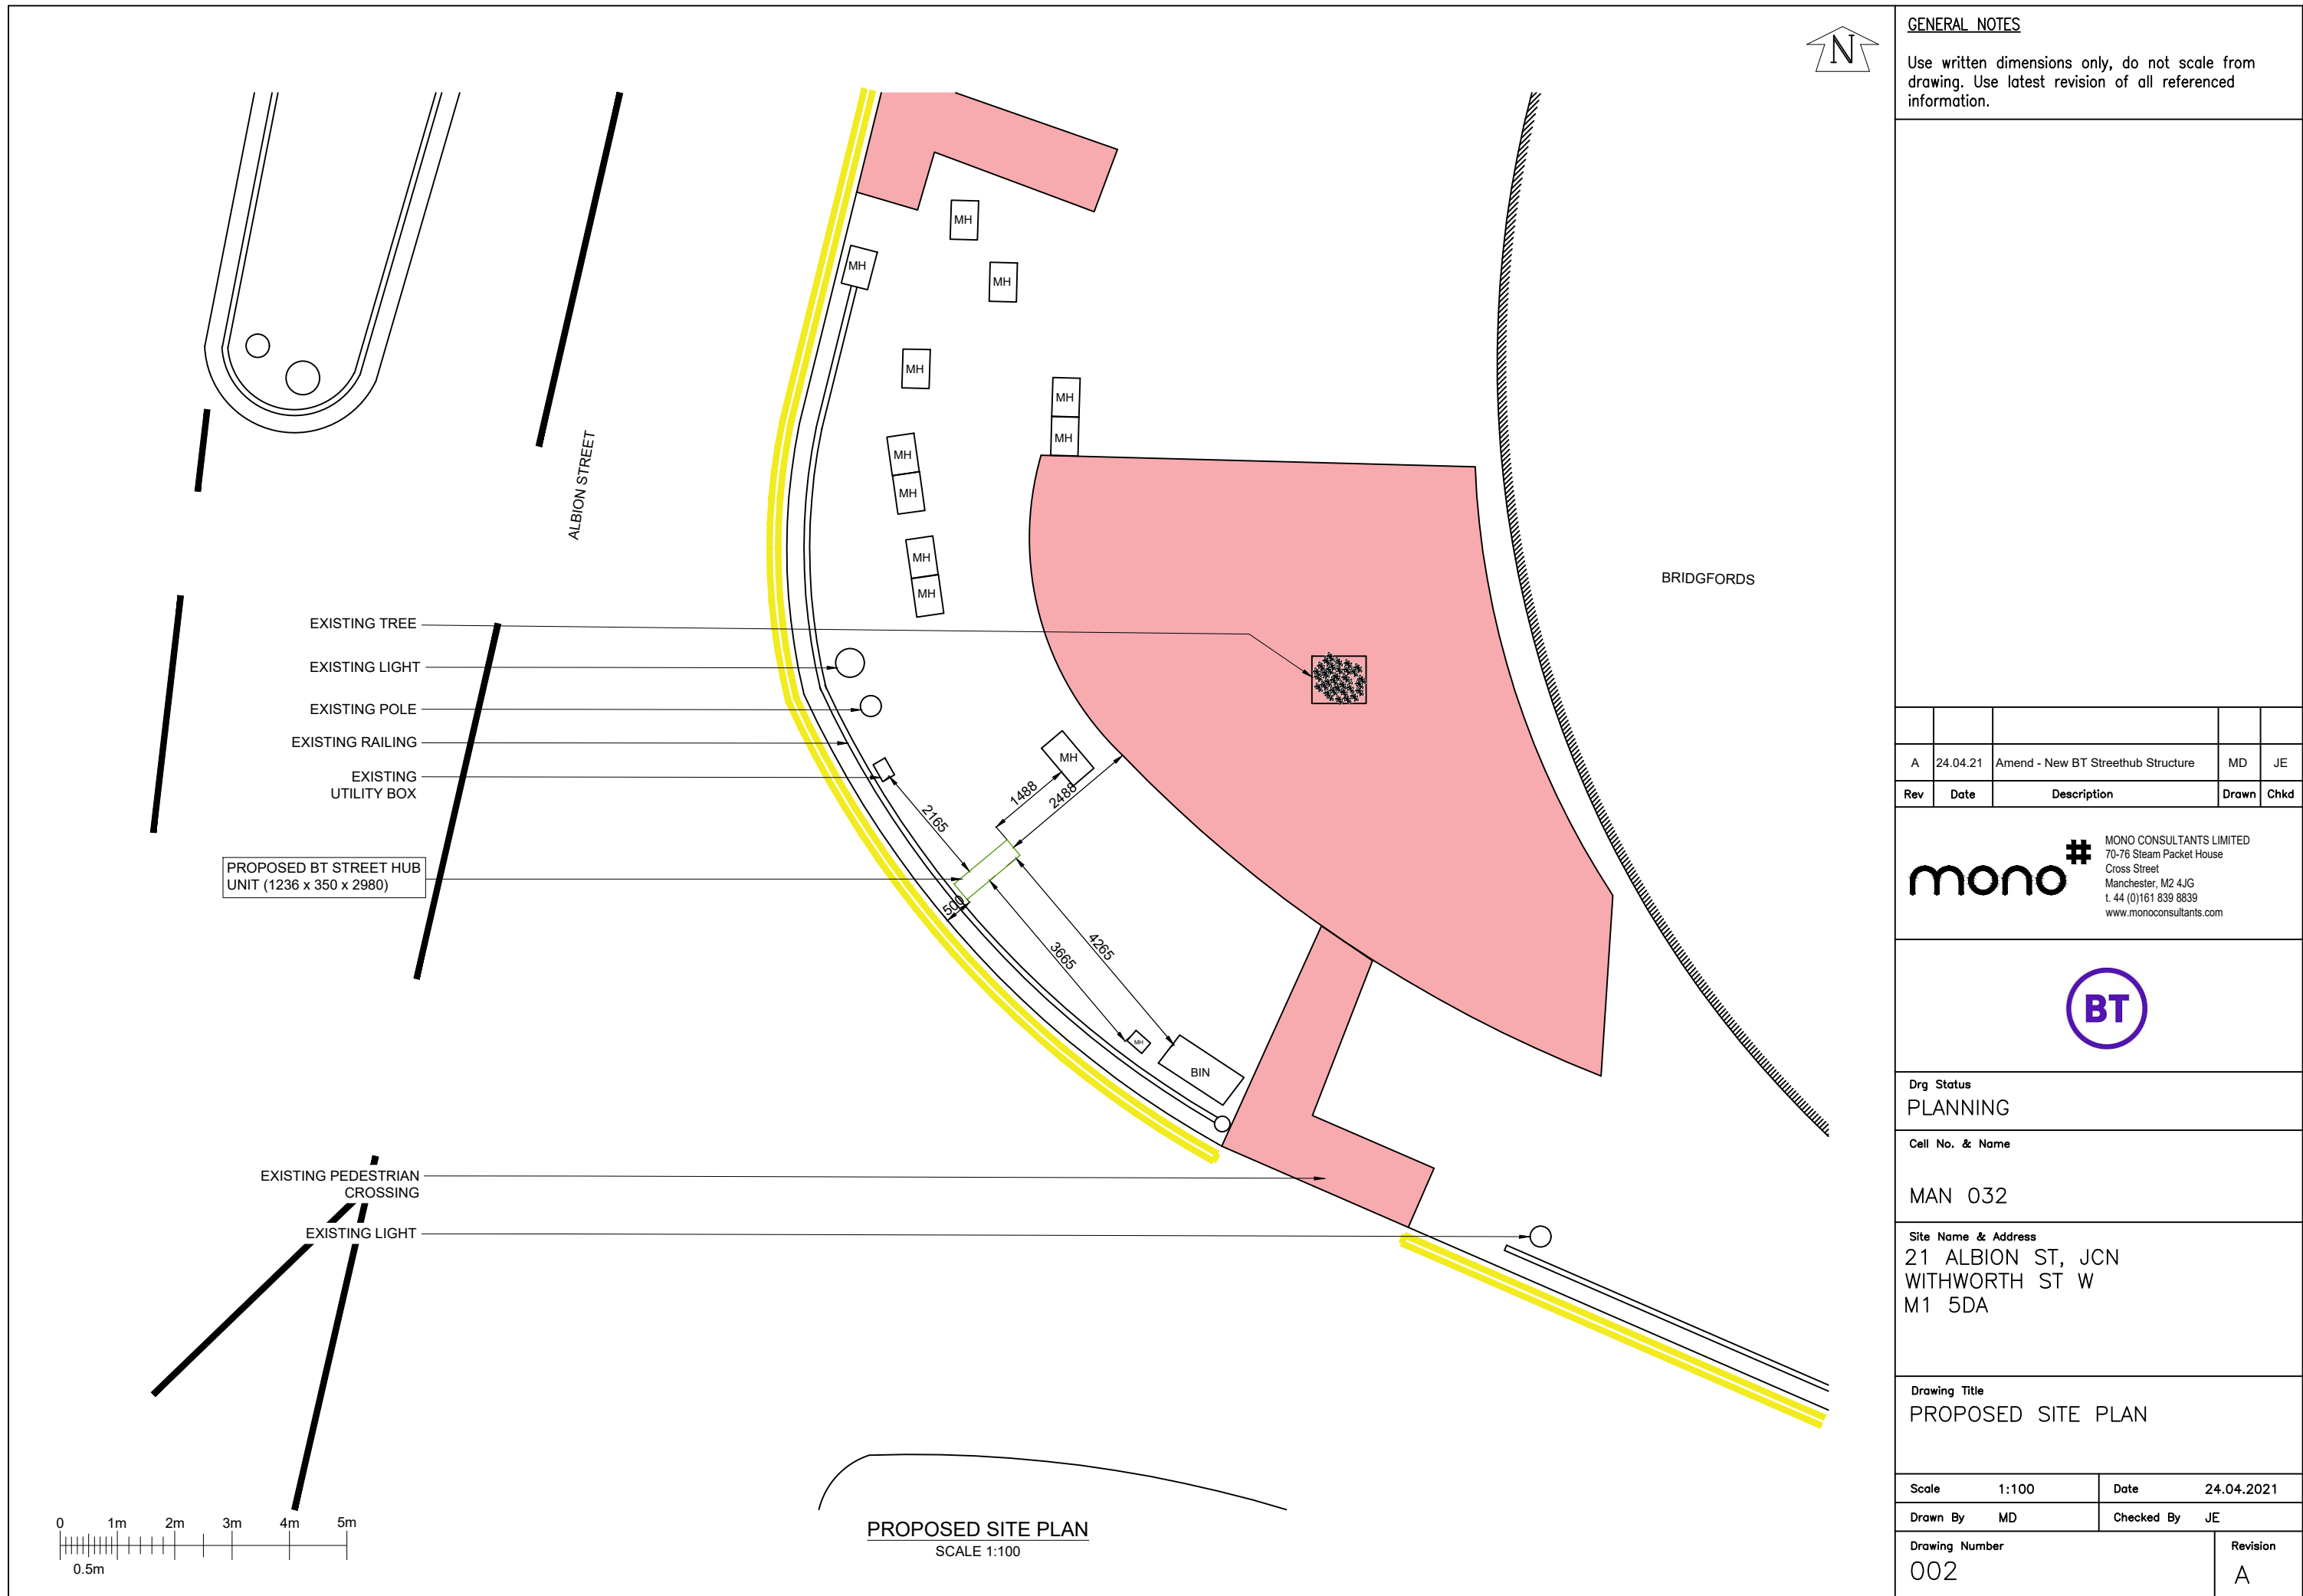

GENERAL NOTES

Use written dimensions only, do not scale from drawing. Use latest revision of all referenced information.

Rev	Date	Description	Drawn	Chkd
A	24.04.21	Amend - New BT Streethub Structure	MD	JE

mono **#** MONO CONSULTANTS LIMITED
70-76 Steam Packet House
Cross Street
Manchester, M2 4JG
t. 44 (0)161 839 8839
www.monoconsultants.com



Drg Status
PLANNING

Cell No. & Name
MAN 032

Site Name & Address
21 ALBION ST, JCN
WITHWORTH ST W
M1 5DA

Drawing Title
PROPOSED SITE PLAN