


REVISION	DATE	DESCRIPTION
-	17.03.21	FOR COMMENT
-	19.03.21	PLANNING ISSUE

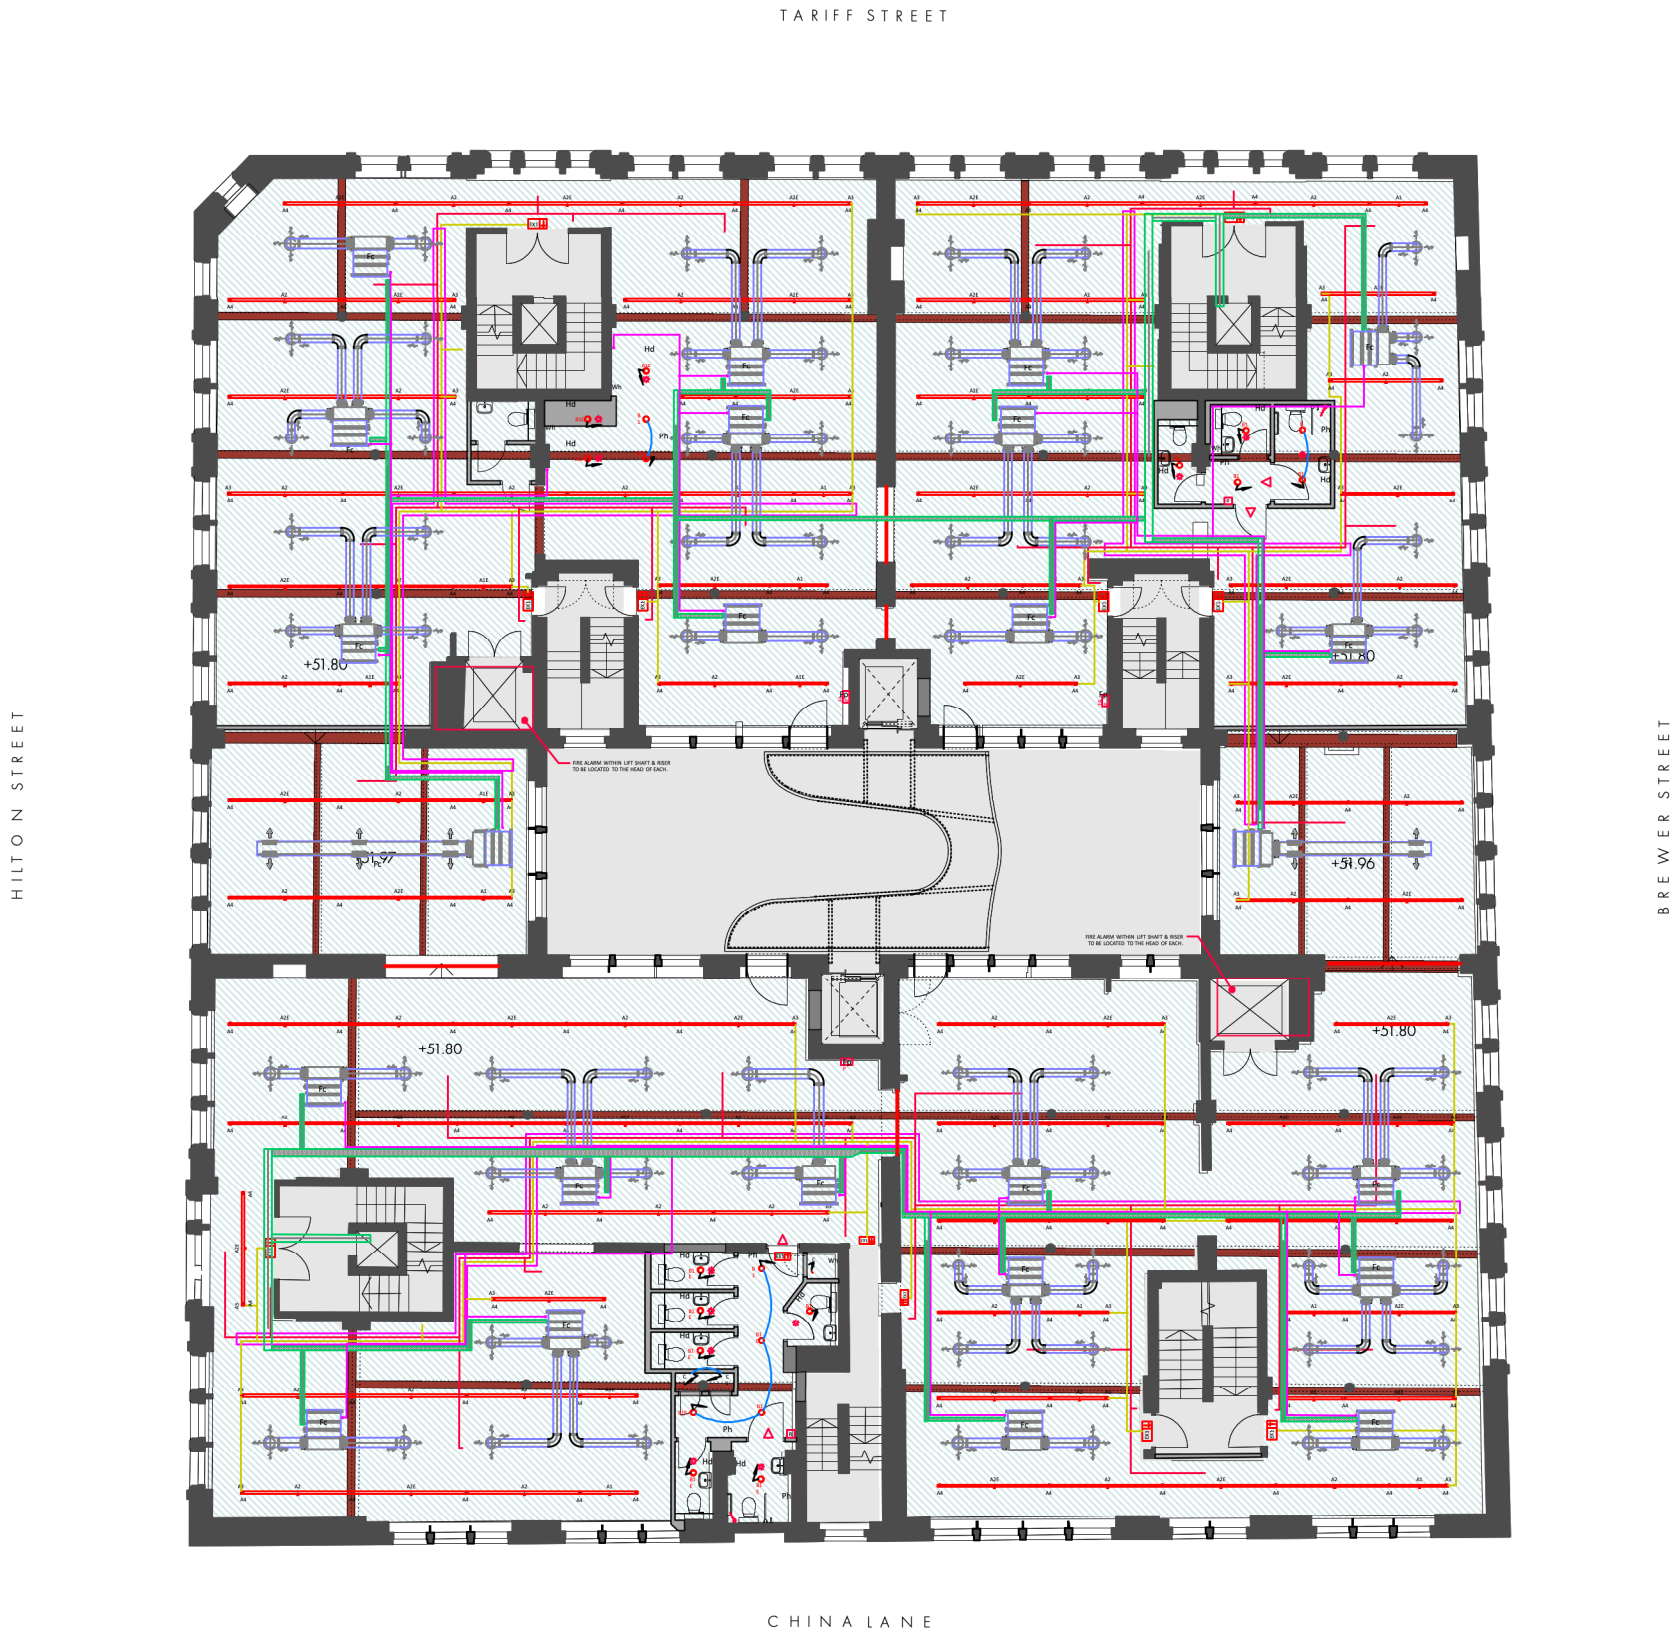

FOURWAYS HOUSE, FIRST FLOOR
PROPOSED REFLECTED CEILING PLAN


1:200 @ A3

REFLECTED CEILINGS KEY

- EXISTING PLASTERED CEILING
- ORIGINAL BEAM EXPOSED
- AREA NOT SUBJECT OF THIS APPLICATION
SEE APPLICATIONS No.s 122935/LO/2019& 123242/FO/2019

MECHANICAL AND ELECTRICAL KEY

- A1 Thorlux 30/45w LED 1500mm Hi-Bar Suspended Continuous Luminaire - Smart Scan (Colour TBC)
- A1E Thorlux 30/45w LED 1500mm Hi-Bar Suspended Continuous Luminaire - Smart Scan Emergency (Colour TBC)
- A2 Thorlux 60/90w LED 3000mm Hi-Bar Suspended Continuous Luminaire - Smart Scan (Colour TBC)
- A2E Thorlux 60/90w LED 3000mm Hi-Bar Suspended Continuous Luminaire - Smart Scan Emergency (Colour TBC)
- A3 Thorlux Hi-Bar Suspended End Kit
- A4 Thorlux Hi-Bar Suspension Kit
- LED Recessed Open Downlighter
- LED Recessed Emergency Version
- Maintained LED Scanlight c/w Arrow Up
- Maintained LED Scanlight c/w Arrow Directional
- Surface Mounted PIR c/w HVAC Contact For Fan Control
- Surface Mounted Corridor PIR
- Smoke Detector
- Smoke Detector c/w Sounder
- Heat Detector
- Manual Call Point
- Flashing Beacon
- Disabled WC Alarm Reset Unit
- Assistance Alarm Indicator Light & Buzzer
- Disabled WC Alarm Pullcord
- Fire Alarm Panel
- Conduit To Serve Lighting Installation
- Conduit To Serve Fire Alarm Installation
- 300mm x 25mm Galvanised Cable Tray
- Mitsubishi PEFY Series Fan Coil Unit (Or Equal & Approved)
- Supply Circular Swirl c/w Coanda Plate (Giberts Or Equal & Approved)
- Volume Control Damper
- Supply Air Ductwork
- Refrigerant Pipework (High Level)
- Condensate Drain

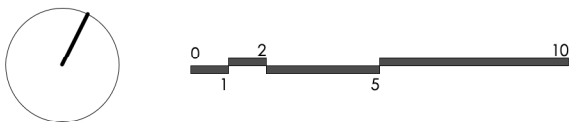

PLANNING ISSUE

OMI Architects

31 Blackfriars Road, Salford, Manchester, M3 7AQ
+44(0)161 832 3242 / info@omiarchitects.com / www.omiarchitects.com

PROJECT	FIRST FLOOR, FOURWAYS HOUSE				
DRAWING	PROPOSED REFLECTED CEILINGS PLAN				
DATE	MAR' 21	DRAWN BY	KT	SCALE	1:200@A3
JOB NO.	1412	DWG.NO.	L 2206		