
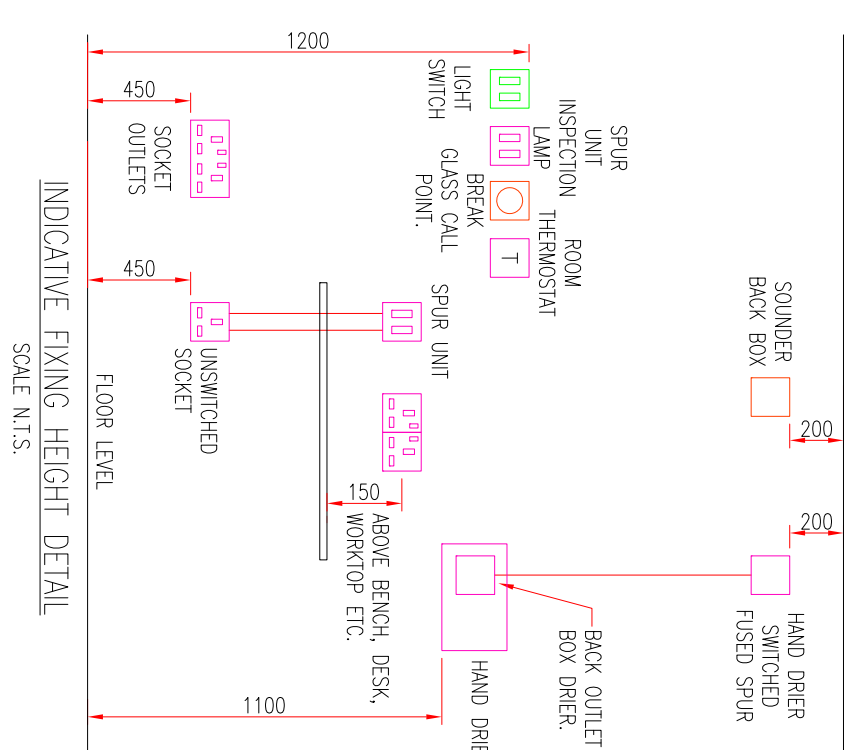


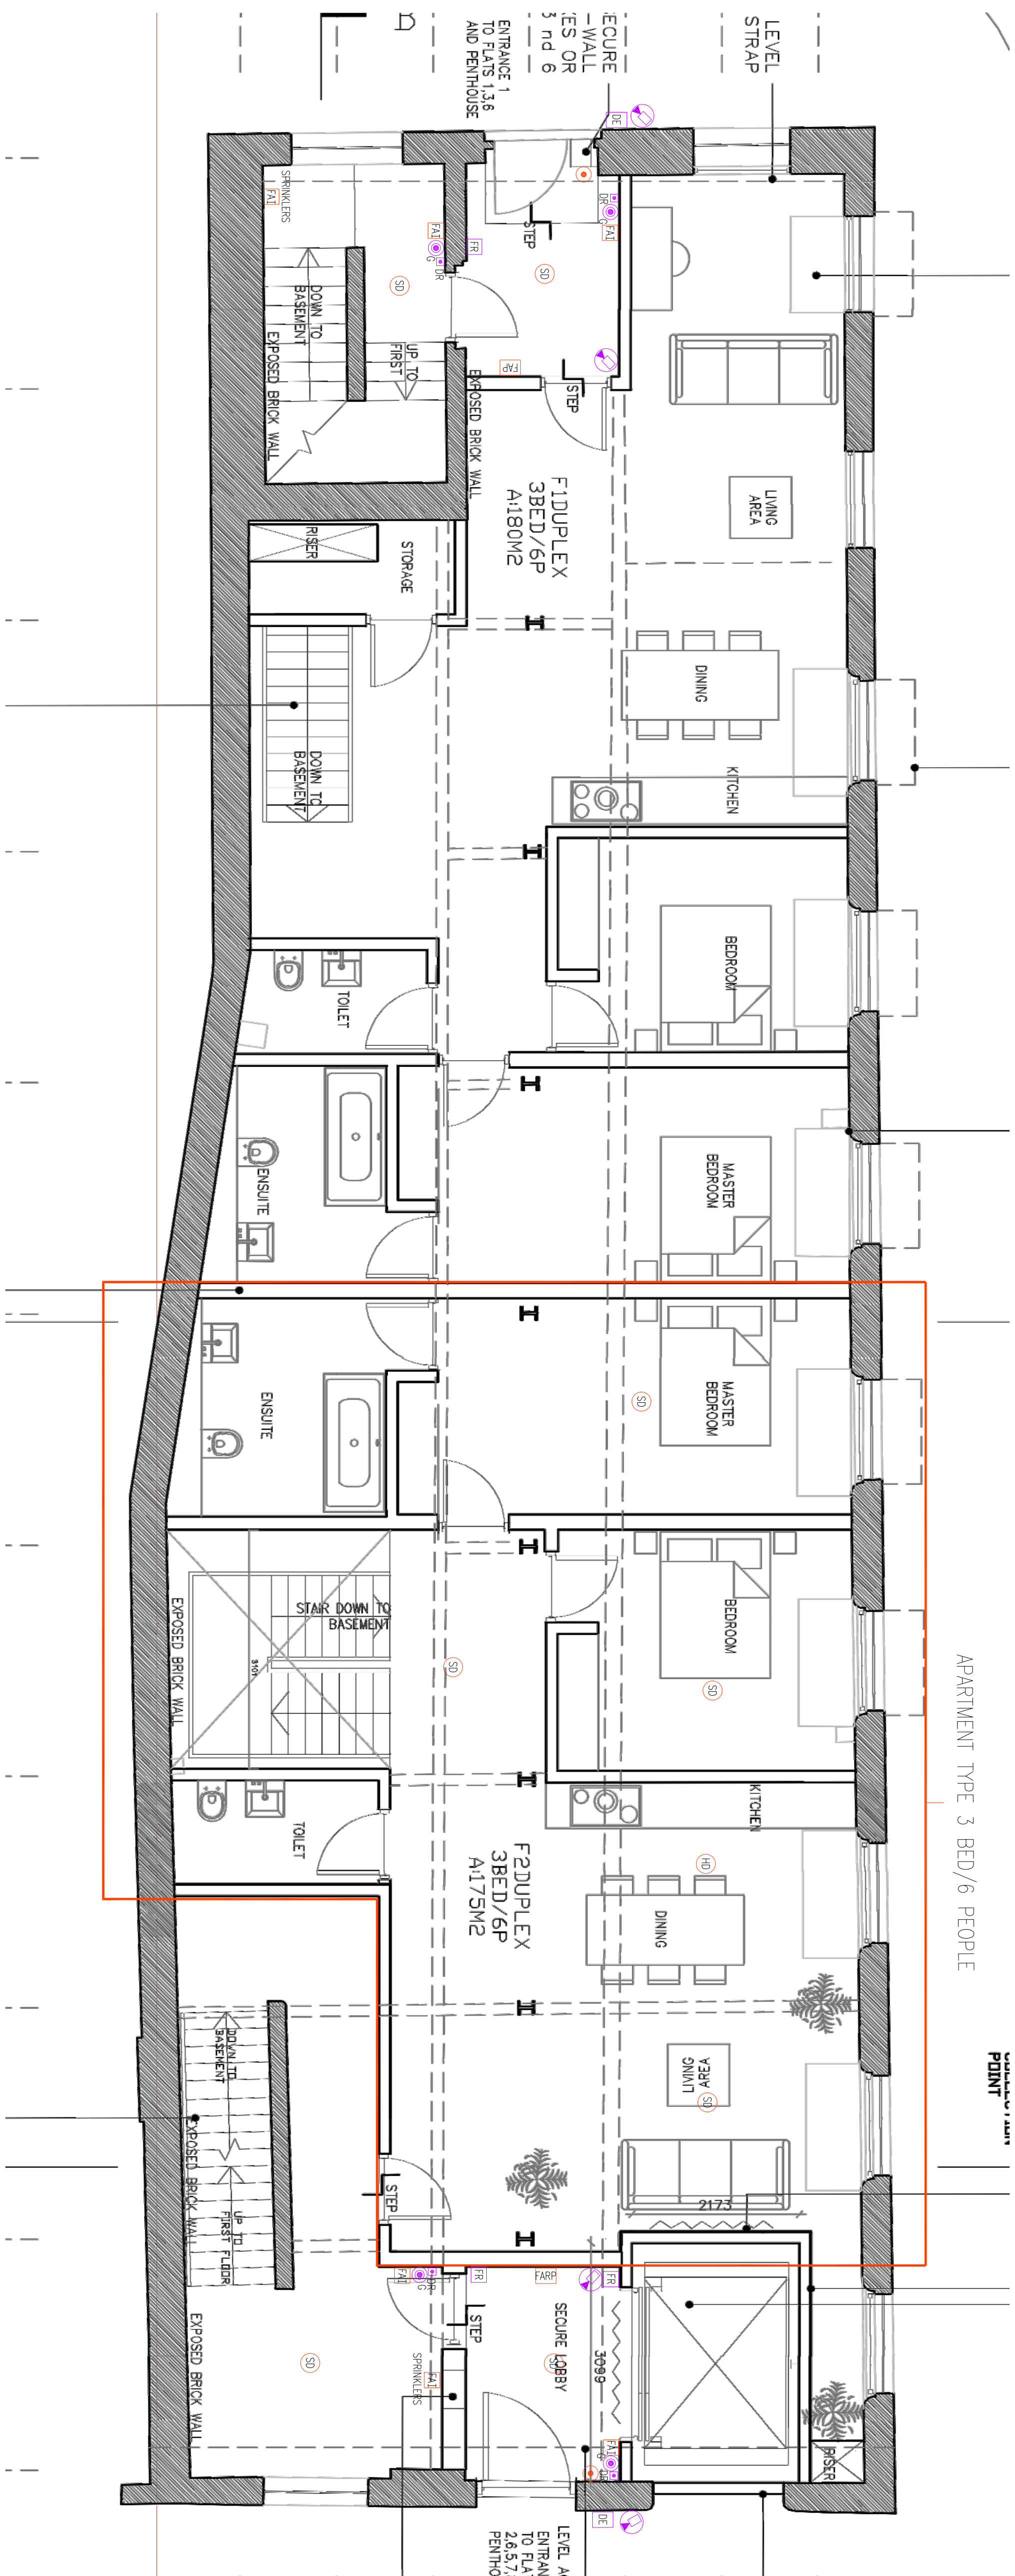

- Notes:**
1. The drawing is subject to copyright and is not to be reproduced in part or whole without approval.
 2. Do not scale this drawing - check all dimensions on site.
 3. The drawing shall be read in conjunction with the project specification(s) and all other contract documentation.
 4. All dimensions are in millimeters unless otherwise stated.
 5. Location of all equipment shown shall be confirmed/approved with the Client/Architect/Engineer prior to any installation
 6. The drawing must be read in conjunction with Mechanical and Electrical performance specifications and all other drawings as issued by the Architect, Structural Engineer and Water Energy and Consulting Engineer
 7. The location of equipment is typical only. The Contractor shall perform all calculations to determine the exact quantity and agree the final locations with the Architect.
 8. The drawing shows the intended location of building services plant and service routes in such detail as to include the design. The drawing does not show components that may be necessary to provide a full working installation.
 9. The positions of connection points, accessories and building services items are approximate and shown for guidance to assist during the tender process.
 10. Few co-ordinated drawings Construction drawings and Builderswork shall be produced by the contractor. Other no circumstances shall the tender drawings be used as installation drawings.

COMMUNAL FIRE ALARM & SECURITY LEGEND

- | | |
|---|--|
|  | SMOKE DETECTOR |
|  | SMOKE DETECTOR WITH SOUNDER BASE |
|  | SMOKE DETECTOR WITH SOUNDER AND BEACON BASE |
|  | HEAT DETECTOR |
|  | HEAT DETECTOR WITH SOUNDER BASE |
|  | HEAT DETECTOR WITH SOUNDER AND BEACON BASE |
|  | FIRE ALARM SOUNDER, (P) DENOTES EXTERNAL SOUNDER WITH ZENON BEACON |
|  | MULTI DETECTOR |
|  | MULTI DETECTOR WITH SOUNDER BASE |
|  | MULTI DETECTOR WITH SOUNDER AND BEACON BASE |
|  | MANUAL BREAK GLASS CALL POINT |
|  | DETECTOR REARME INDICATOR |
|  | FIRE ALARM INTERFACE |
|  | FIRE ALARM PANEL |
|  | FIRE ALARM REPEATER PANEL |
|  | MAGNETIC DOOR DETECTIVE |
|  | DOOR ENTRY PANEL WITH INTEGRAL FOG READER |
|  | REQUEST TO EXIT PUSH BUTTON |
|  | EMERGENCY DOOR RELEASE GREEN BREAK GLASS UNIT |
|  | DOOR CONTACT |
|  | FOG READER |
|  | CTV RECORDER |
|  | CCTV CAMERA |
|  | VR - MANUAL RESISTANT |
- APARTMENT FIRE ALARM LEGEND**
- SMOKE DETECTOR/SOUNDER, MANS POWERED WITH BATTERY BACKUP
- HEAT DETECTOR/SOUNDER, MANS POWERED WITH BATTERY BACKUP

APARTMENT FIRE ALARM LEGEND

POWERED WITH BATTERY BACKUP
HEAT DETECTOR/SOUNDER. MAIN
POWERED WITH BATTERY BACKUP

wait 
Energy & Consulting Engineers

Client:
ARTISAN

Project:
CABLE STREET, ANCOATS
MANCHESTER

Drawing Title:
ELECTRICAL SERVICES
FIRE ALARM & SECURITY LAYOUT
GROUND FLOOR

Drawn By:	KH	Checked By:	DW	Cad By:	KH	
Scale:	1:50	Paper Size:	A1	Date Created:	08 / 04 / 2019	
Drawing Number:	WECE-286-E-113				Drawing Revision:	T1