


ME&E DRAWINGS ARE FOR DESIGN INTENT ONLY.
THE MEP CONTRACTOR IS RESPONSIBLE FOR
THE FINAL INSTALLATION DRAWINGS INCLUDING
ALL SETTING OUT, DIMENSIONS, ALIGNMENT AND
COORDINATION WITH THE ARCHITECT'S
REQUIREMENTS

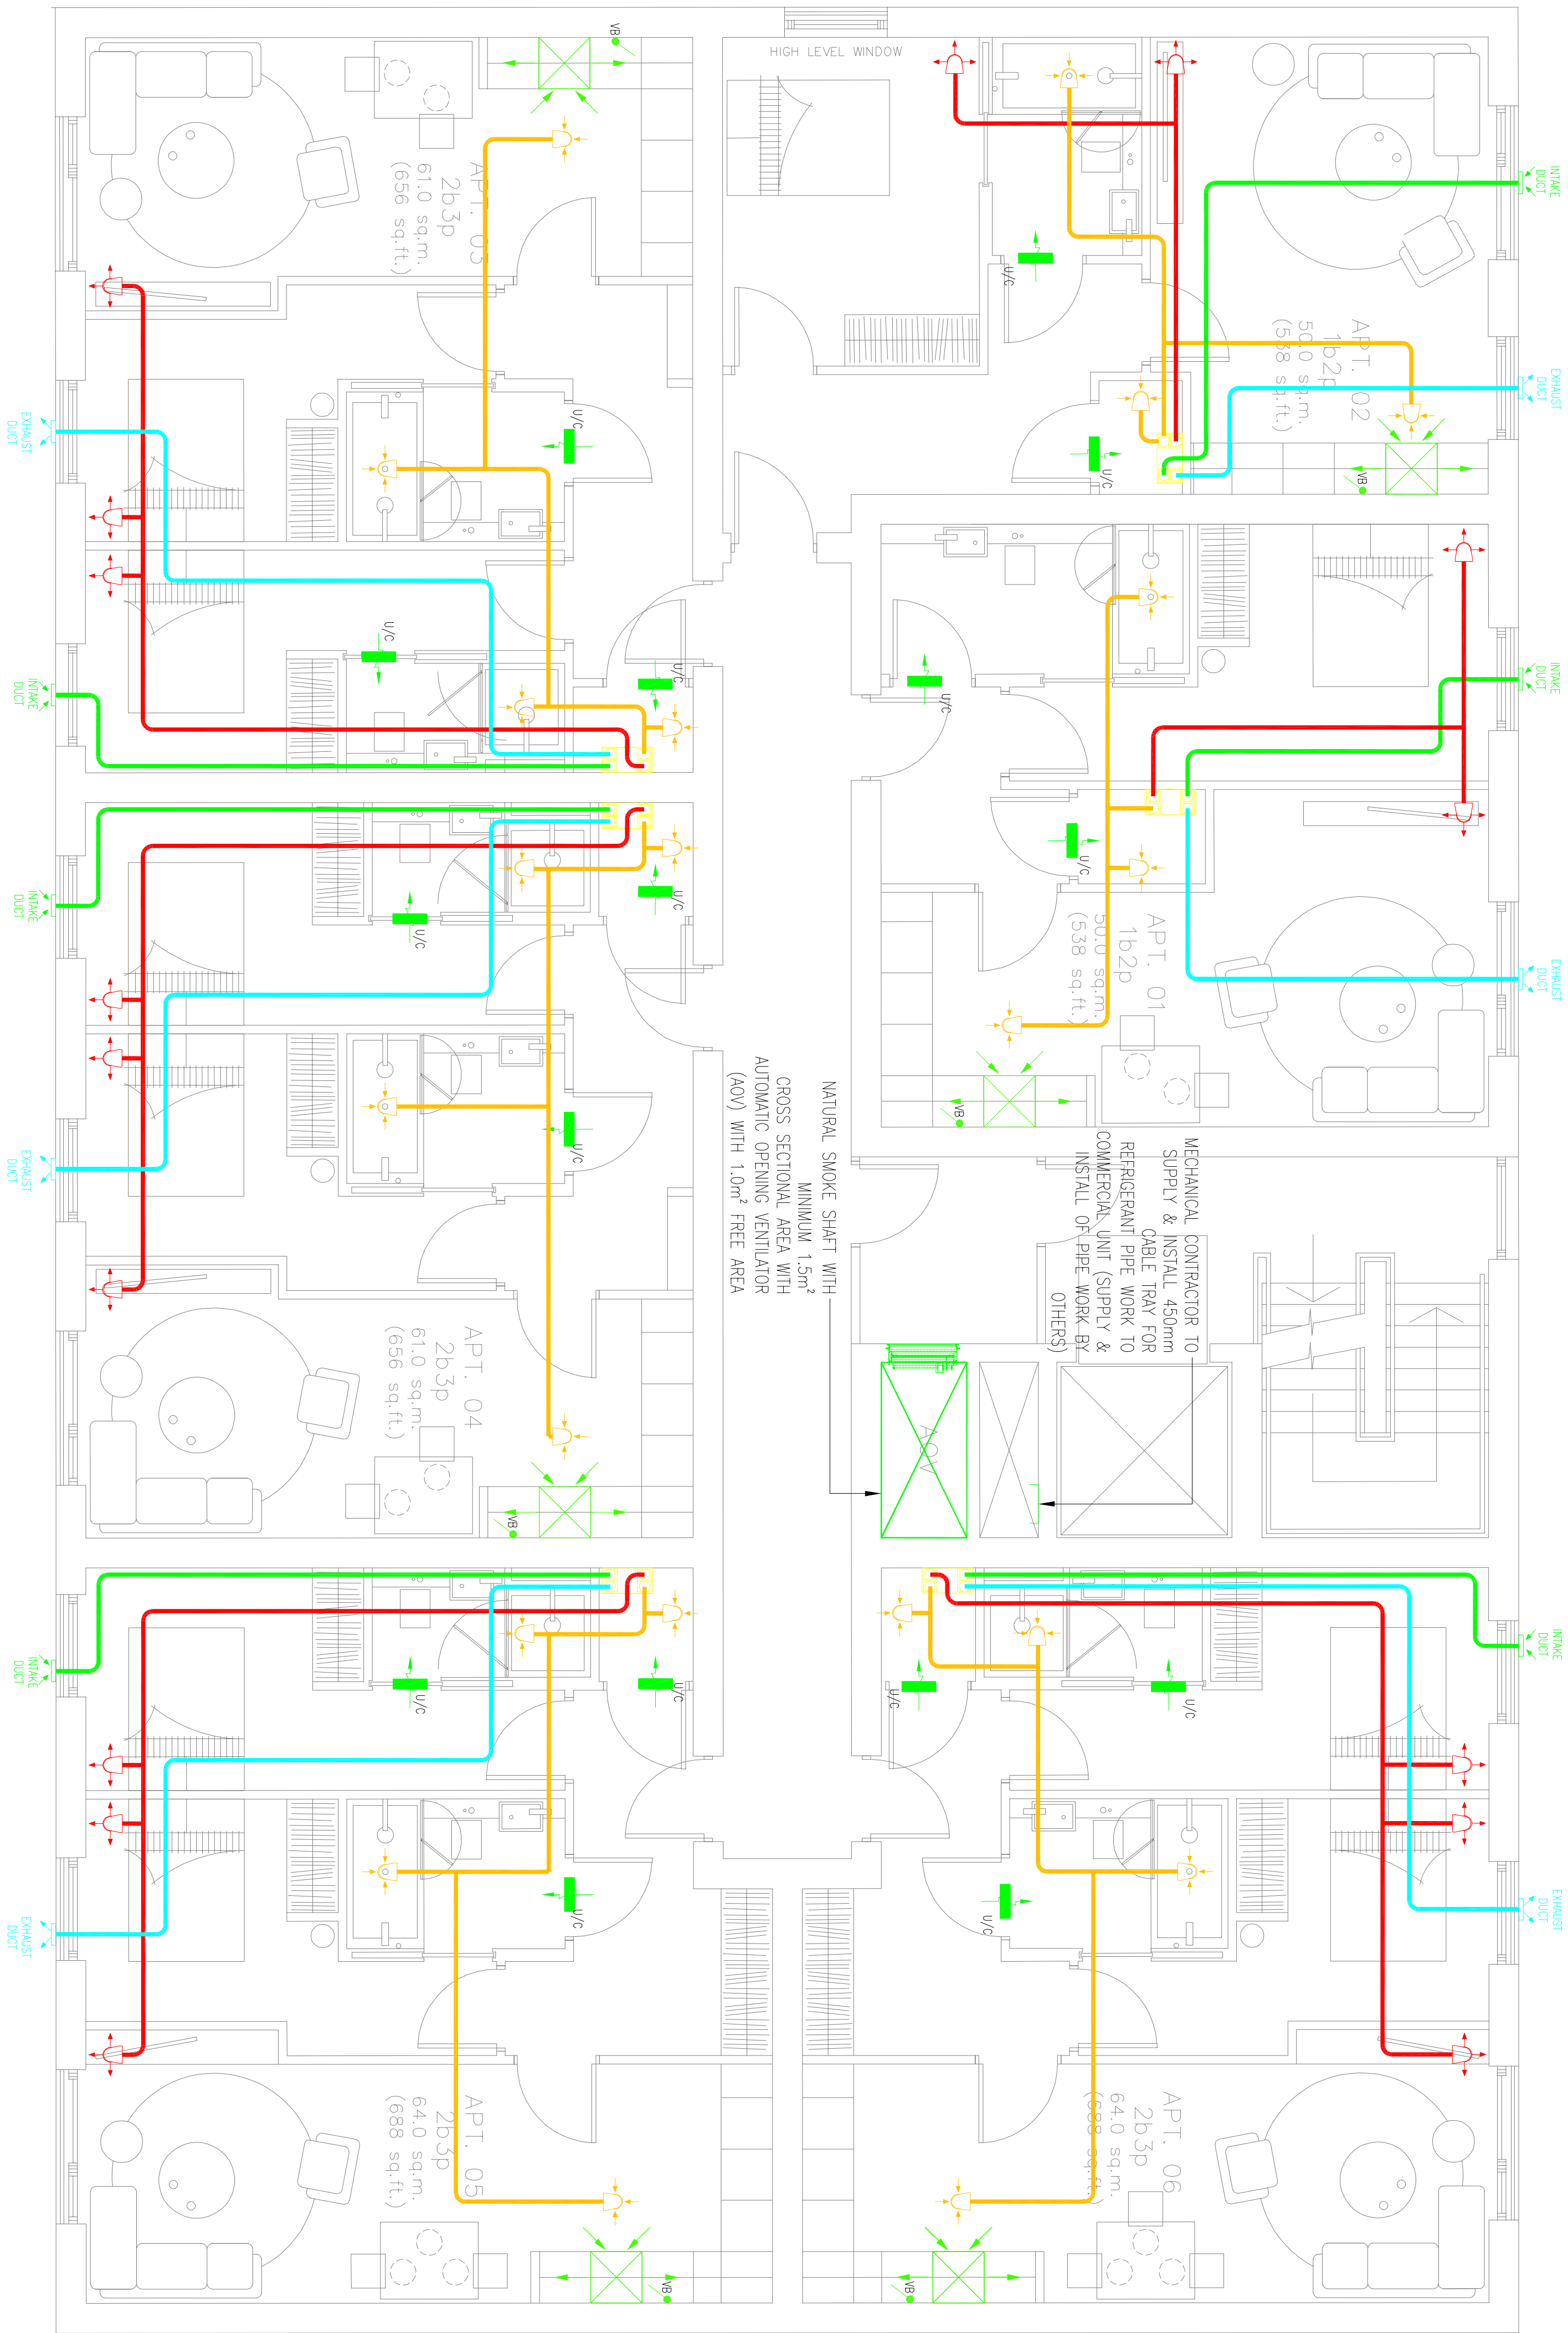

- Notes:**
1. This drawing is subject to copyright and is not to be reproduced in part or whole without approval.
 2. Do not scale this drawing - check all dimensions on site.
 3. This drawing shall be read in conjunction with the project specifications and all other contract documentation.
 4. All dimensions are in millimetres unless otherwise stated.
 5. Location of all equipment shown shall be confirmed/approved with the Client/Architect/Engineer prior to any installation.
 6. This drawing must be read in conjunction with Mechanical and Electrical performance specifications and all other drawings as issued by the Architect, Structural Engineer and M&E Energy and Consulting Engineers.
 7. The location of equipment is typical only. The Contractor shall perform all services to determine the exact quantity and agree the final locations with the Architect.
 8. This drawing shows the intended location of building services plant and service routes in such detail as to indicate the design. The drawing does not show all components that may be necessary to provide a full working installation.
 9. The positions of connection points, accessories and building services items are approximate and shown for guidance to assist during the tender process.
 10. Fully co-ordinated drawings: Construction drawings and Builderswork drawings shall be produced by the contractor. Order to circumstances shall the order drawings be used as installation drawings.

- LEGEND**
- SUPPLY DIFFUSER
 - EXTRACT VALVE
 - MHR UNIT AS VENT AXIA SENTINEL KINETIC FH OR EQUAL AND APPROVED
 - RE-CIRCULATION OVER HOB EXTRACT WITH LOCAL SPEED CONTROLLER AND CARBON FILTRATION
 - DOOR UNDER CUT
 - VENTILATION BOOST SWITCH
 - NATURAL VENTILATION VIA OPENABLE WINDOW/DOOR
 - FIRE COLLAR
 - ATTENUATOR
 - ALL SUPPLY & EXTRACT VALVES TO BE 30 MINUTE FIRE RATED
 - ALL DUCTWORK 204WD X 600P FLAT CHANNEL PVC DUCTWORK UNLESS OTHERWISE STATED

13	16.02.21	AOV AMENDED - BE COMMENT	BS
12	26.01.21	SPACE FOR ROOF PLANT SHOWN, CABLE TRAY ADDED	BS
11	22.01.21	TENDER ISSUE	BS
Rev.	Date	Substantive comments	By

watf
Energy & Consulting Engineers
40 KING STREET, MANCHESTER, M2 6BA
TEL: 0161 434 3103
EMAIL: office@watf.co.uk

Client:
GUSTAV BONNIER

Project:
PROPOSED DEVELOPMENT
PALATINE ROAD
NORTHERNDEN

Drawing Title:
MECHANICAL SERVICES
VENTILATION SERVICES
FIRST FLOOR

Drawn By:	BS	Checked By:	DW	Cost By:	SB
Scale:	1:50	Paper Size:	A1	Date Created:	22/12/2020
Drawing Number:	WECE-287-M-111			Drawing Revision:	T3