



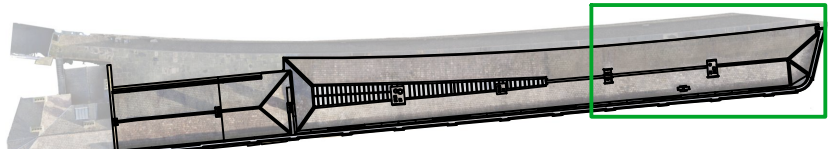


Note:
Do not scale from this drawing.
Dimensions are to be checked on site.
If in doubt please ask.

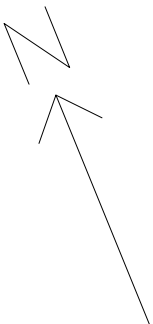

Key Plan
1:1000

Abbreviations Key

- RWP - Rain water pipe references
C - Chimney references
R - Roof references

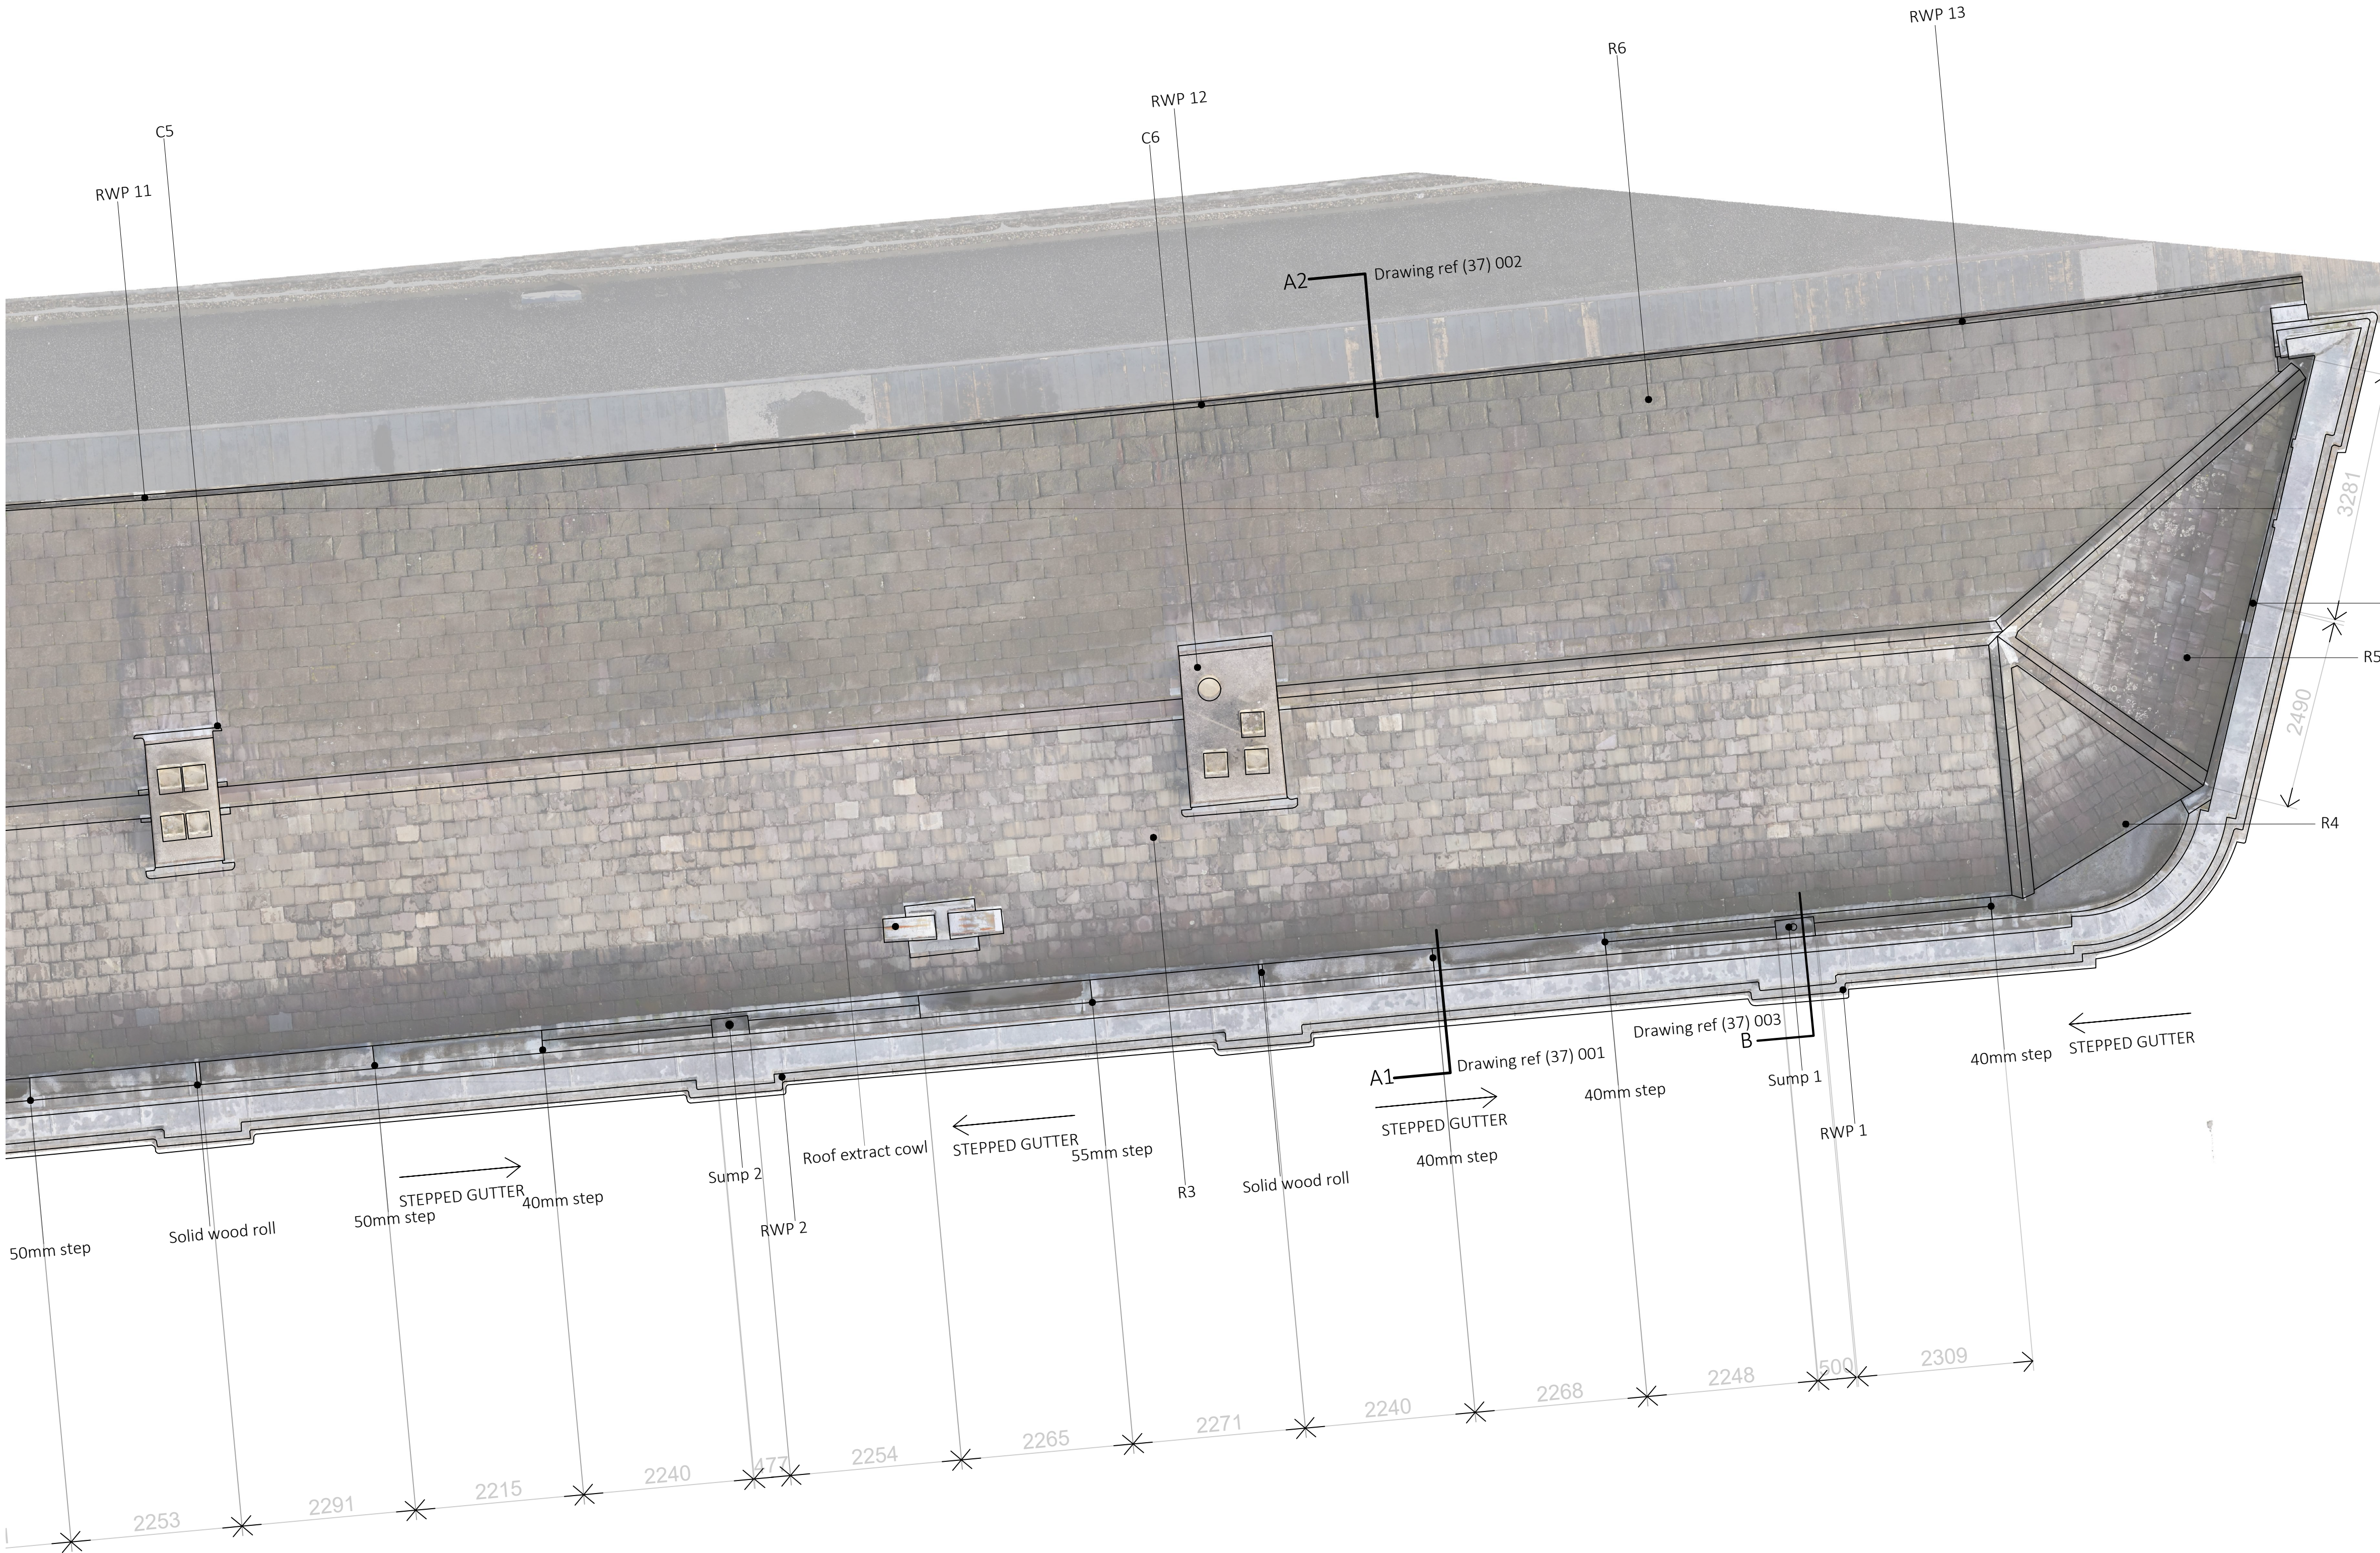

Rev Date/Intls Details

© The moral rights of the author are hereby asserted.
This drawing and design is the sole property of Buttress Ltd and must not be reproduced without permission.
Business Ltd is Registered in England and Wales: 536372

**SCIENCE
MUSEUM
GROUP**

Buttress

41, Bengal St
Manchester
M4 6AF

T 0161 236 3303
E contact@buttress.net
W www.buttress.net

Project Title	STATION BUILDING ROOF		
Client	SCIENCE AND INDUSTRY MUSEUM		
Location	MANCHESTER		
Drawing Title	Existing Roof Plan 01 Part ortho plan		
Date	11/11/20	Scale	1:50
Checked	AS	Orig Paper Size	A1
Status LBC			
Drawing ref	Job No	Drawing No	Revision
	9059	(01) 004	