



Revision	Description	Author	Checker	Date
P01	Issued for Planning	LB	PB	06/01/21

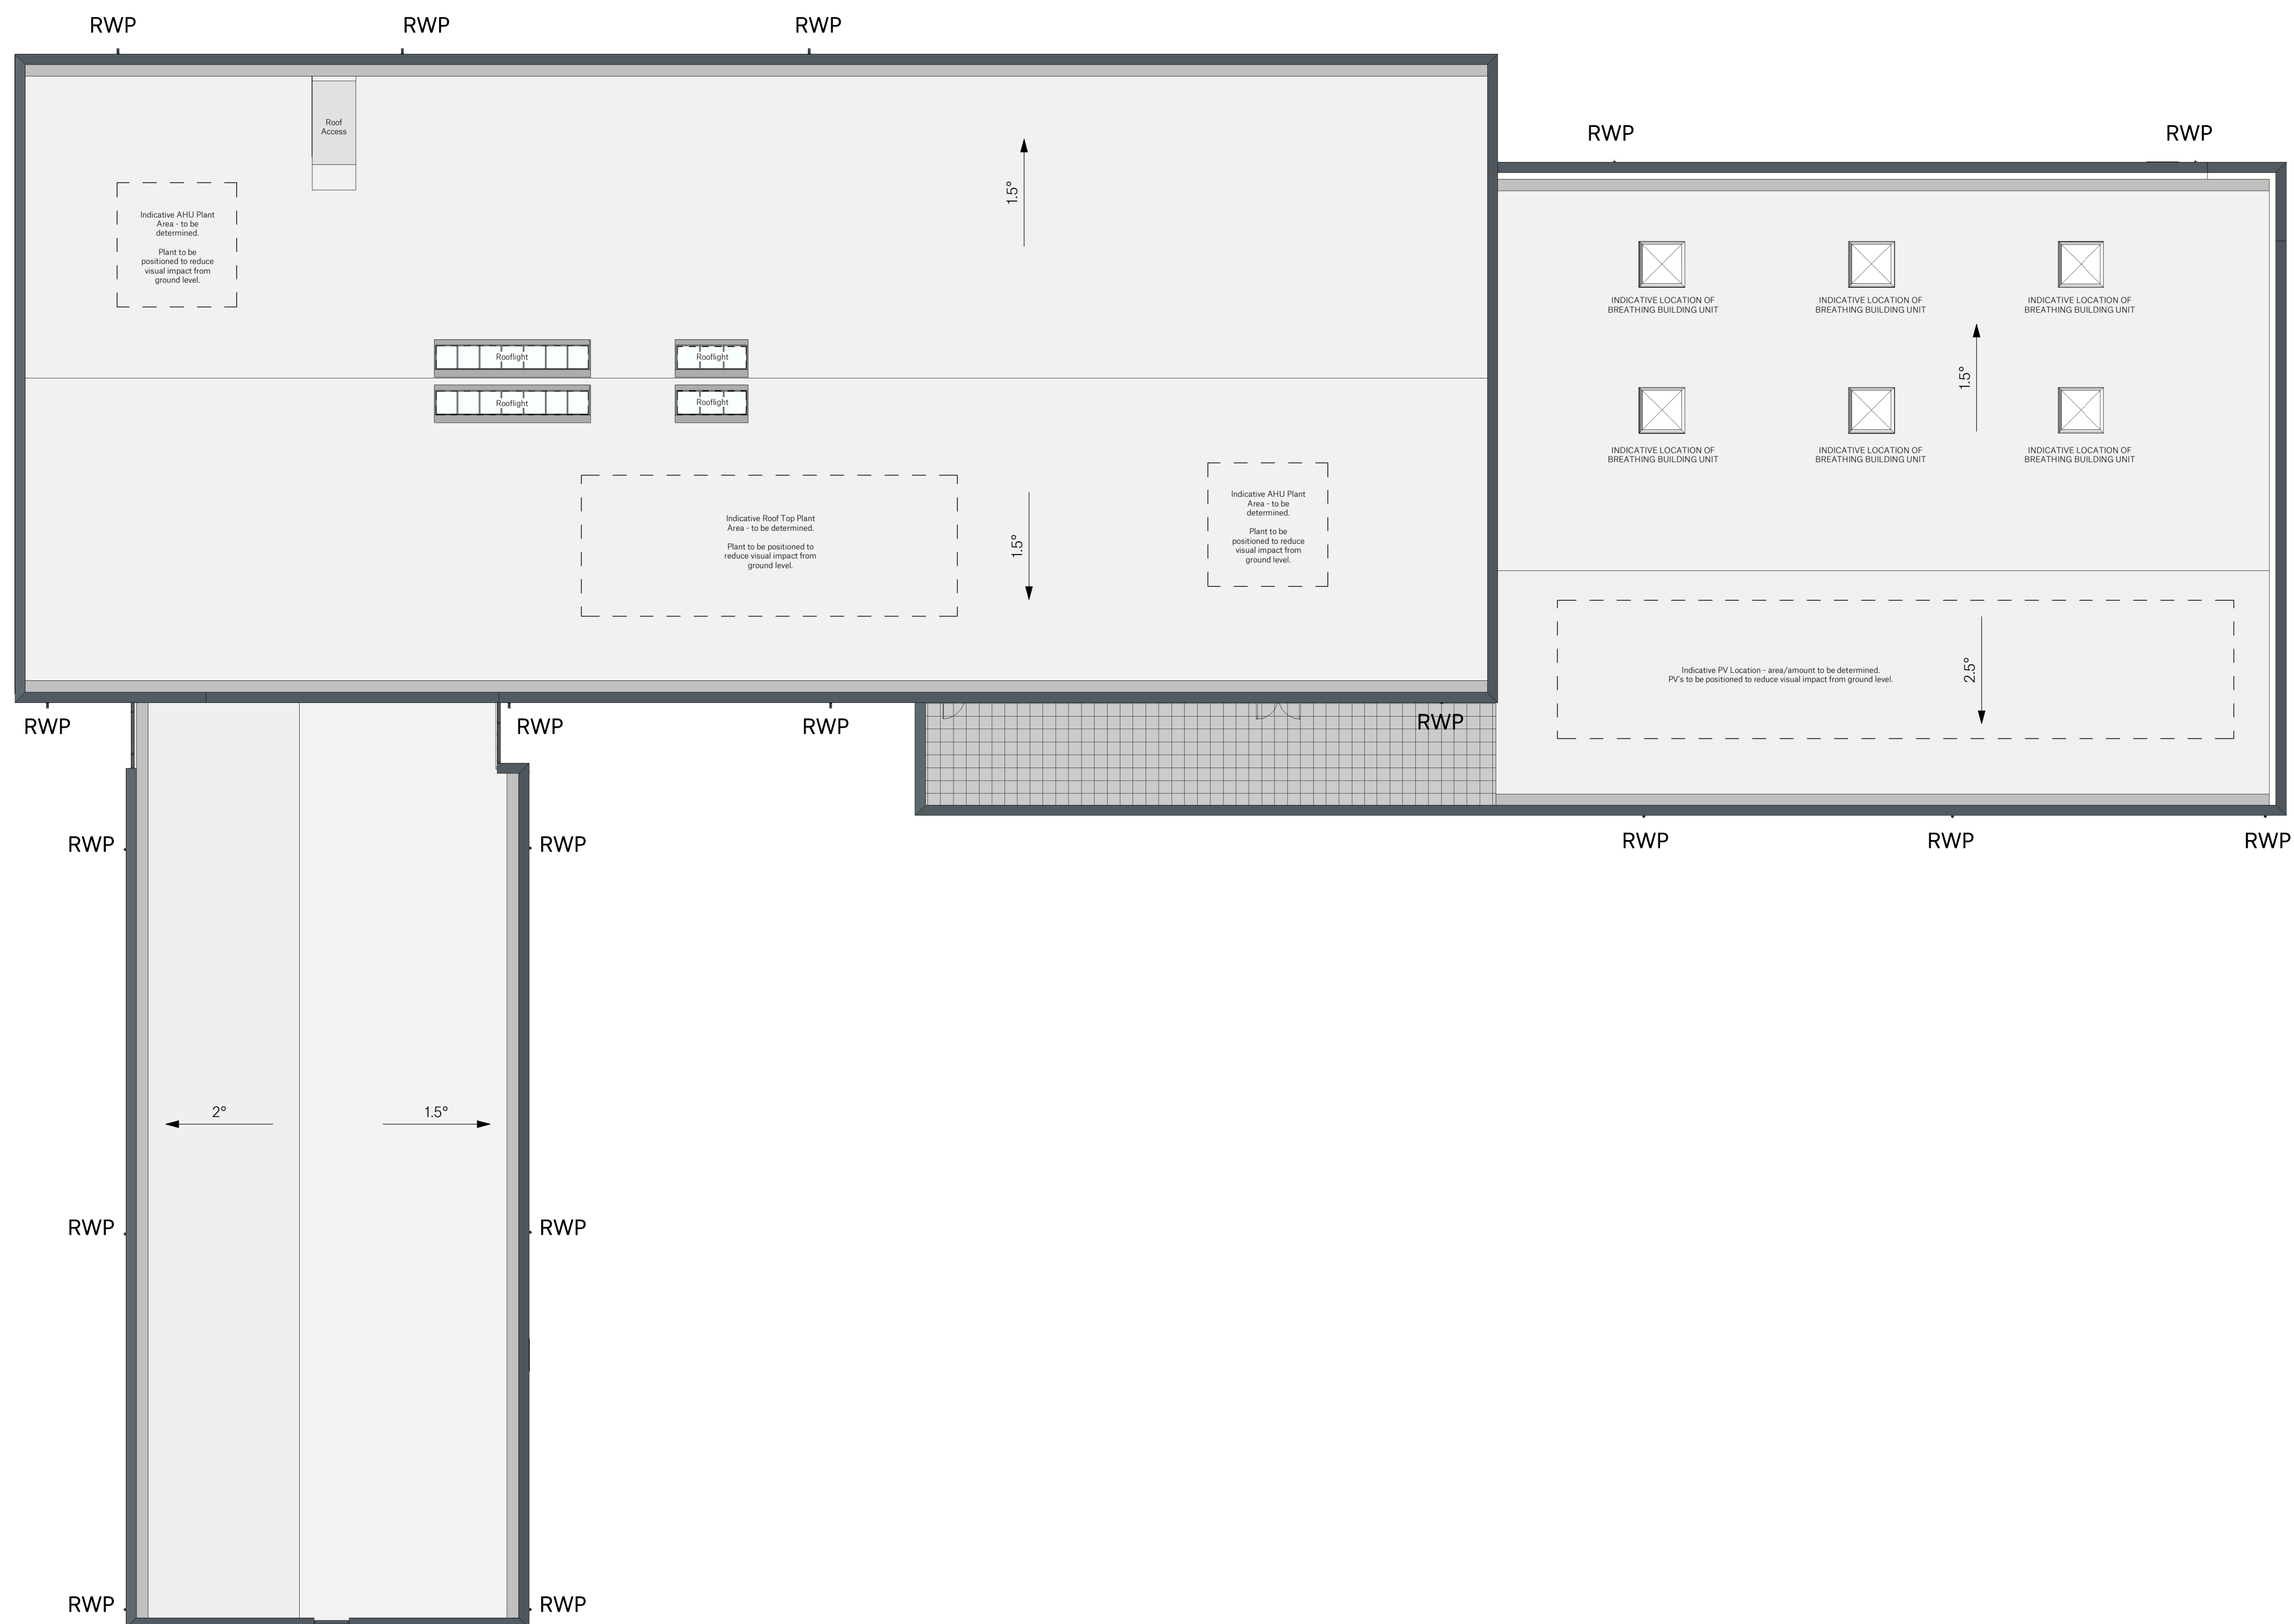

KEY:

-  - Denotes Single Ply Membrane Roof on lightweight Roof Structure
-  - Denotes Location of Gutter
- RWP** - Denotes indicative locations of Rain Water Pipe Outlets
- Quantity, size and location of RWP's to be confirmed by appointed roofing subcontractor.**

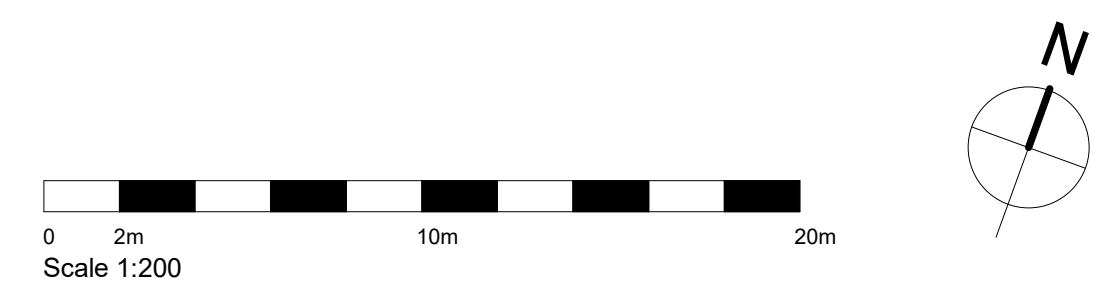

SPACE

**Sir Robert
McALPINE**

Spaceworks, Benton Park Road, Newcastle upon Tyne,
NE7 7LX
T: +44 (0)844 800 6660
www.spacearchitects.co.uk

 MANCHESTER
CITY COUNCIL

Project			
Belle Vue Co-op Academy, Manchester			
Drawing Title			
Proposed Roof Plan			
Project No.	Drawing No.	Status	Revision
08191	03-DR-A-01-0001		P01
File Reference:		08191-SPACE-03-DR-A-01-0001	
		Scale at A1	1 : 200