
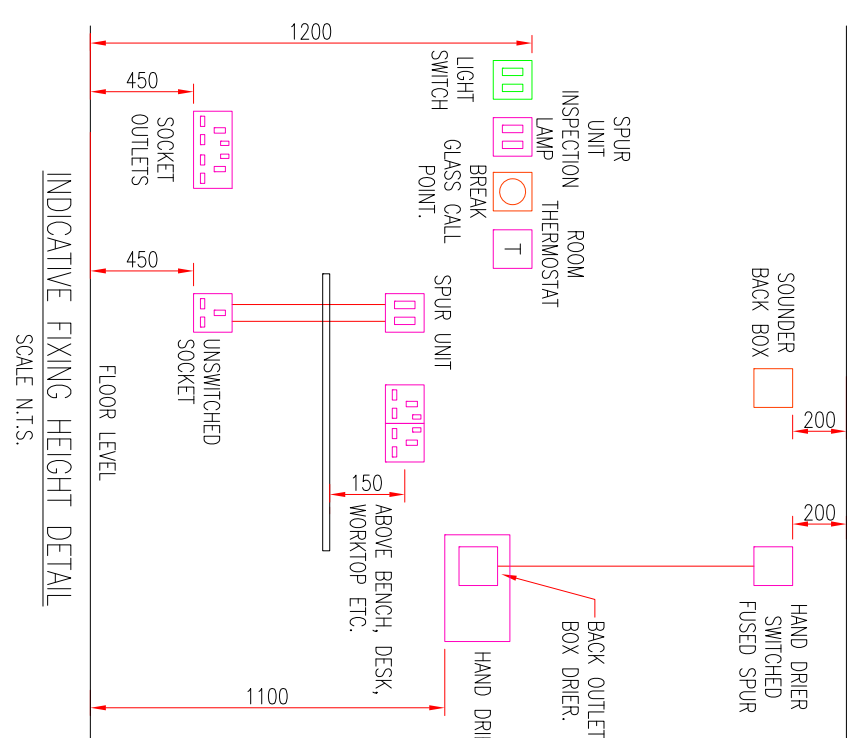


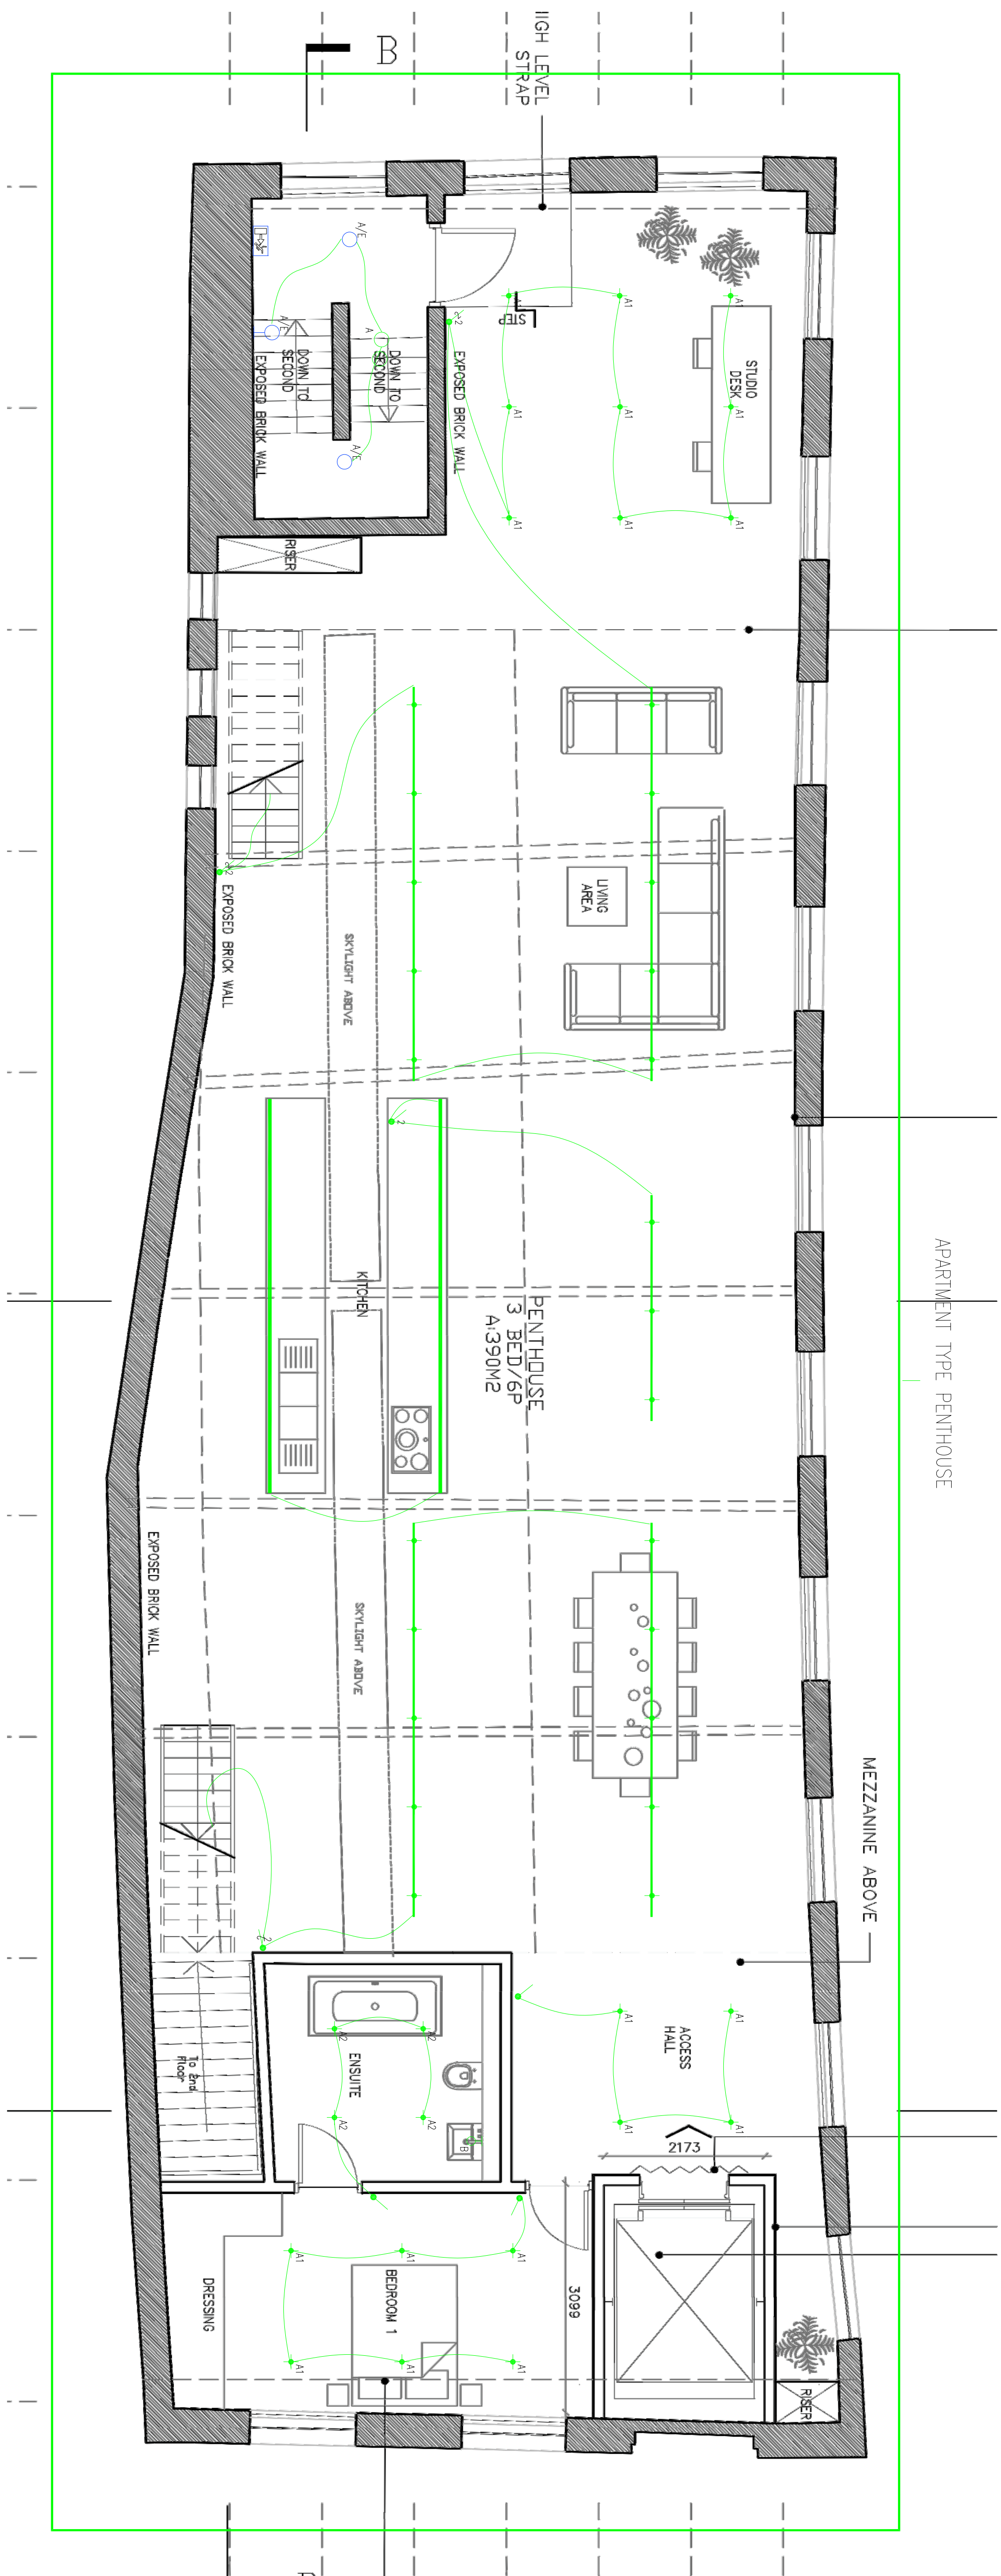

LEGEND (COMMUNAL):

34W LED SURFACE MOUNTED LINEAR LUMINAIRE C/W
IP65 RATED POLYCARBONATE DIFFUSER.
THORN LIGHTING - AQUAFORCE PRO S.

HO^D 11W LED EXTERNAL SURFACE MOUNTED BULKHEAD.
THORN LIGHTING - EYEKON LED.

THORN LIGHTING - EYEKON LED.

 EMERGENCY EXIT SIGN WITH ARROW LEGEND.
THORN LIGHTING - VOYAGER E EXIT SIGN.

 PRESENCE DETECTOR ON/OFF

 LONG RANGE MICROWAVE PRESENCE DETECTOR

TC EXTERNAL LIGHTING TIMECLOCK

ON/OFF KEY SWITCH FOR TESTING EMERGENCY

LEGEND (APARTMENTS):

ORLIGHT - ORL 1009-BL C/W 6W 3000K 38 DEGREE

A2 RECESSED LED DOWNLIGHT IP65 RATED
ORLIGHT - SHOWERSPOT W9016

8 MIRROR LIGHT C/W INTEGRAL SWITCH

JOINT DRILLING - CONVE

AURORA LIGHTING - KLAY 10W MULTI DIRECTIONAL LIGHT

LED STRIPLIGHT C/W CHANNEL WHERE REQUIRED

WILZIC ON - GILLIG WILZIC

WEAVER AND DUCRE – SARA ON TRACK

watf 

Energy & Consulting Engineers

40 KING STREET, MANCHESTER, M2 6BA
TEL: 0161 434 3103
EMAIL: office@wecoea.co.uk

Client: ARTISAN

Project:
CABLE STREET, ANCOATS
MANCHESTER

ELECTRICAL SERVICES
LIGHTING LAYOUT
THIRD FLOOR

Drawn By: KH	Checked By: DW
Scale: 1:50	Paper Size: A1
Drawing Number: WFCE-286-F-110	