



- APARTMENT SMALL POWER LEGEND:
- TV AERIAL POINT
 - SWITCHED SINGLE SOCKET OUTLET
 - SWITCHED DOUBLE SOCKET OUTLET
 - USB-DEKONTS SOCKET C/W USB OUTLETS
 - SWITCHED DOUBLE SOCKET OUTLET MOUNTED 150mm ABOVE KITCHEN COUNTER
 - SWITCHED FUSED CONNECTION UNIT
 - TR-TOWEL RAIL
 - HP-HEATING PROGRAMMER
 - SWITCHED FUSED CONNECTION UNIT AND LOW LEVEL SOCKET FOR Fridge
 - SWITCHED FUSED CONNECTION UNIT AND LOW LEVEL SOCKET FOR DISHWASHER
 - SWITCHED FUSED CONNECTION UNIT AND LOW LEVEL SOCKET FOR W/ASHENY/DRYER
 - SWITCHED FUSED CONNECTION UNIT AND LOW LEVEL SOCKET FOR OX-H FLEX OUTLET PLATE FOR HOB
 - SWITCHED FUSED CONNECTION POINT FOR OVEN AND FLEX OUTLET PLATE FOR HOB
 - ASA COOKER CONTROL UNIT C/W 13A SINGLE SOCKET + LED DOWN LIGHT 1200mm ABOVE KITCHEN COUNTER FOR ISOLATION OF OX-H AND HOB
 - DUAL RCD RESIDENTIAL CONSUMER UNIT
 - TV AERIAL POINT
 - SATELLITE TV POINT
 - BT MASTER TELEPHONE OUTLET, ONT & BBU
 - CAT 6 DATA OUTLET
 - SHOWER SOCKET OUTLET
 - INCOMING ELECTRIC METER
 - UNSWITCHED FUSED CONNECTION UNIT FOR VIDEO DOOR ACCESS INTERCOM UNIT C/W REMOTE RELEASE FUNCTION
 - FLUORESCENT LIGHTING
 - HEATING PROGRAMMER
 - 4 COMPARTMENT FLOOR BOX C/W 2 NO TWIN SWITCHED SOCKETS, 1 NO TV OUTLET, 2 NO R45 SOCKETS, 1 NO SATELLITE SOCKET
 - 3 COMPARTMENT FLOOR BOX C/W 2 NO TWIN SWITCHED SOCKETS & 2 NO R45 SOCKETS
 - FLOOR GROUND C/W SINGLE SWITCHED SOCKET OUTLET
 - TV AERIAL POINT
 - SATELLITE TV POINT
 - BT MASTER TELEPHONE OUTLET, ONT & BBU
 - CAT 6 DATA OUTLET
 - SHOWER SOCKET OUTLET
 - INCOMING ELECTRIC METER
 - UNSWITCHED FUSED CONNECTION UNIT FOR VIDEO DOOR ACCESS INTERCOM UNIT C/W REMOTE RELEASE FUNCTION
 - FLUORESCENT LIGHTING
 - HEATING PROGRAMMER
 - 4 COMPARTMENT FLOOR BOX C/W 2 NO TWIN SWITCHED SOCKETS, 1 NO TV OUTLET, 2 NO R45 SOCKETS, 1 NO SATELLITE SOCKET
 - 3 COMPARTMENT FLOOR BOX C/W 2 NO TWIN SWITCHED SOCKETS & 2 NO R45 SOCKETS
 - FLOOR GROUND C/W SINGLE SWITCHED SOCKET OUTLET

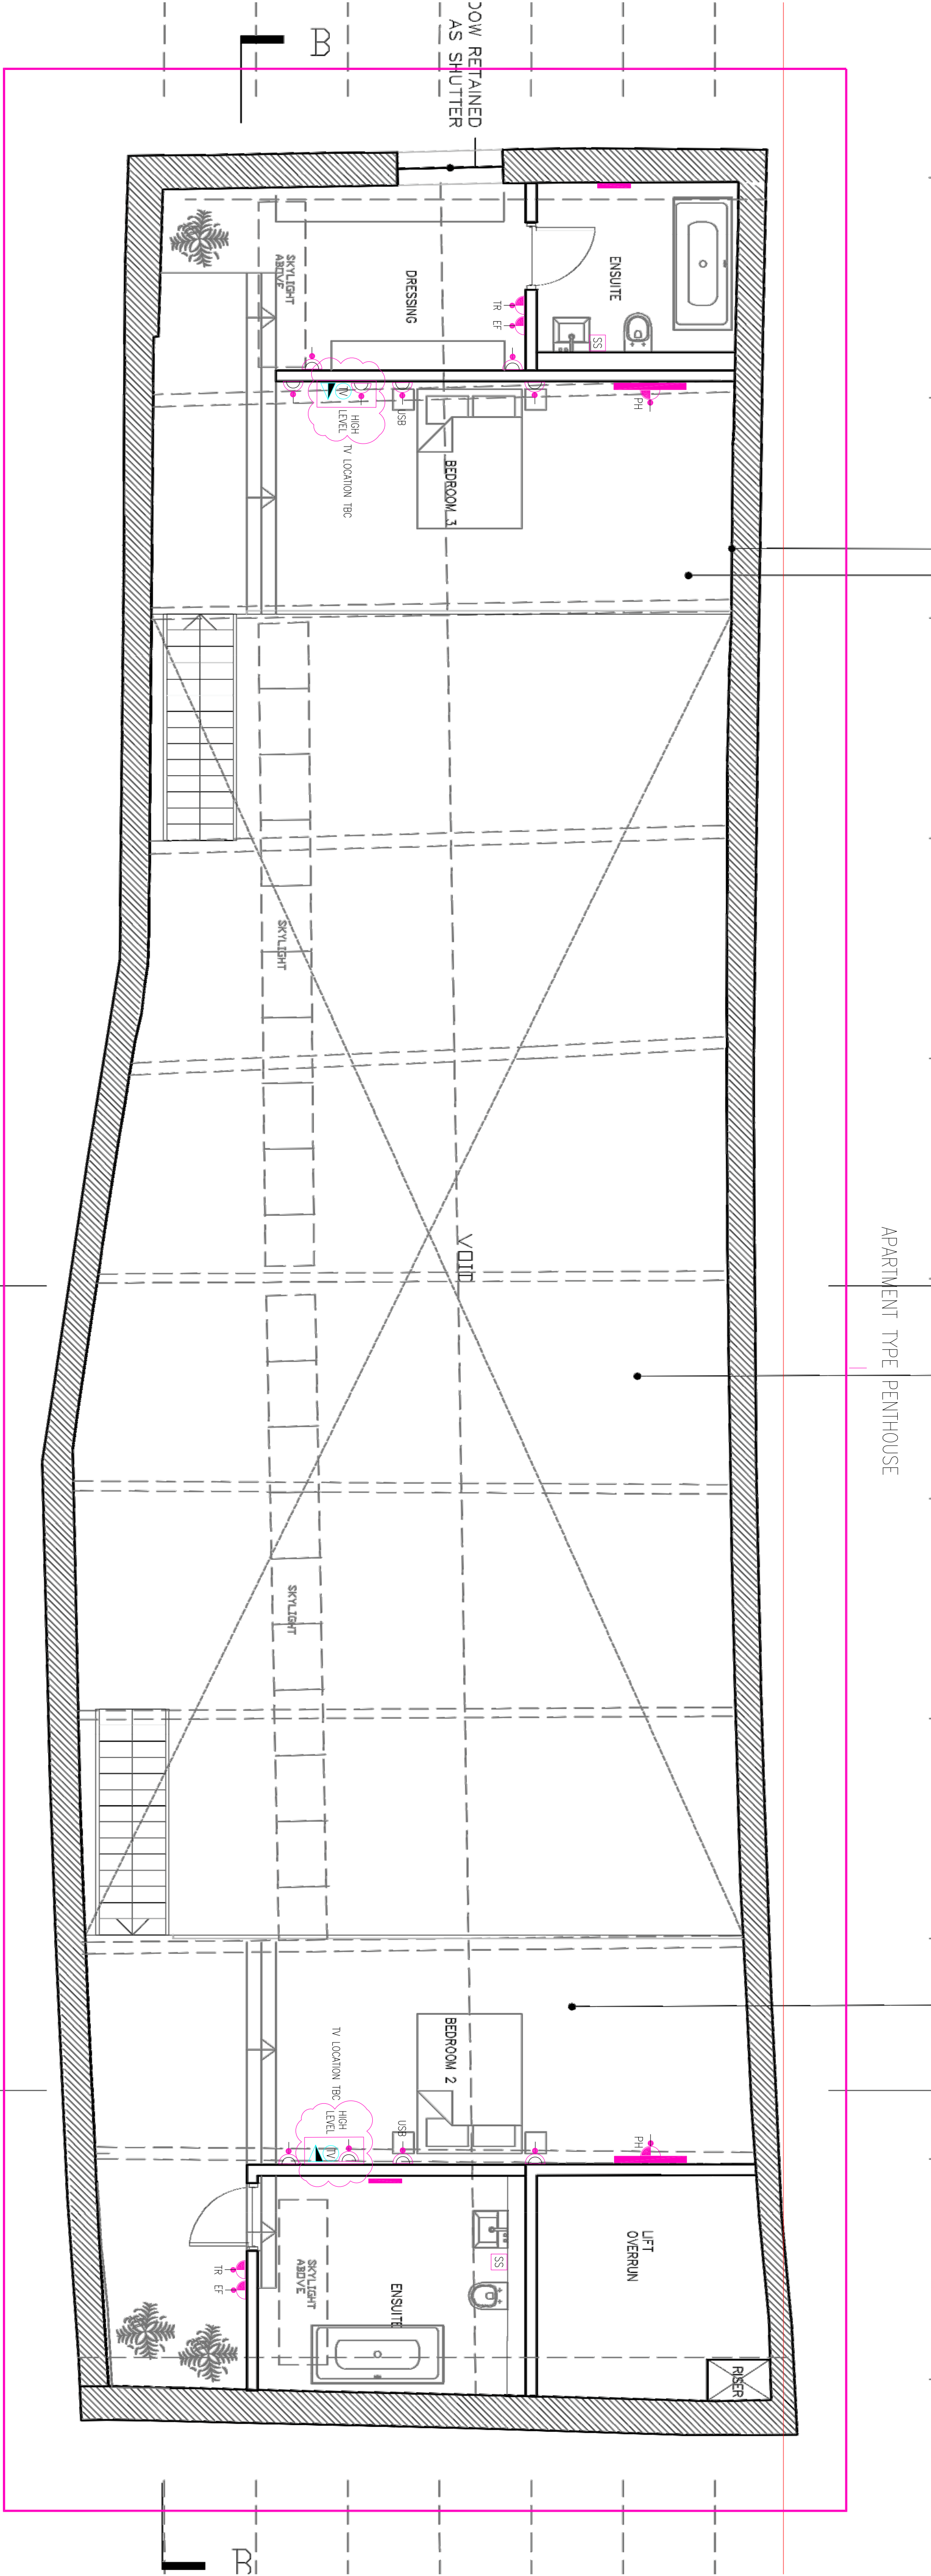

WE&CE DRAWINGS ARE FOR DESIGN INTENT ONLY. THE MEP CONTRACTOR IS RESPONSIBLE FOR THE FINAL INSTALLATION DRAWINGS INCLUDING ALL SETTING OUT, DIMENSIONS, ALIGNMENT AND COORDINATION WITH THE ARCHITECT'S REQUIREMENTS

- Notes:
- This drawing is subject to copyright and is not to be reproduced in part or whole without approval.
 - Do not scale this drawing - check all dimensions on site.
 - This drawing shall be read in conjunction with the project specifications and all other contract documentation.
 - All dimensions are in millimetres unless otherwise stated.
 - Location of all equipment shown shall be confirmed/approved with the Client/Architect/Engineer prior to any installation.
 - This drawing must be read in conjunction with Mechanical and Electrical performance specifications and all other drawings as issued by the Architect, Structural Engineer and Wat Energy and Consulting Engineers.
 - The location of equipment is typical only. The Contractor shall perform all calculations to determine the exact quantity and agree the final locations with the Architect.
 - This drawing shows the intended location of building services plant and service routes in such detail as to indicate the design. The drawing does not show all components that may be necessary to provide a full working installation.
 - The positions of connection points, accessories and building services items are approximate and shown for guidance to assist during the tender process.
 10. Fully co-ordinated drawings Construction drawings and Builderswork drawings shall be produced by the contractor. Under no circumstances shall the tender drawings be used as installation drawings.

- COMMUNAL SMALL POWER LEGEND:
- DOUBLE SWITCHED SOCKET OUTLET
 - SWITCHED FUSED CONNECTION UNIT
 - PH-PANEL HEATERS
 - EF-EXTRACT FAN
 - UN-SWITCHED FUSED CONNECTION UNIT
 - FAP-FIRE ALARM PANEL
 - DISTRIBUTION BOARD
 - SINGLE PHASE CONSUMER UNIT
 - TELEPHONE OUTLET
 - R45 DATA OUTLET
 - SWITCHED ISOLATOR
 - ELECTRIC PANEL HEATERS

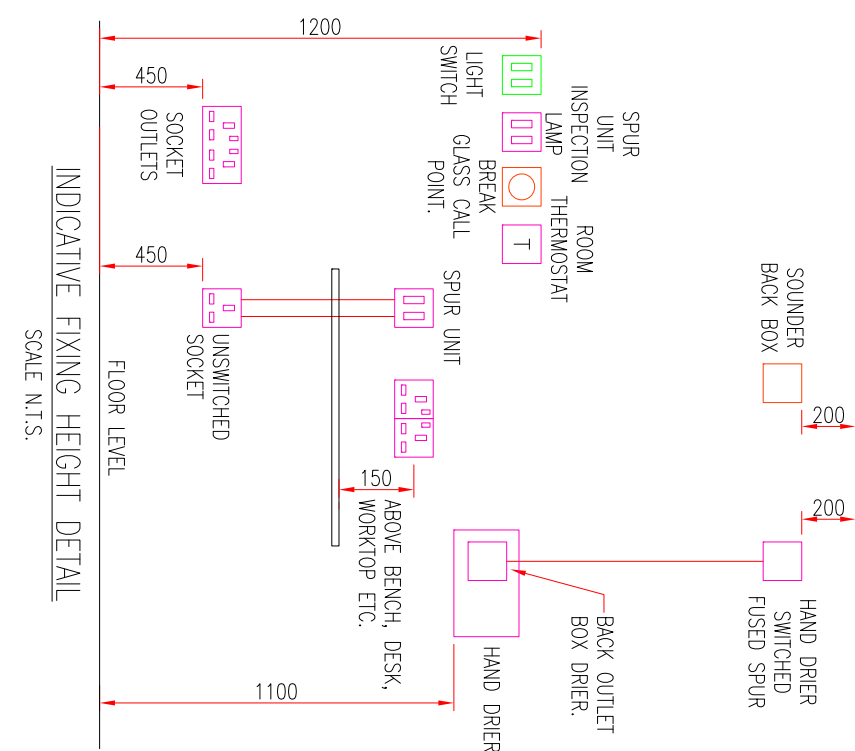

Wat
Energy & Consulting Engineers

40 KING STREET, MANCHESTER, M2 6BA
TEL: 0161 434 3103
EMAIL: office@wece.co.uk

Client:
ARTISAN

Project:
**CABLE STREET ANCOATS
MANCHESTER**

Drawing Title:
**ELECTRICAL SERVICES
SMALL POWER & COMMUNICATIONS LAYOUT
MEZZANINE FLOOR**

Drawn By: KH	Checked By: DW	Cad By: KH
Scale: 1:50	Paper Size: A1	Date Created: 08 / 04 / 2019
Drawing Number: WECE-286-E-105		Drawing Revision: T1