


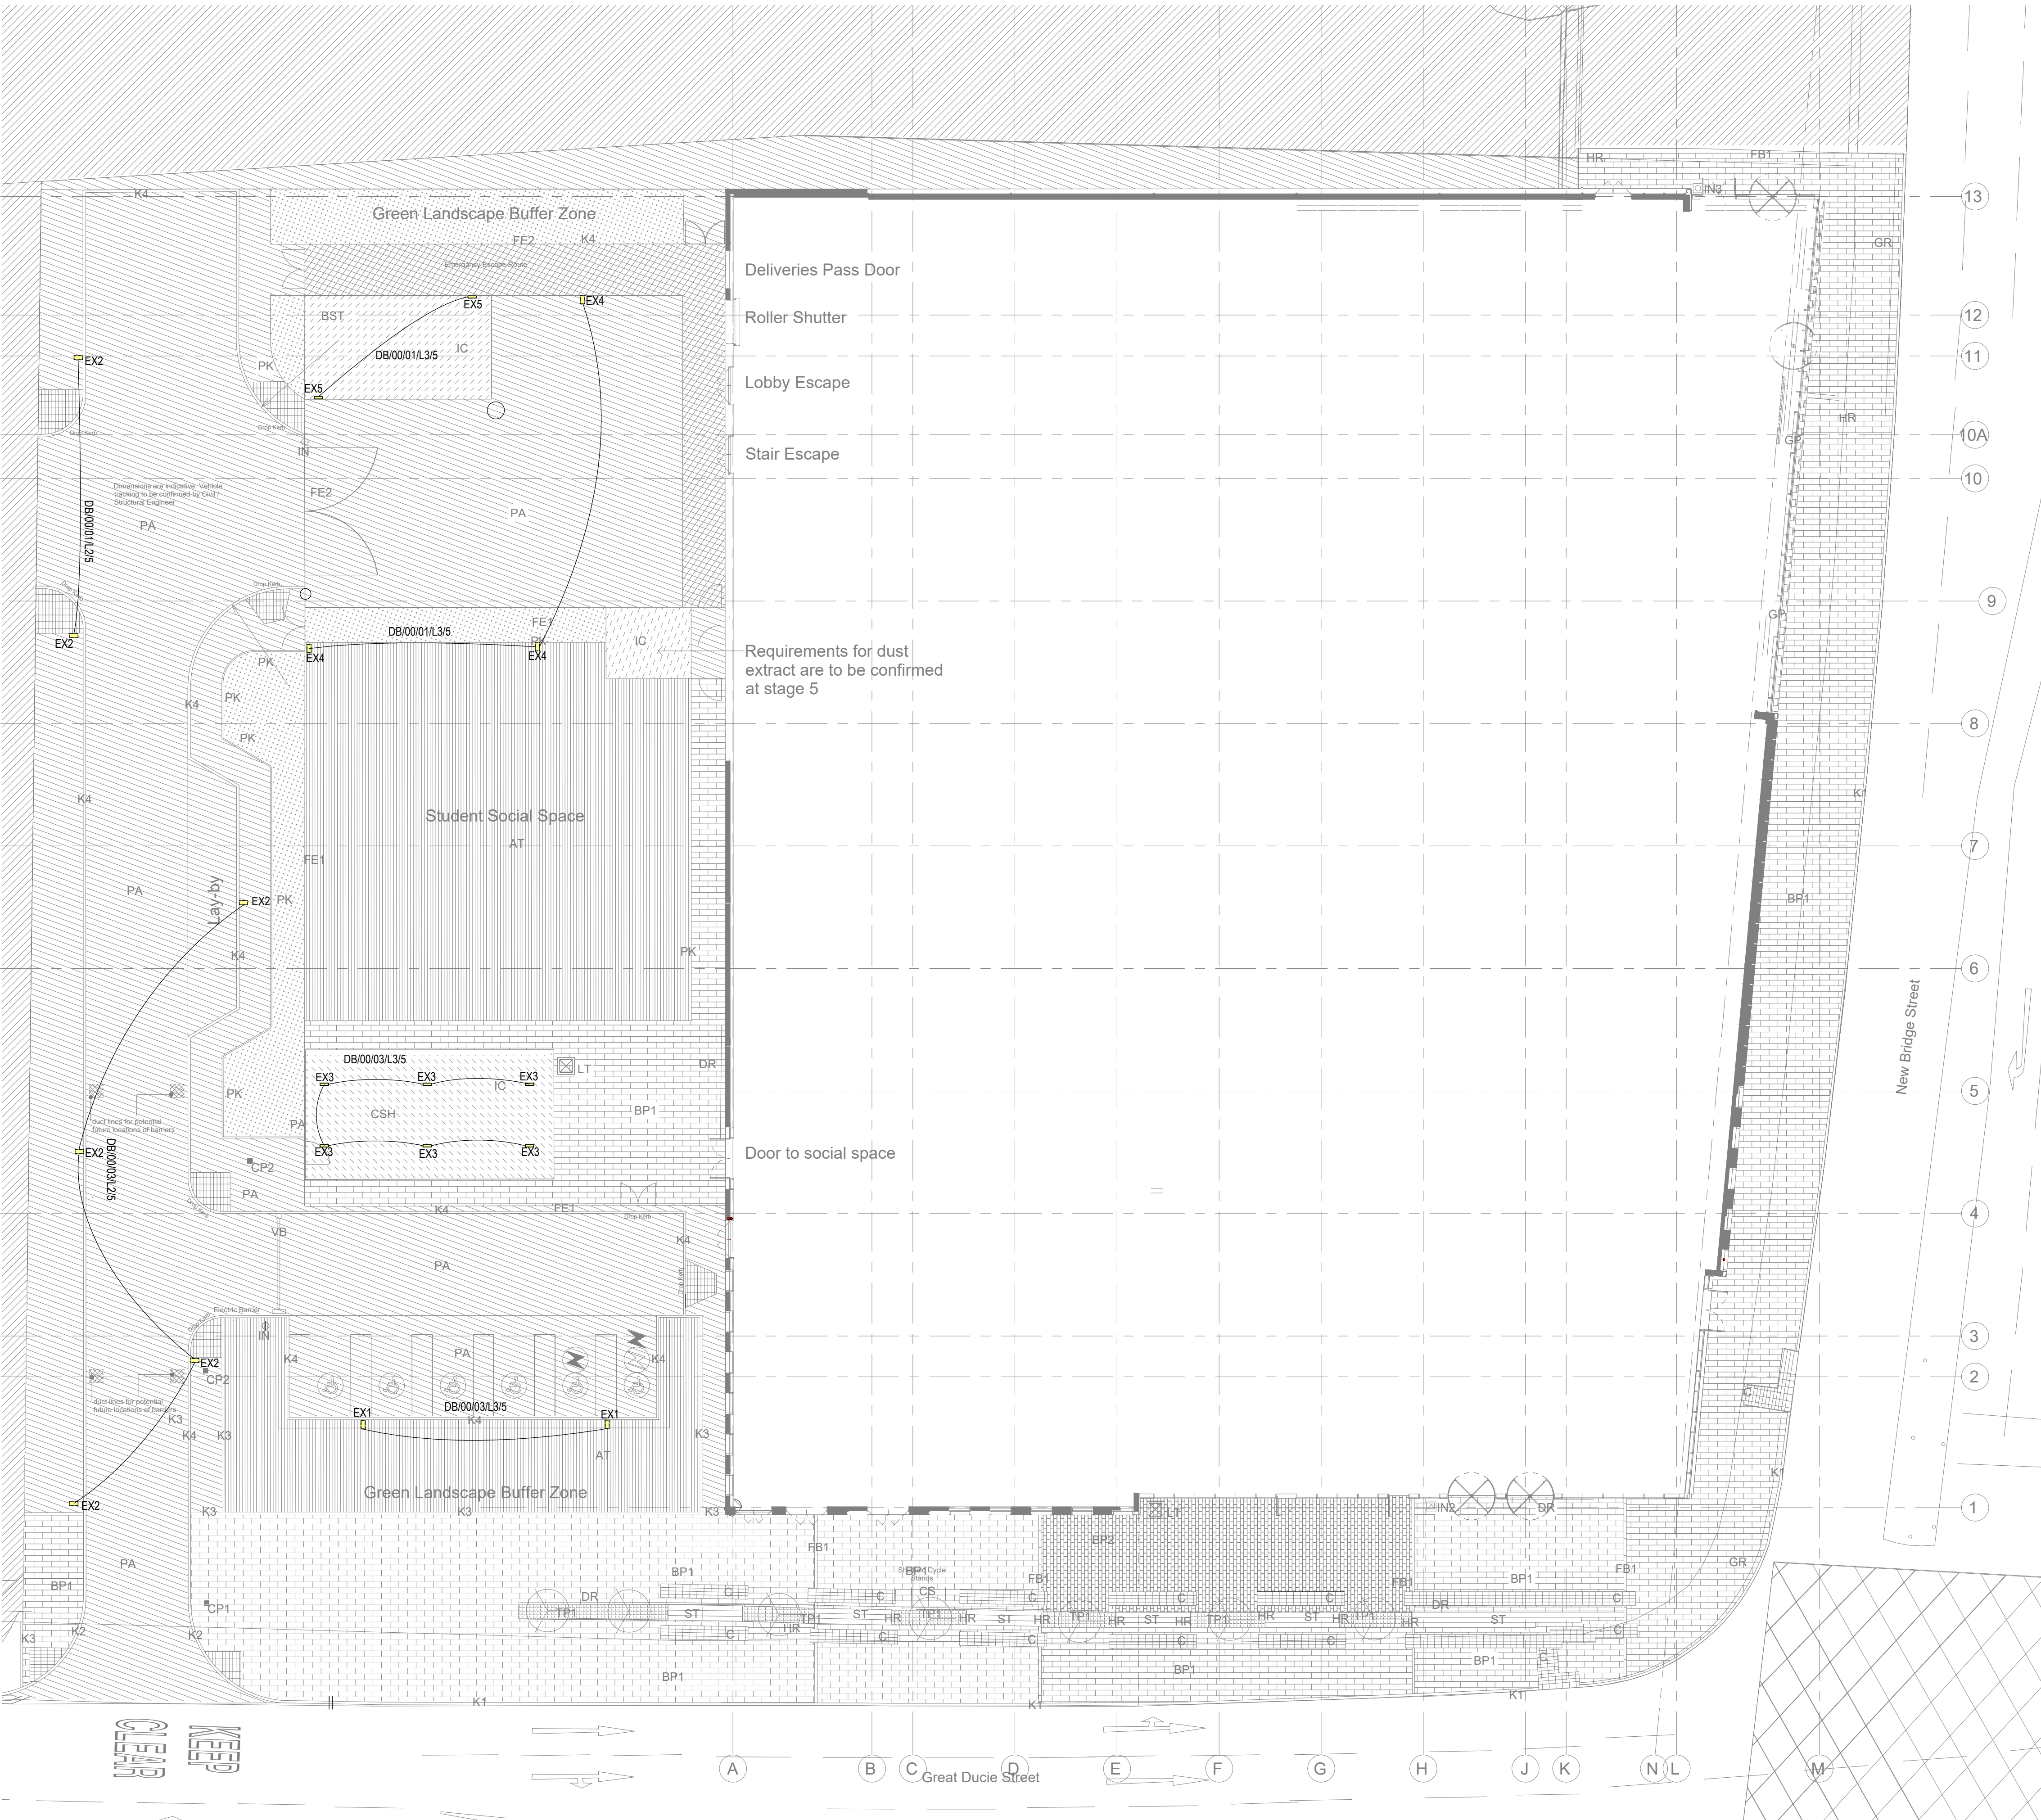

DO NOT SCALE OFF THIS DRAWING

BUILDING OUTLINE DRAWINGS

ARCHITECT / CONSULTANT

DRAWING No.

REV

NOTES:

1. DO NOT SCALE OFF THIS DRAWING

2. THIS DRAWING REPRESENTS DESIGN INTENT ONLY

3. ALL ELECTRICAL INSTALLATIONS SHALL BE INSTALLED IN LINE WITH THE REQUIREMENTS OF BS7671

4. NON BUILDING MOUNTED EXTERNAL LIGHTING SHALL BE CONTROLLED VIA A PHOTOCELL AND TIME CLOCK. BUILDING MOUNTED PHOTOCELL LOCATION TO BE AGREED WITH THE ARCHITECT

5. REFER TO EXTERNAL LIGHTING LUMINAIRE SCHEDULE FOR DETAILS OF EXTERNAL LUMINARIES

LEGEND

EX1

6M COLUMN WHITECROFT 69W LED (LEVH24KGF)

EX2

6M COLUMN WHITECROFT 42W LED (LEVH14KG)

EX3

WHITECROFT ACL EXTREME 28W LED (AXLH424K)

EX4

WHITECROFT EUROFLOOD MIDI 81W LED (EFLH24KG)

EX5

WHITECROFT CENTURION L65 12W LED (CENLH14K)

P01

16/10/20

PRELIMINARY ISSUE

RC

PMcG

Rev

Date

Description

Drn

Chkd

PRELIMINARY

Client.
WILLMOTT DIXON

Project.
MANCHESTER COLLEGE
CITY CAMPUS

Description.
EXTERNAL LIGHTING

Scale. 1:200

A1

Date. OCTOBER 20

Drawn By. RC

Checked. PMcG

DRAWING No. CC-BAF-ZZ-ZZ-DR-MEP-8701

Rev. P01

Briggs & Forrester
ENGINEERING SERVICES LTD

Briggs & Forrester Engineering Services Ltd
Cinnabar Court, 5250 Daresbury Park
Daresbury, Warrington WA4 4GE
www.briggsandforrester.co.uk Tel: 01928 798279

This drawing is copyright and may not be reproduced either in part or full without written permission from Briggs & Forrester Engineering Services Ltd

File:S:\Projects\3255 Manchester College City Campus\09 Drawings\00 BEMS Drawings\01 Design Drawings\01 External Services\CC-BAF-ZZ-ZZ-DR-MEP-8701-P01 - External Lighting Layout.dwg