


- notes:
- DO NOT SCALE FROM THIS DRAWING - USE FIGURED DIMENSIONS ONLY.
 - TO BE READ IN CONJUNCTION WITH ALL OTHER CONSULTANTS / SPECIALISTS DRAWINGS. REPORT ANY DISCREPANCIES BEFORE AFFECTED WORK COMMENCES.
 - ALL SETTING OUT DIMENSIONS TO BE CHECKED ON SITE BY CONTRACTOR BEFORE WORK COMMENCES.

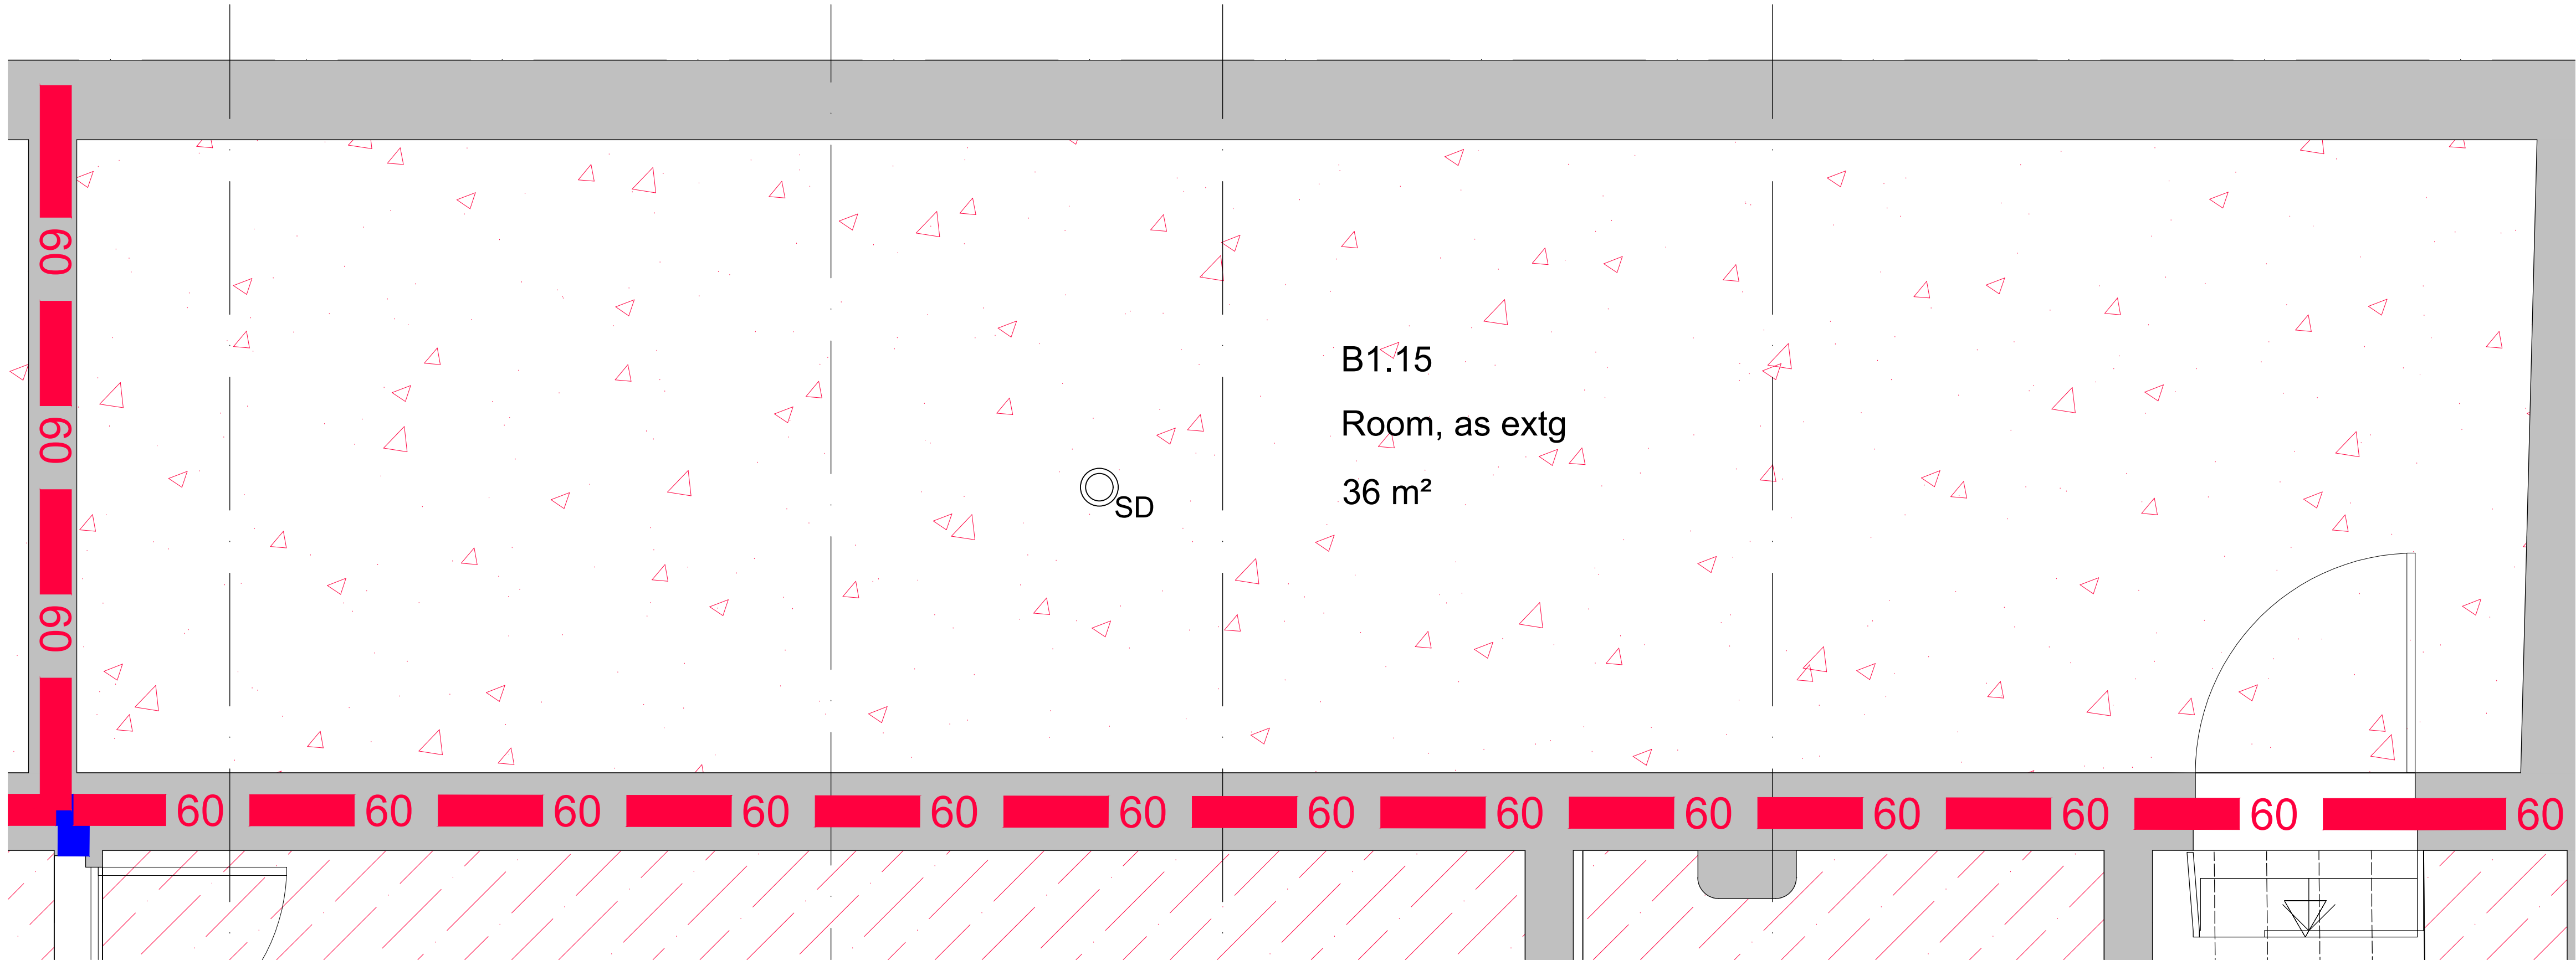


PLAN
1:20



KEY

KEY

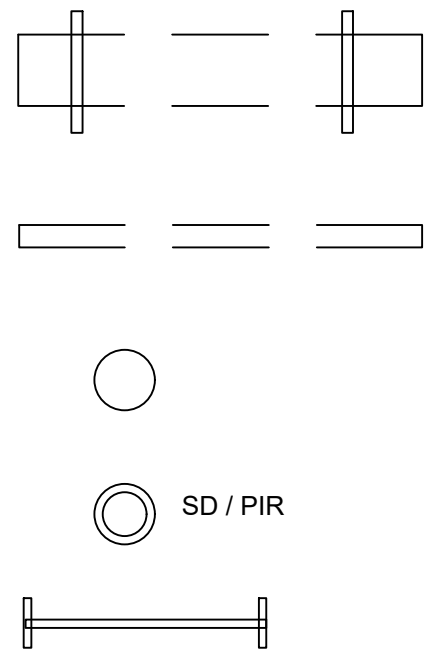

SERVICES ON EITHER INDIVIDUAL SCREW RODS OR UNISTRUT.

SERVICES ON SUSPENDED BASKET OR TRAY


CABLE OR PIPE PENETRATIONS THROUGH SLAB

SMOKE OR PIR DETECTOR


SURFACE FIXED LIGHTING WITH CONDUIT

NOTES:

- ALL SMOKE DETECTORS WILL REQUIRE TEMPORARY REMOVAL FOR REFITTING AGAINST NEW CEILING LINING.
- UNI STRUT AND SCREW RODS TO REMAIN IN PLACE FOR FITTING NEW CEILING AROUND WITH FR SEALANT AROUND RODS.
- NEW WALLS AROUND SERVICES WILL REQUIRE SEALING WITH ABLATIVE BATTS AND FR SEALANT.
- ALL ELECTRICAL PENETRATIONS (UPTO 40MMØ I.E DATA, SMOKE LIGHTING) AROUND EXISTING SERVICES WILL REQUIRE FR SEALANT .
- ALL MECHANICAL SERVICES ABOVE 40MM Ø (I.E. HEATING PIPES, SOIL/RWP PIPES) WILL REQUIRE A FR60 FIRE COLLAR FITTING IN THE NEW CEILING.

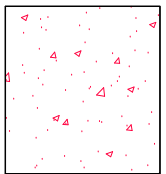

TYPE 3
AREA OF ASSUMED FILLER JOIST FLOOR CONSTRUCTION IN UNSTABLE CONDITION TO BE REPLACED WITH NEW SOLID FLOOR AND SUPPORTS - TO BE DEALT WITH UNDER A SEPARATE CONTRACT .

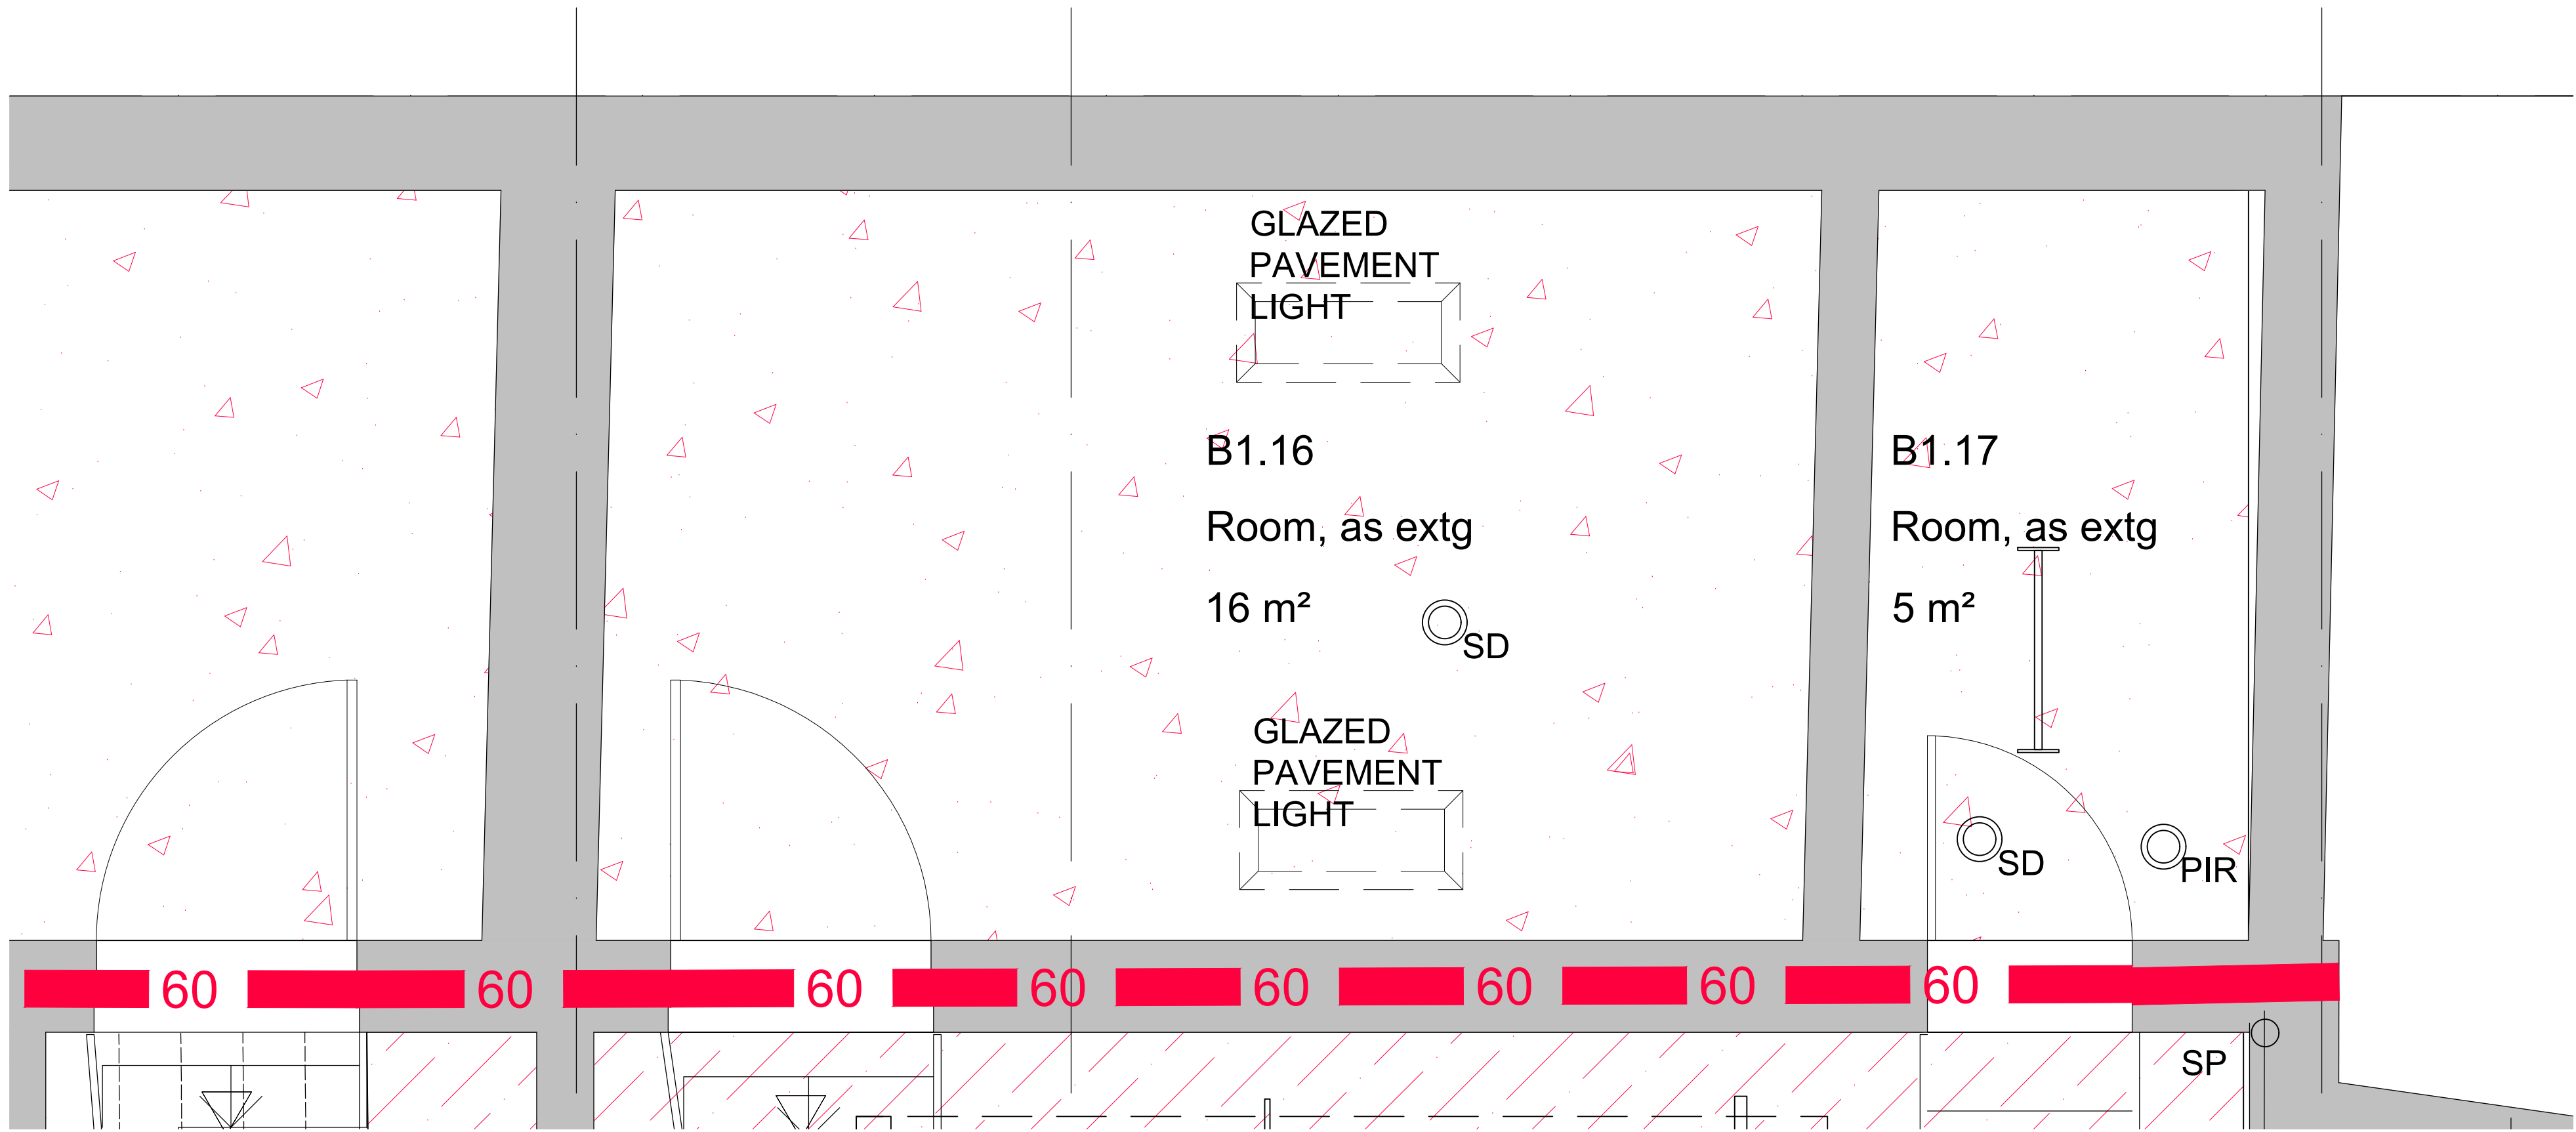

PLAN
1:20

REVISIONS | DRAWING_ISSUE

31/03/21 SK LM

DATE, DRAWN: CHECK

CLIENT	Manchester Metropolitan University
PROJECT	Ormond Building
TITLE	PROPOSED REFLECTED CEILING PLAN B1.15 B1.16, B1.17
NUMBER	20608_P267
REVISION	-
STATUS	PLANNING
SCALE	1:20 @A1
DATE	05/03/21
DRAWN BY	SK
CHECKED BY	SG

seven.

SEVENARCHITECTURE.CO.UK

Studios at -
61 Oxford Street,
MANCHESTER, M1 6EQ
t: 0161 226 9655
Clarendon House, Victoria Avenue,
HARROGATE, HG1 1DY
t: 01423 709 907
Galleri 6, Doc Victoria,
CAERNARFON, LL55 1SQ
t: 01286 685 253
24 Greville Street,
LONDON, EC1N 6SS
t: 0203 036 0691