
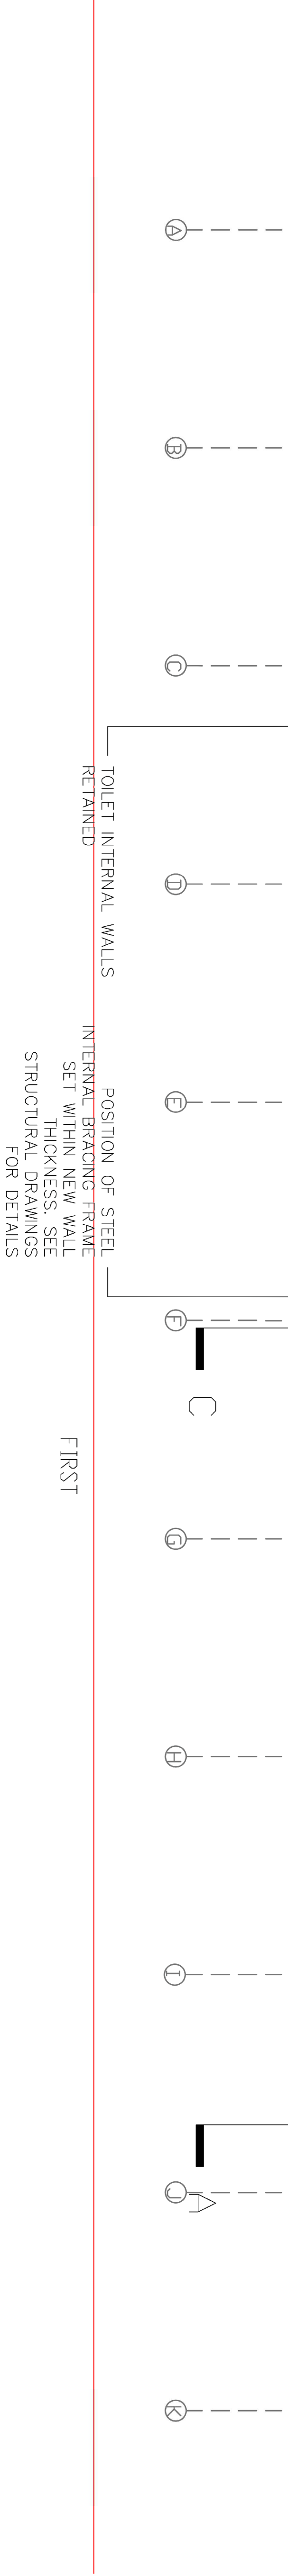


Notes:

1. This drawing is subject to copyright and is not to be reproduced in part or whole without approval.
2. Do not scale this drawing - check all dimensions on site.
3. This drawing shall be read in conjunction with the project specification/s and all other contract documentation.
4. All dimensions are in millimetres unless otherwise stated.
5. Location of all equipment shown shall be confirmed/approved with the Client/Architect/Engineer prior to any installation.
6. This drawing must be read in conjunction with Mechanical and Electrical performance specifications and all other drawings issued by the Architect, Structural Engineer and Watt Energy and Consulting Engineers.
7. The location of equipment is typical only. The Contractor shall perform all calculations to determine the exact quantity and agree the final locations with the Architect.
8. This drawing shows the intended location of building services plant and service routes in such detail as to indicate the design. The drawing does not show all components that may be necessary to provide a full working installation.
9. The positions of connector points, accessories and building services items are approximate and shown for guidance to assist during the tender process.
10. Fully co-ordinated drawings. Construction drawings and Builderswork drawings shall be produced by the contractor. Under no circumstances shall the tender drawings be used as installation drawings.

LEGEND

- S/P #110 SOL AND VENT PRE
#110 SUB STACK C/W MR
S/S ADJUSTING WATE
R/W SYPHON, RAIN WATER PRE
SYPHON, RAIN WATER PRE
R/W AS INDICATED
ON DRAWING
R/W GRANT FANWATER PRE
GRANT FANWATER PRE
R/W AS INDICATED ON
DRAWING
RE ROOFING ETC
PREWORK CONCRETE AT
HIGH LEVEL
PREWORK CONCRETE AT
LOW LEVEL
FG FLOOR GULLY
VENT VENT PRE

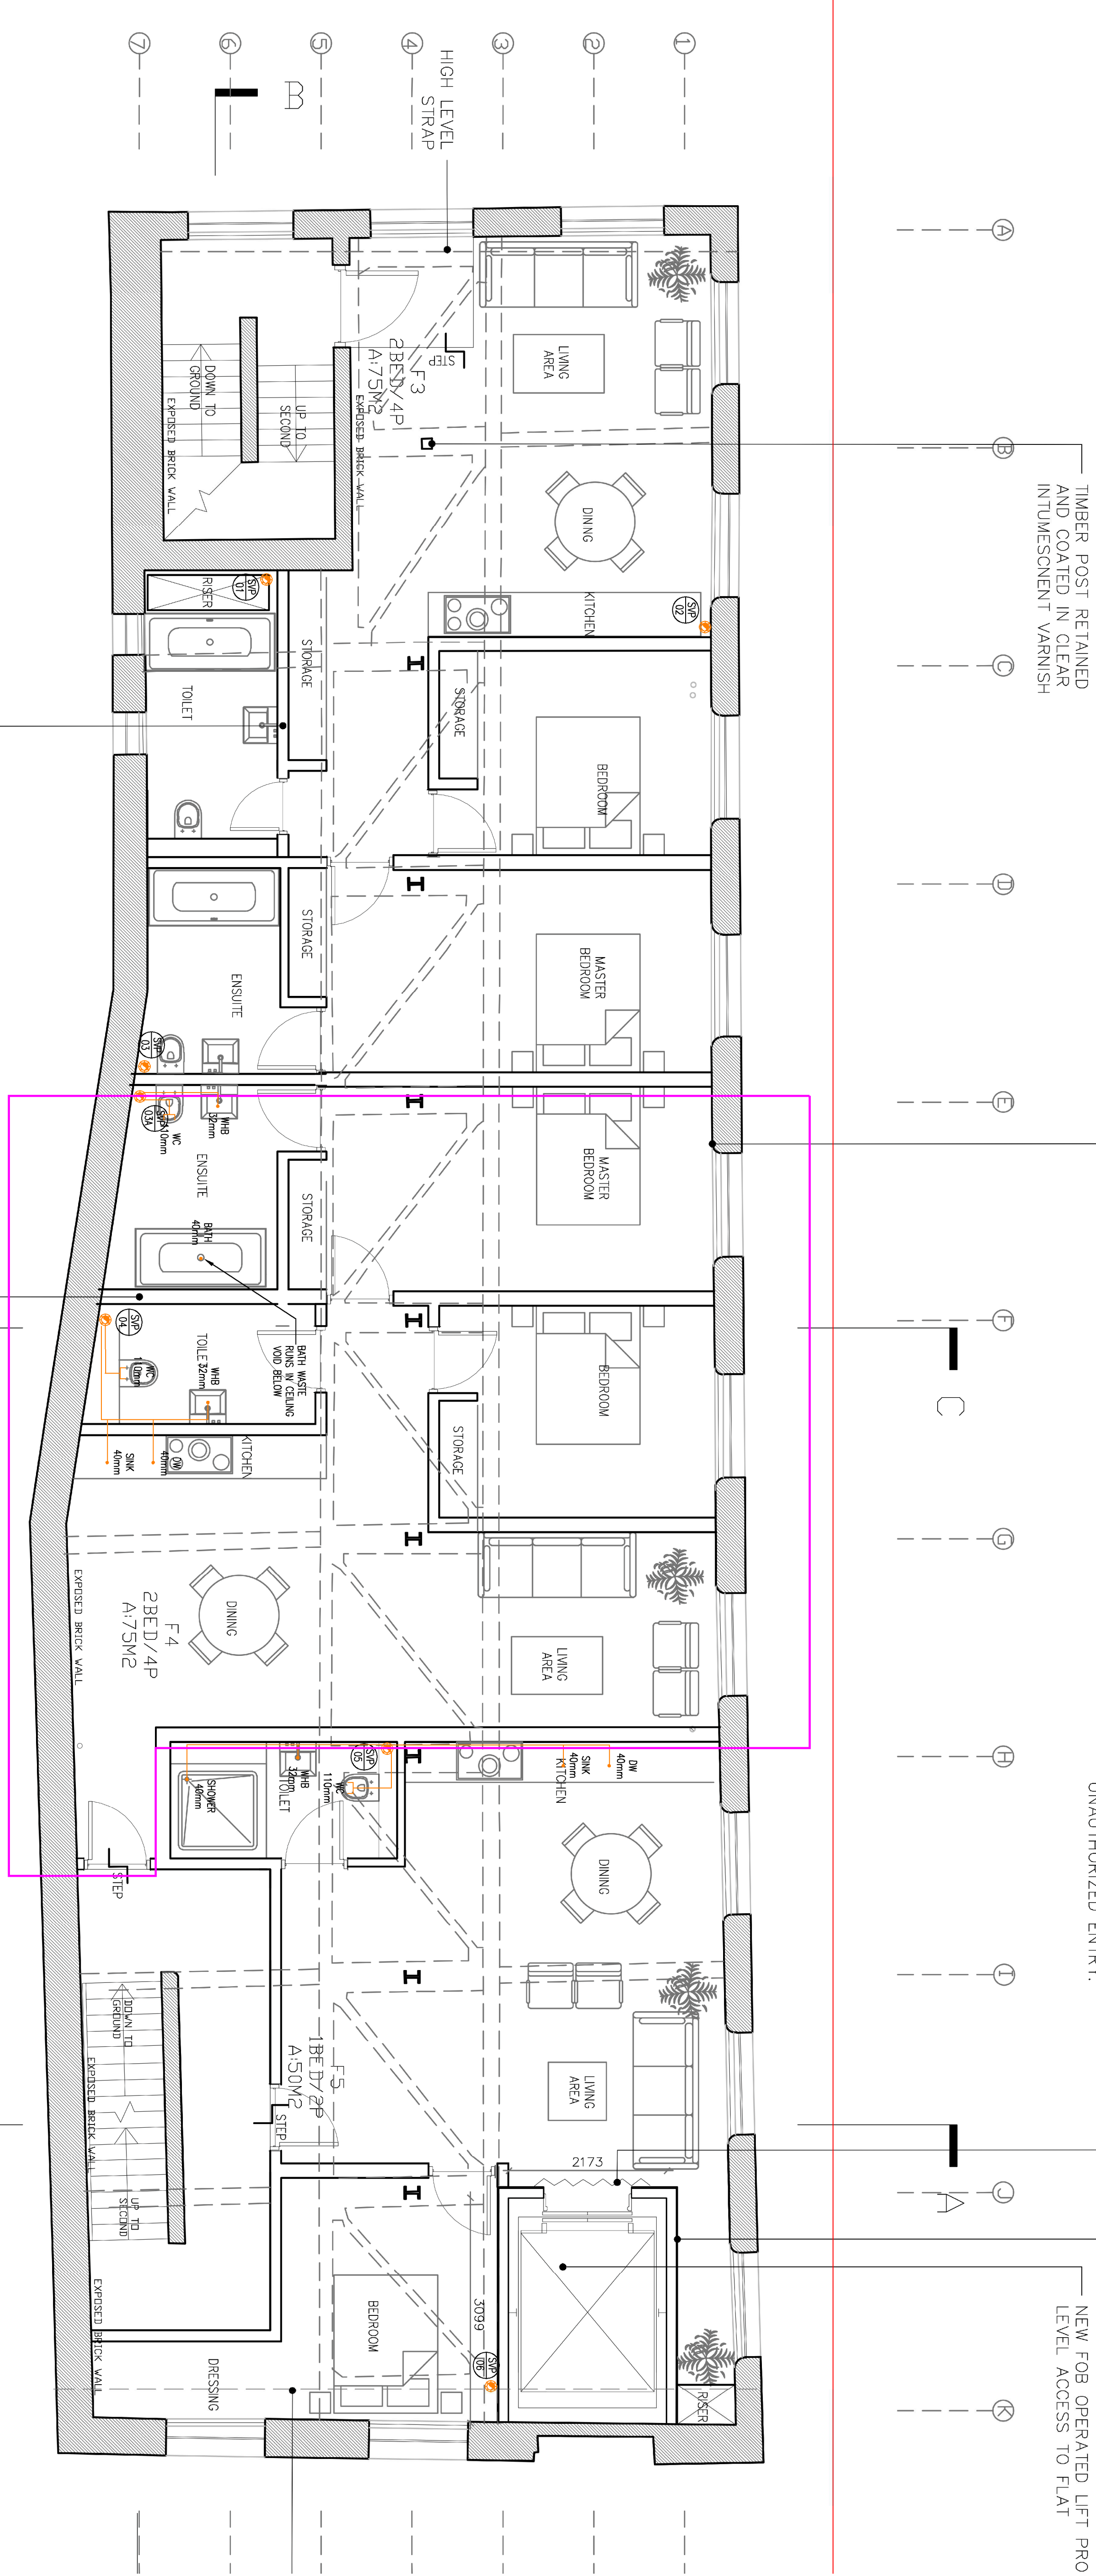

T1 29/01/21 TENDER ISSUE			BS
Rev	Date	Submitted/checked	By

40 KING STREET MANCHESTER, M2 6BA
TEL: 0161 434 3103 EMAIL: office@wece.co.uk

Client:
ARTISAN

Project:
CABLE STREET
ANCOATS
MANCHESTER

Drawing Title:
MECHANICAL SERVICES
ABOVE GROUND DRAINAGE LAYOUT
FIRST FLOOR

Drawn By:	Checked By:	Cad By:
BS	DW	SB
Scale:	Page Size:	Date Created:
1:50	A1	08 / 04 / 2019
Drawing Number:	Drawing Revision:	
WECE / 286 / M / 102	T1	