


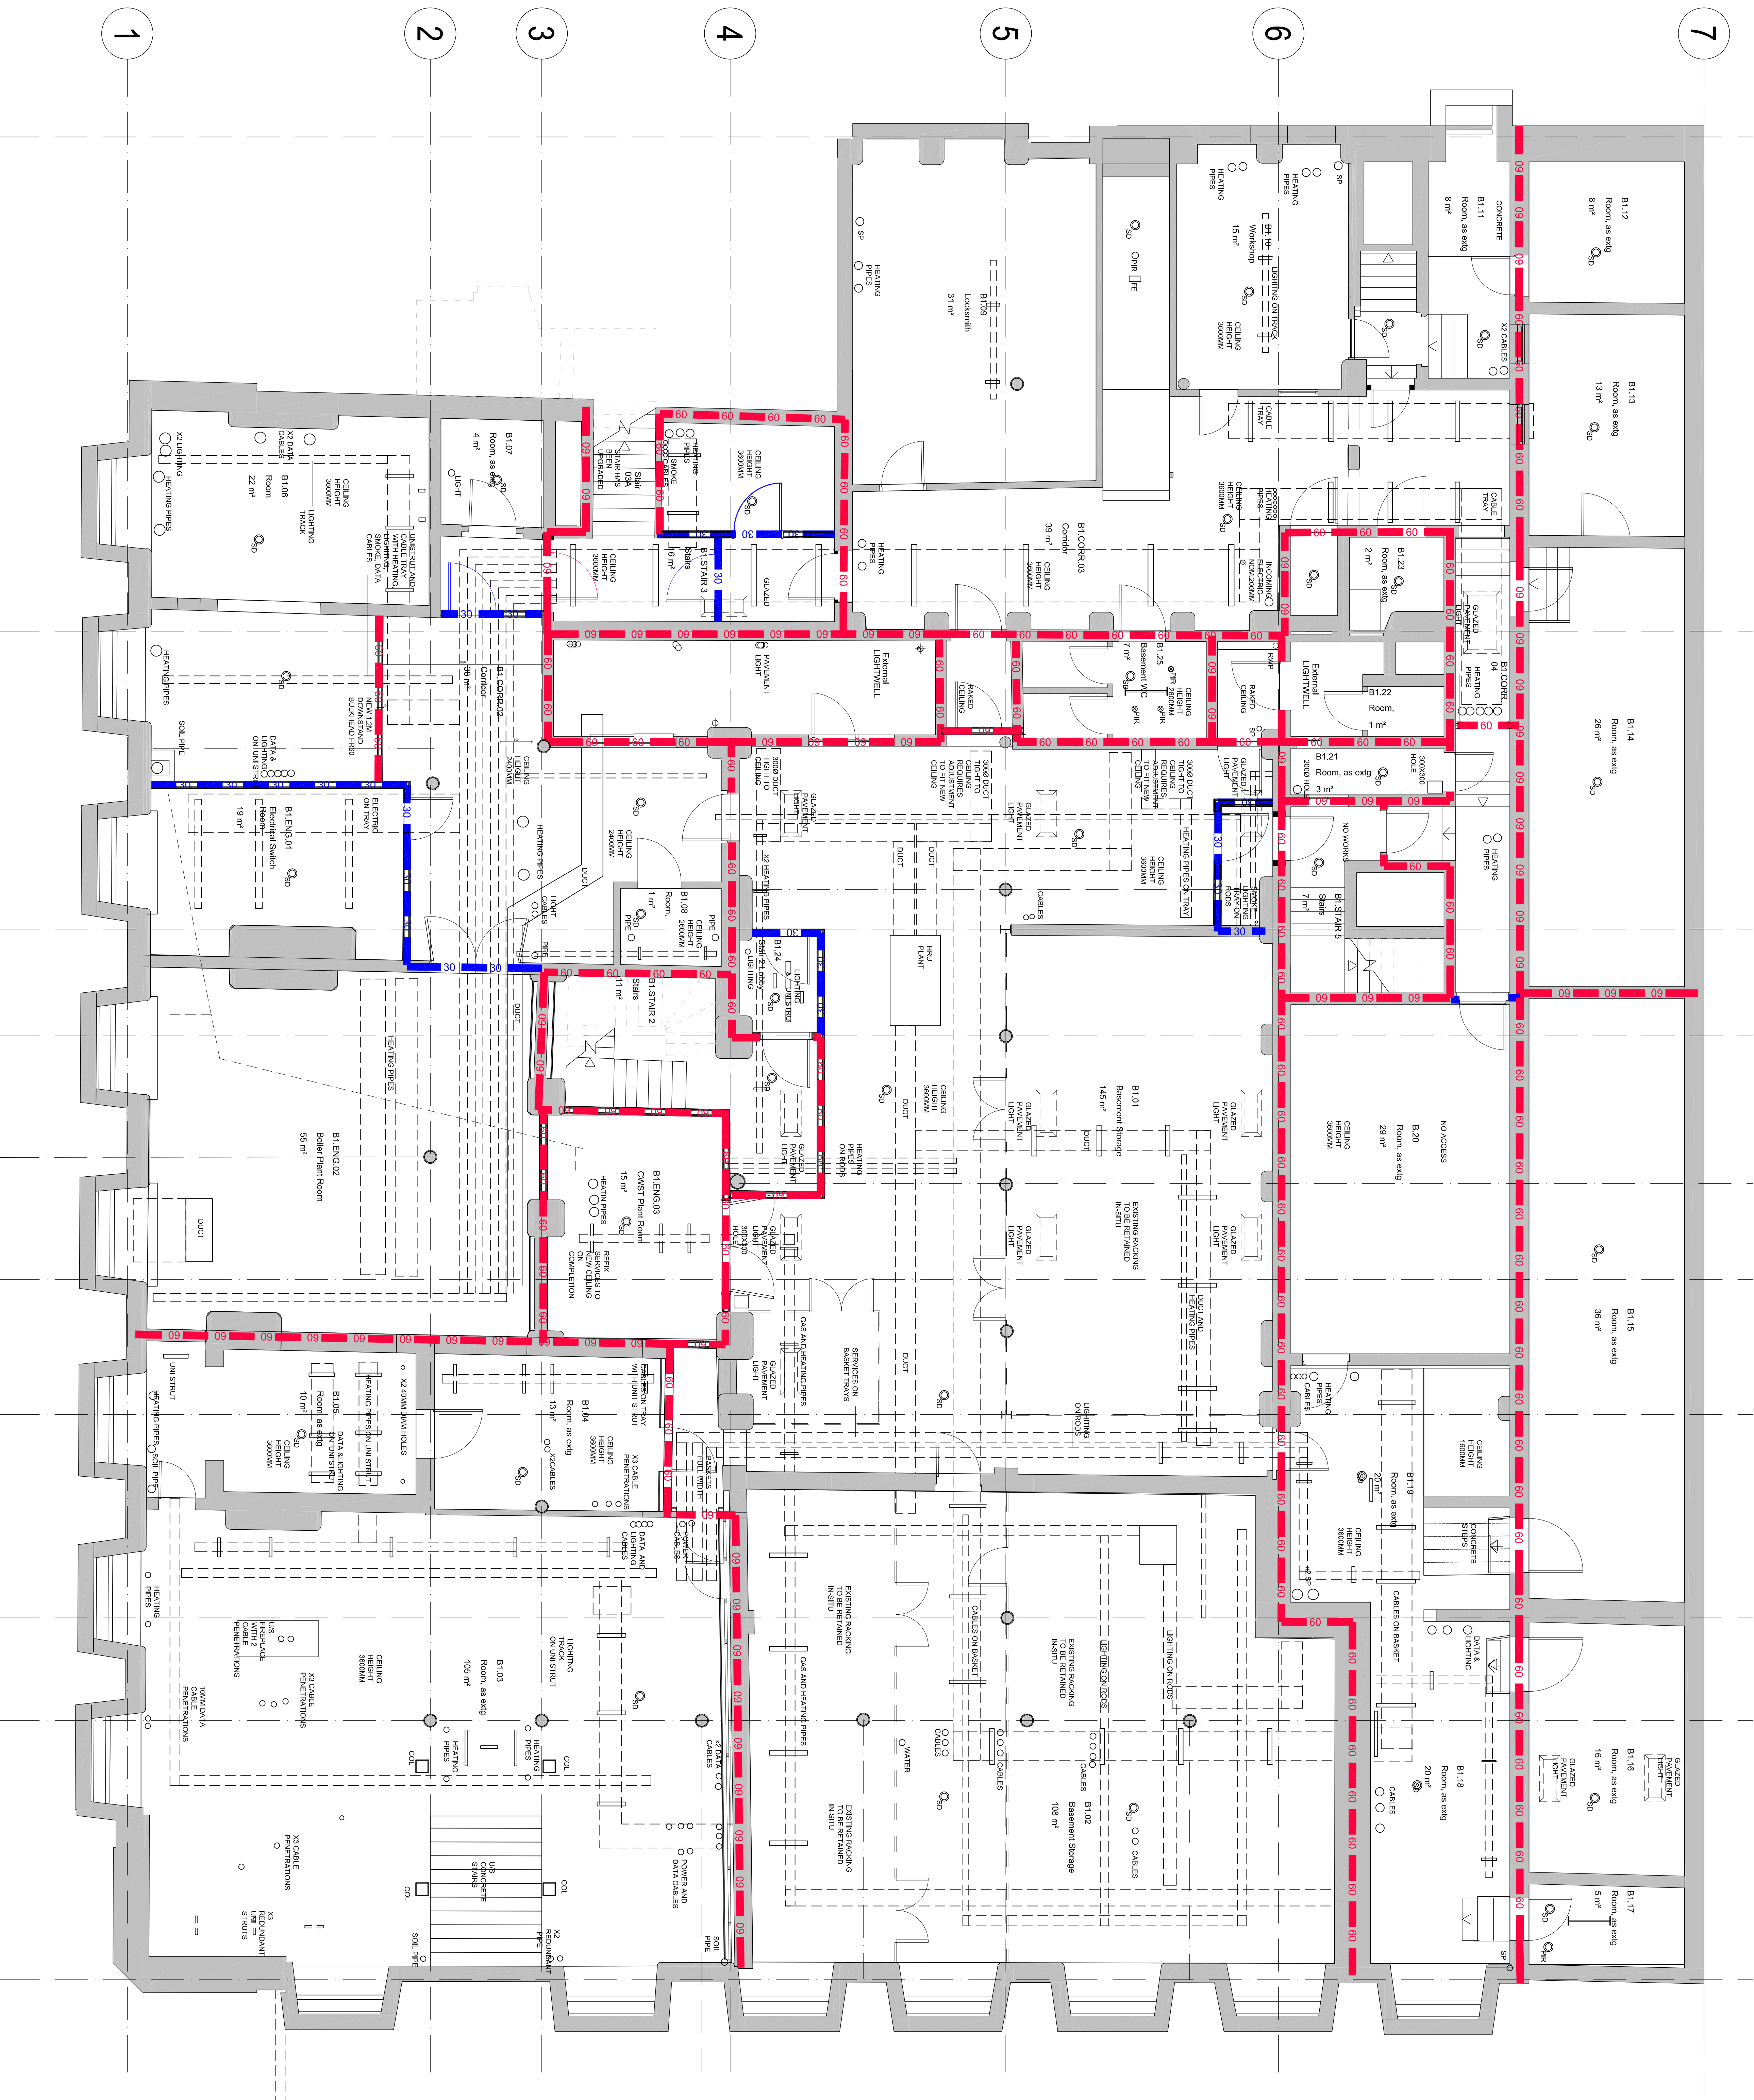

- KEY
- SERVICES ON EITHER INDIVIDUAL SCREW RODS OR UNISTRUT.
 - SERVICES ON SUSPENDED BASKET OR TRAY
 - CABLE OR PIPE PENETRATIONS THROUGH SLAB
 - SMOKE OR PIR DETECTOR
 - SURFACE FIXED LIGHTING WITH CONDUIT

CLIENT	Manchester Metropolitan University
PROJECT	Ormond Building
TITLE	EXISTING REFLECTED CEILING PLAN GA
NUMBER	20006_P102
REVISION	-
DATE	15/01/2021
DRAWN BY	SK
CHECKED BY	SS

seven

MANCHESTER METROPOLITAN UNIVERSITY
ORMOND BUILDING
EXISTING REFLECTED CEILING PLAN GA
20006_P102
15/01/2021
SK
SS

MANCHESTER METROPOLITAN UNIVERSITY
ORMOND BUILDING
EXISTING REFLECTED CEILING PLAN GA
20006_P102
15/01/2021
SK
SS