



- notes:
- DO NOT SCALE FROM THIS DRAWING - USE FIGURED DIMENSIONS ONLY.
 - TO BE READ IN CONJUNCTION WITH ALL OTHER CONSULTANTS / SPECIALISTS DRAWINGS. REPORT ANY DISCREPANCIES BEFORE AFFECTED WORK COMMENCES.
 - ALL SETTING OUT DIMENSIONS TO BE CHECKED ON SITE BY CONTRACTOR BEFORE WORK COMMENCES.

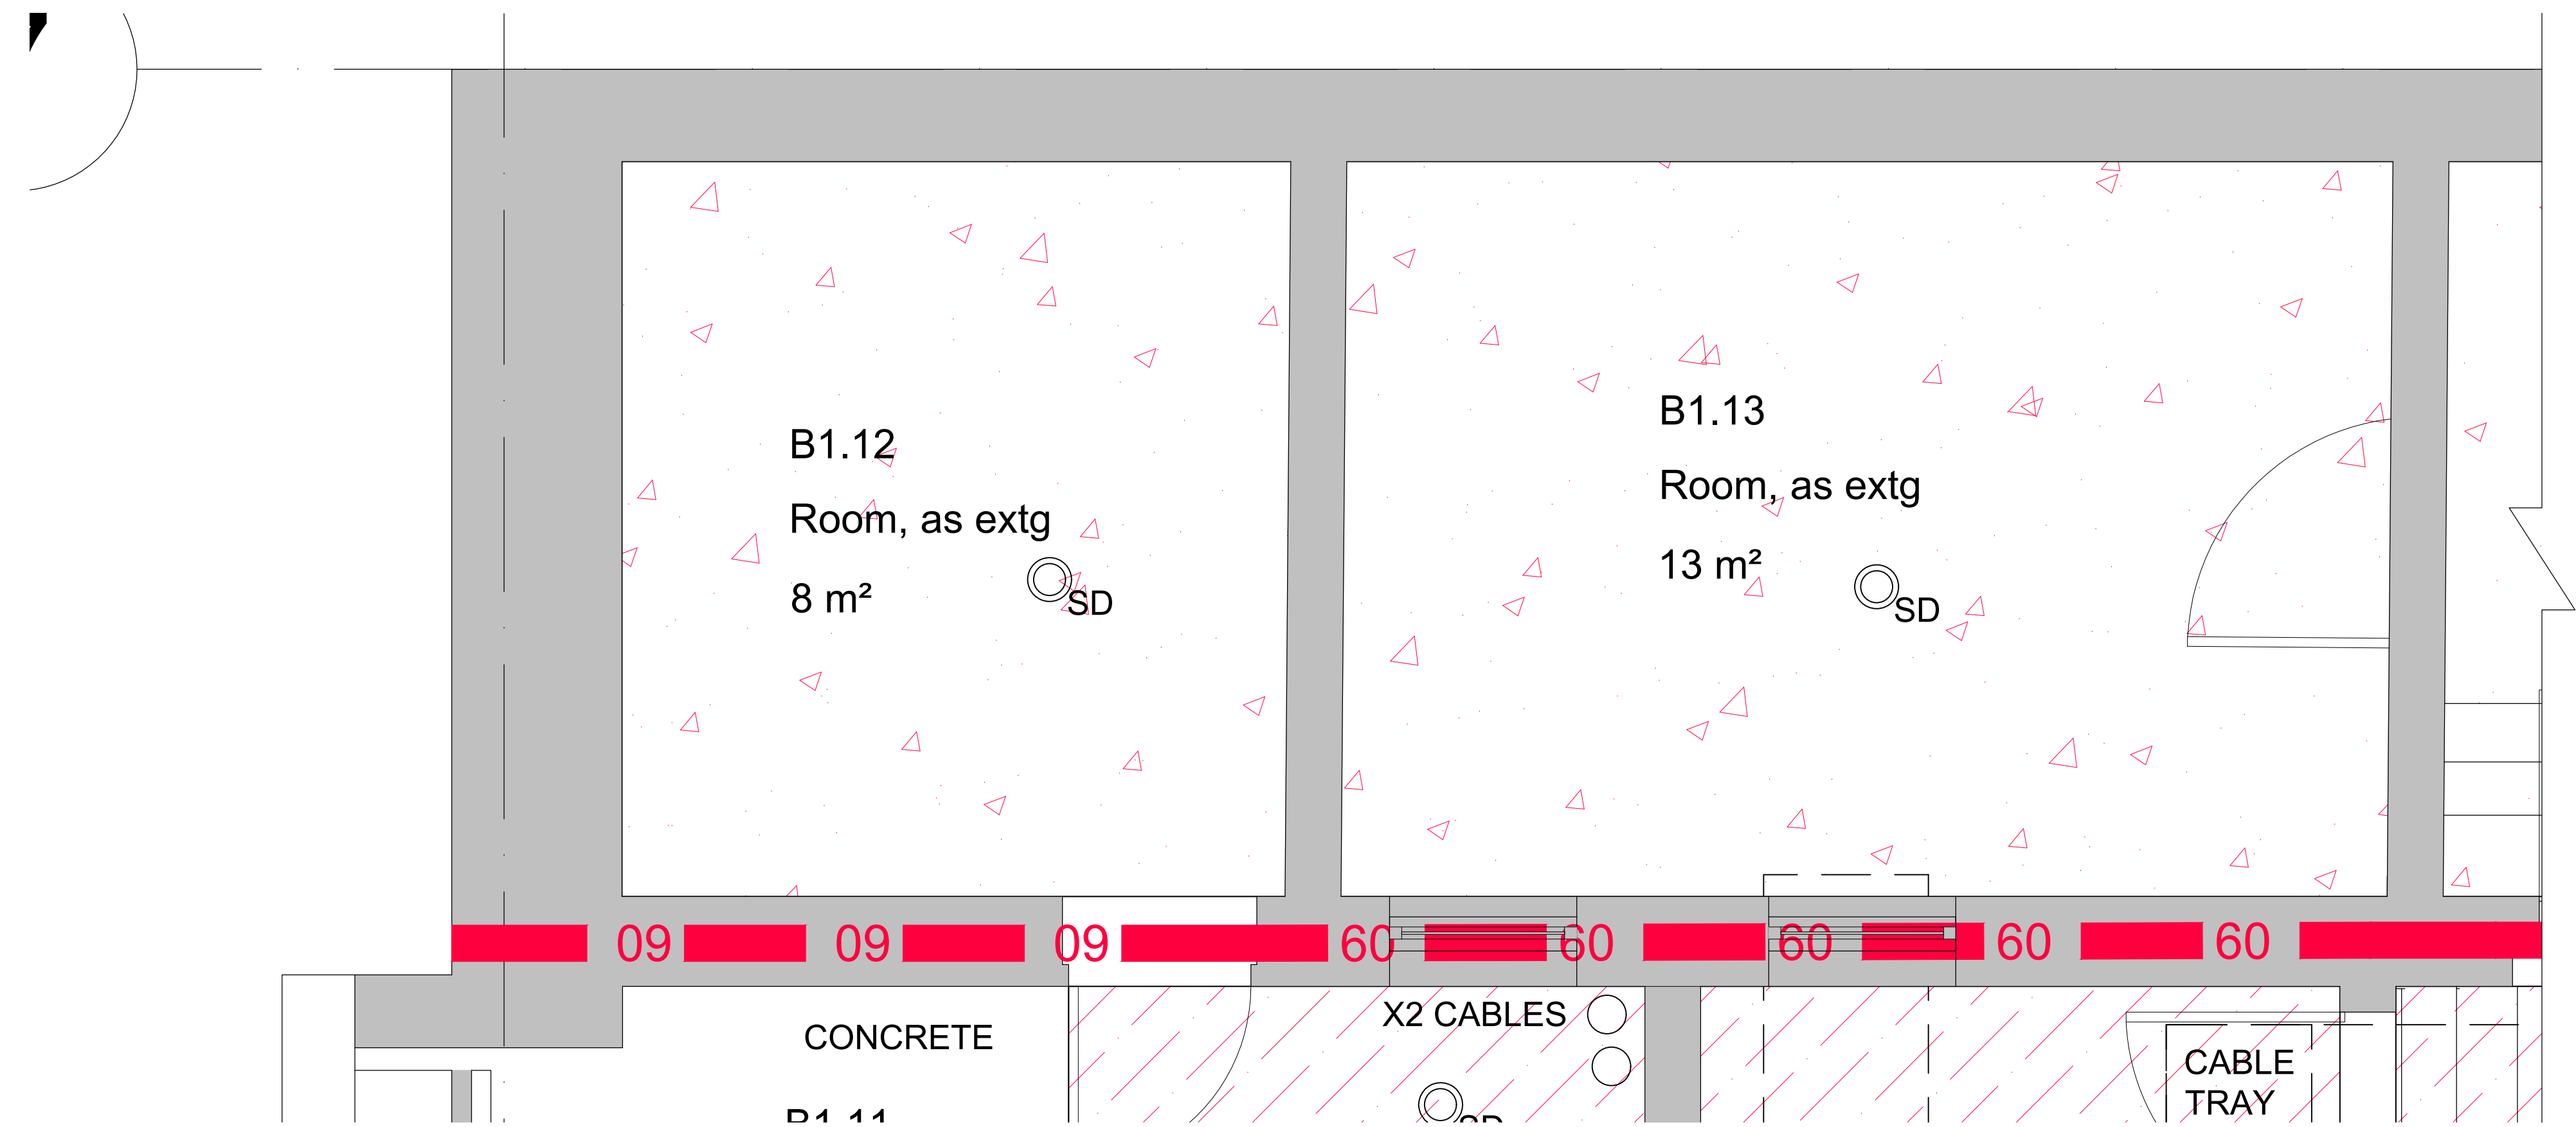


PLAN
1:20



KEY

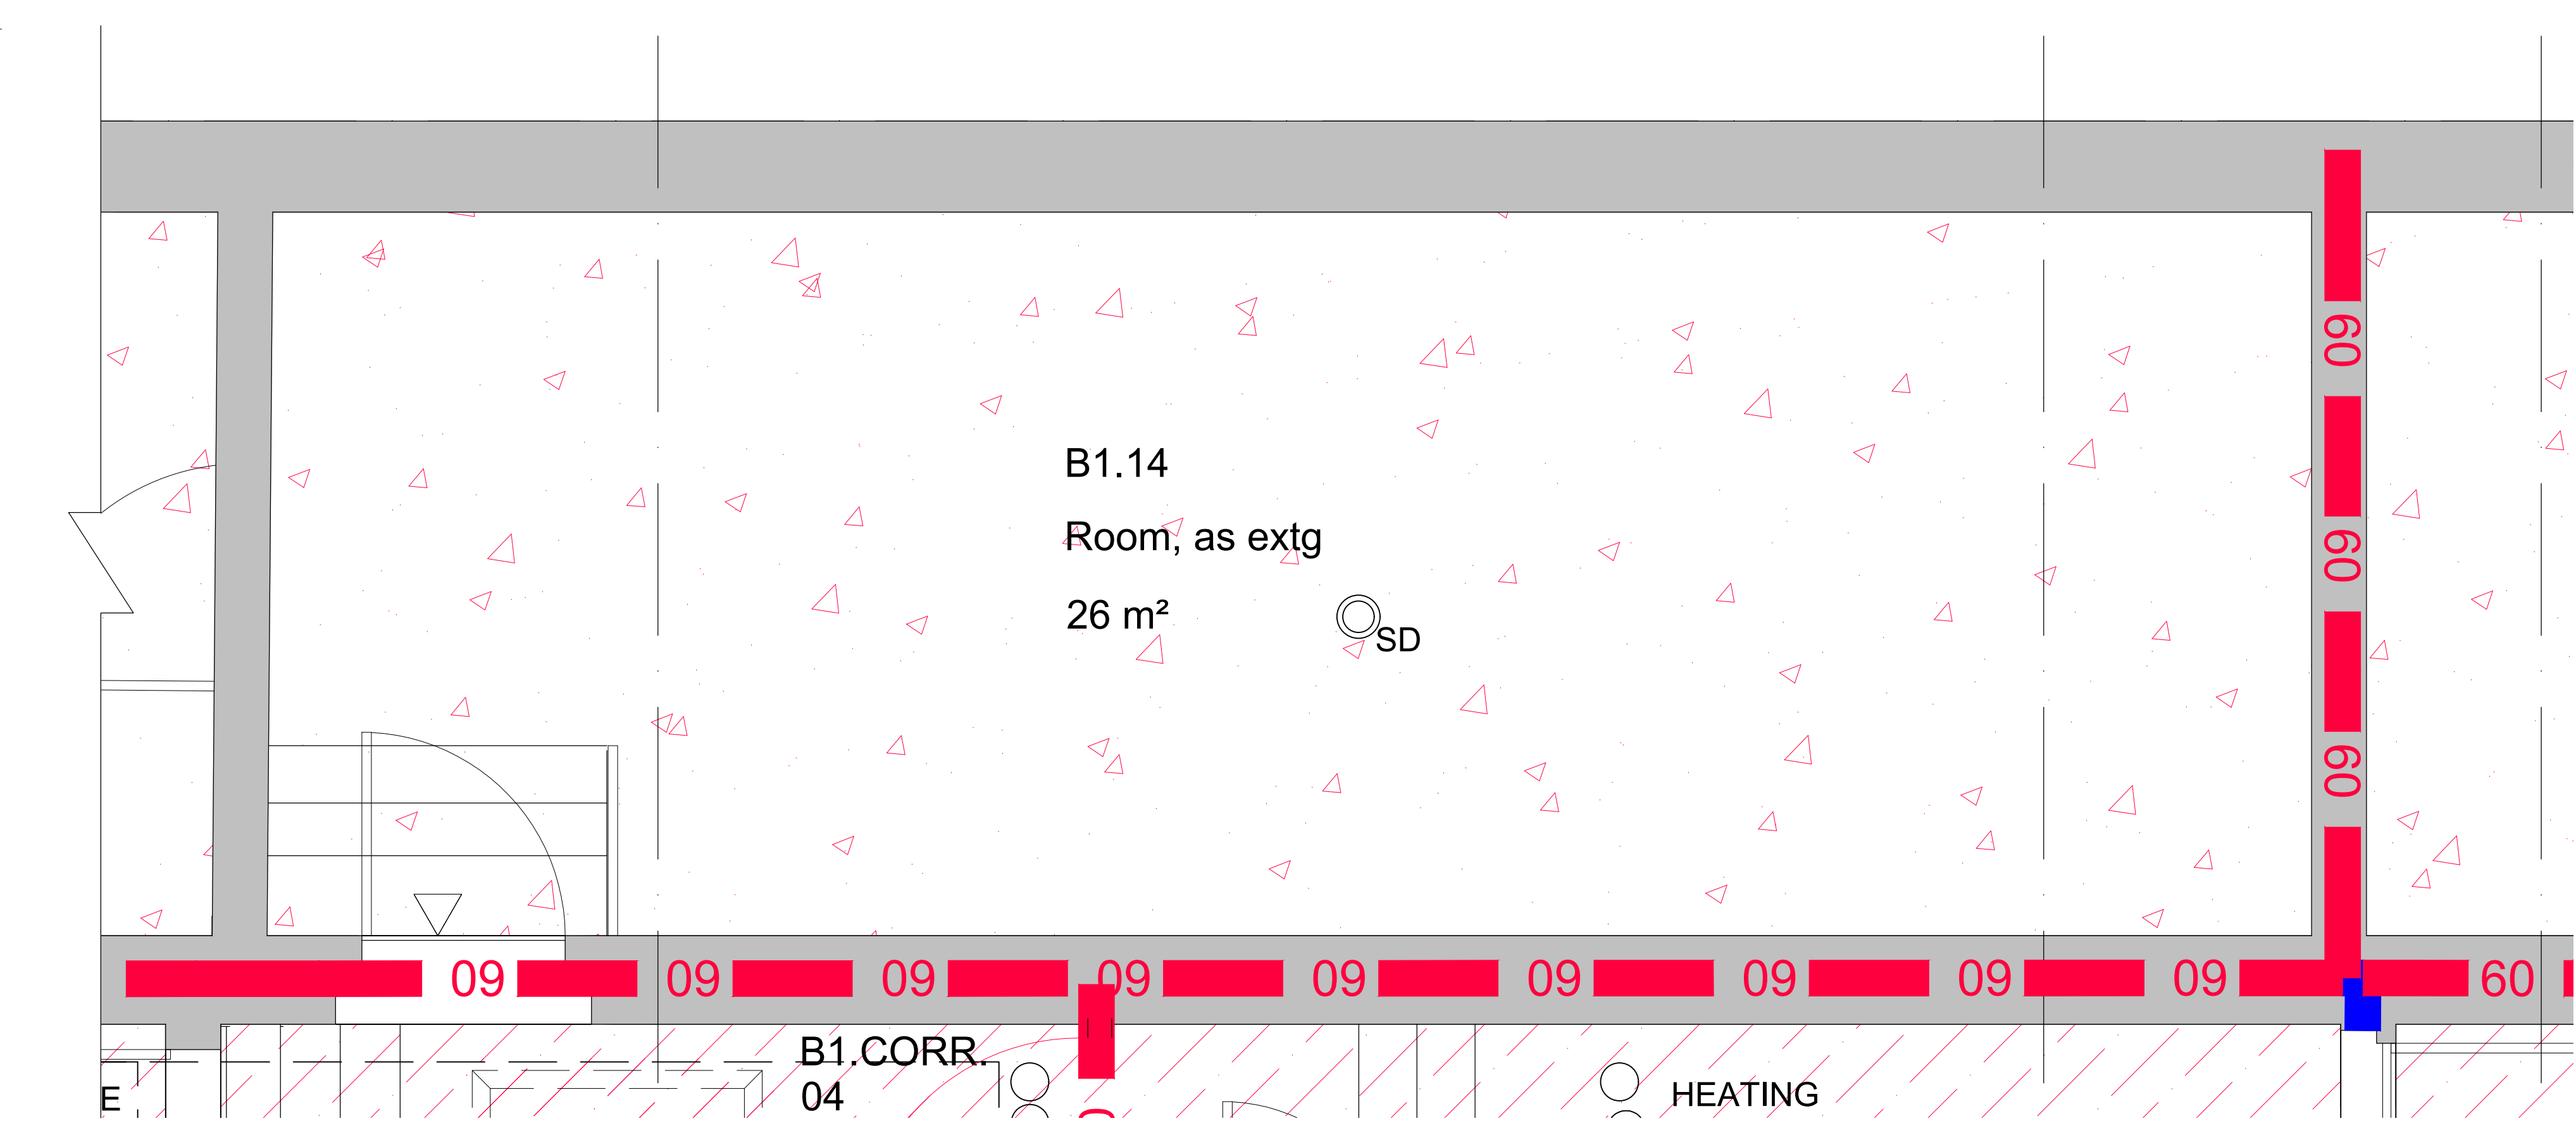


PLAN
1:20

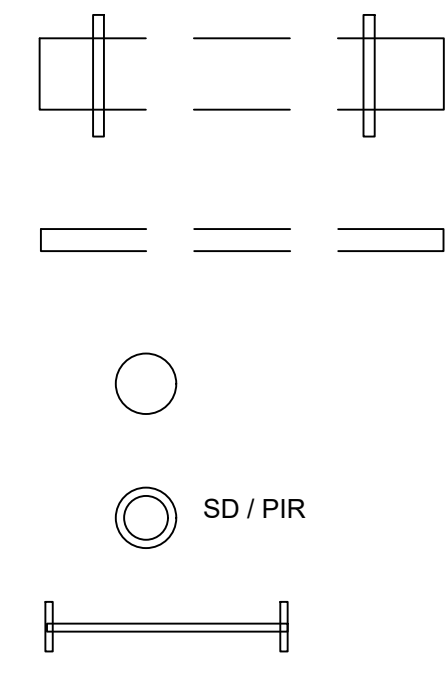

- SERVICES ON EITHER INDIVIDUAL SCREW RODS OR UNISTRUT.
- SERVICES ON SUSPENDED BASKET OR TRAY
- CABLE OR PIPE PENETRATIONS THROUGH SLAB
- SMOKE OR PIR DETECTOR
- SURFACE FIXED LIGHTING WITH CONDUIT

- NOTES:
- ALL SMOKE DETECTORS WILL REQUIRE TEMPORARY REMOVAL FOR REFITTING AGAINST NEW CEILING LINING.
 - UNI STRUT AND SCREW RODS TO REMAIN IN PLACE FOR FITTING NEW CEILING AROUND WITH FR SEALANT AROUND RODS.
 - NEW WALLS AROUND SERVICES WILL REQUIRE SEALING WITH ABLATIVE BATTS AND FR SEALANT.
 - ALL ELECTRICAL PENETRATIONS (UPTO 40MMØ I.E DATA, SMOKE LIGHTING) AROUND EXISTING SERVICES WILL REQUIRE FR SEALANT .
 - ALL MECHANICAL SERVICES ABOVE 40MM Ø (I.E. HEATING PIPES, SOIL/RWP PIPES) WILL REQUIRE A FR60 FIRE COLLAR FITTING IN THE NEW CEILING.

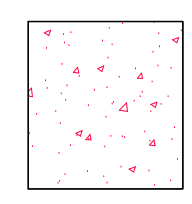

TYPE 3
AREA OF ASSUMED FILLER JOIST FLOOR CONSTRUCTION IN UNSTABLE CONDITION TO BE REPLACED WITH NEW SOLID FLOOR AND SUPPORTS - TO BE DEALT WITH UNDER A SEPARATE CONTRACT .

CLIENT	Manchester Metropolitan University	seven. SEVENARCHITECTURE.CO.UK Studios at: 61 Oxford Street, MANCHESTER, M1 6EQ t: 0161 226 9655 Clarendon House, Victoria Avenue, HARROGATE, HG1 1DY t: 01423 709 907 Galeri 6, Doc Victoria, CAERNARFON, LL55 1SQ t: 01286 685 253 24 Greville Street, LONDON, EC1N 6SS t: 0203 036 0691
PROJECT	Ormond Building	
TITLE	PROPOSED REFLECTED CEILING PLAN 1.12, B1.13, B1.14	
NUMBER	20608_P266	
REVISION	-	
STATUS	PLANNING	DATE: DRAWN: CHECK 31/03/21 SK LM DATE: DRAWN: CHECK
SCALE	1:20 @A1	
DATE	05/03/21	
DRAWN BY	SK	
CHECKED BY	SG	

REVISIONS | - DRAWING_ISSUE