


REVISION	DATE	DESCRIPTION
-	17.03.21	FOR COMMENT
-	19.03.21	PLANNING ISSUE

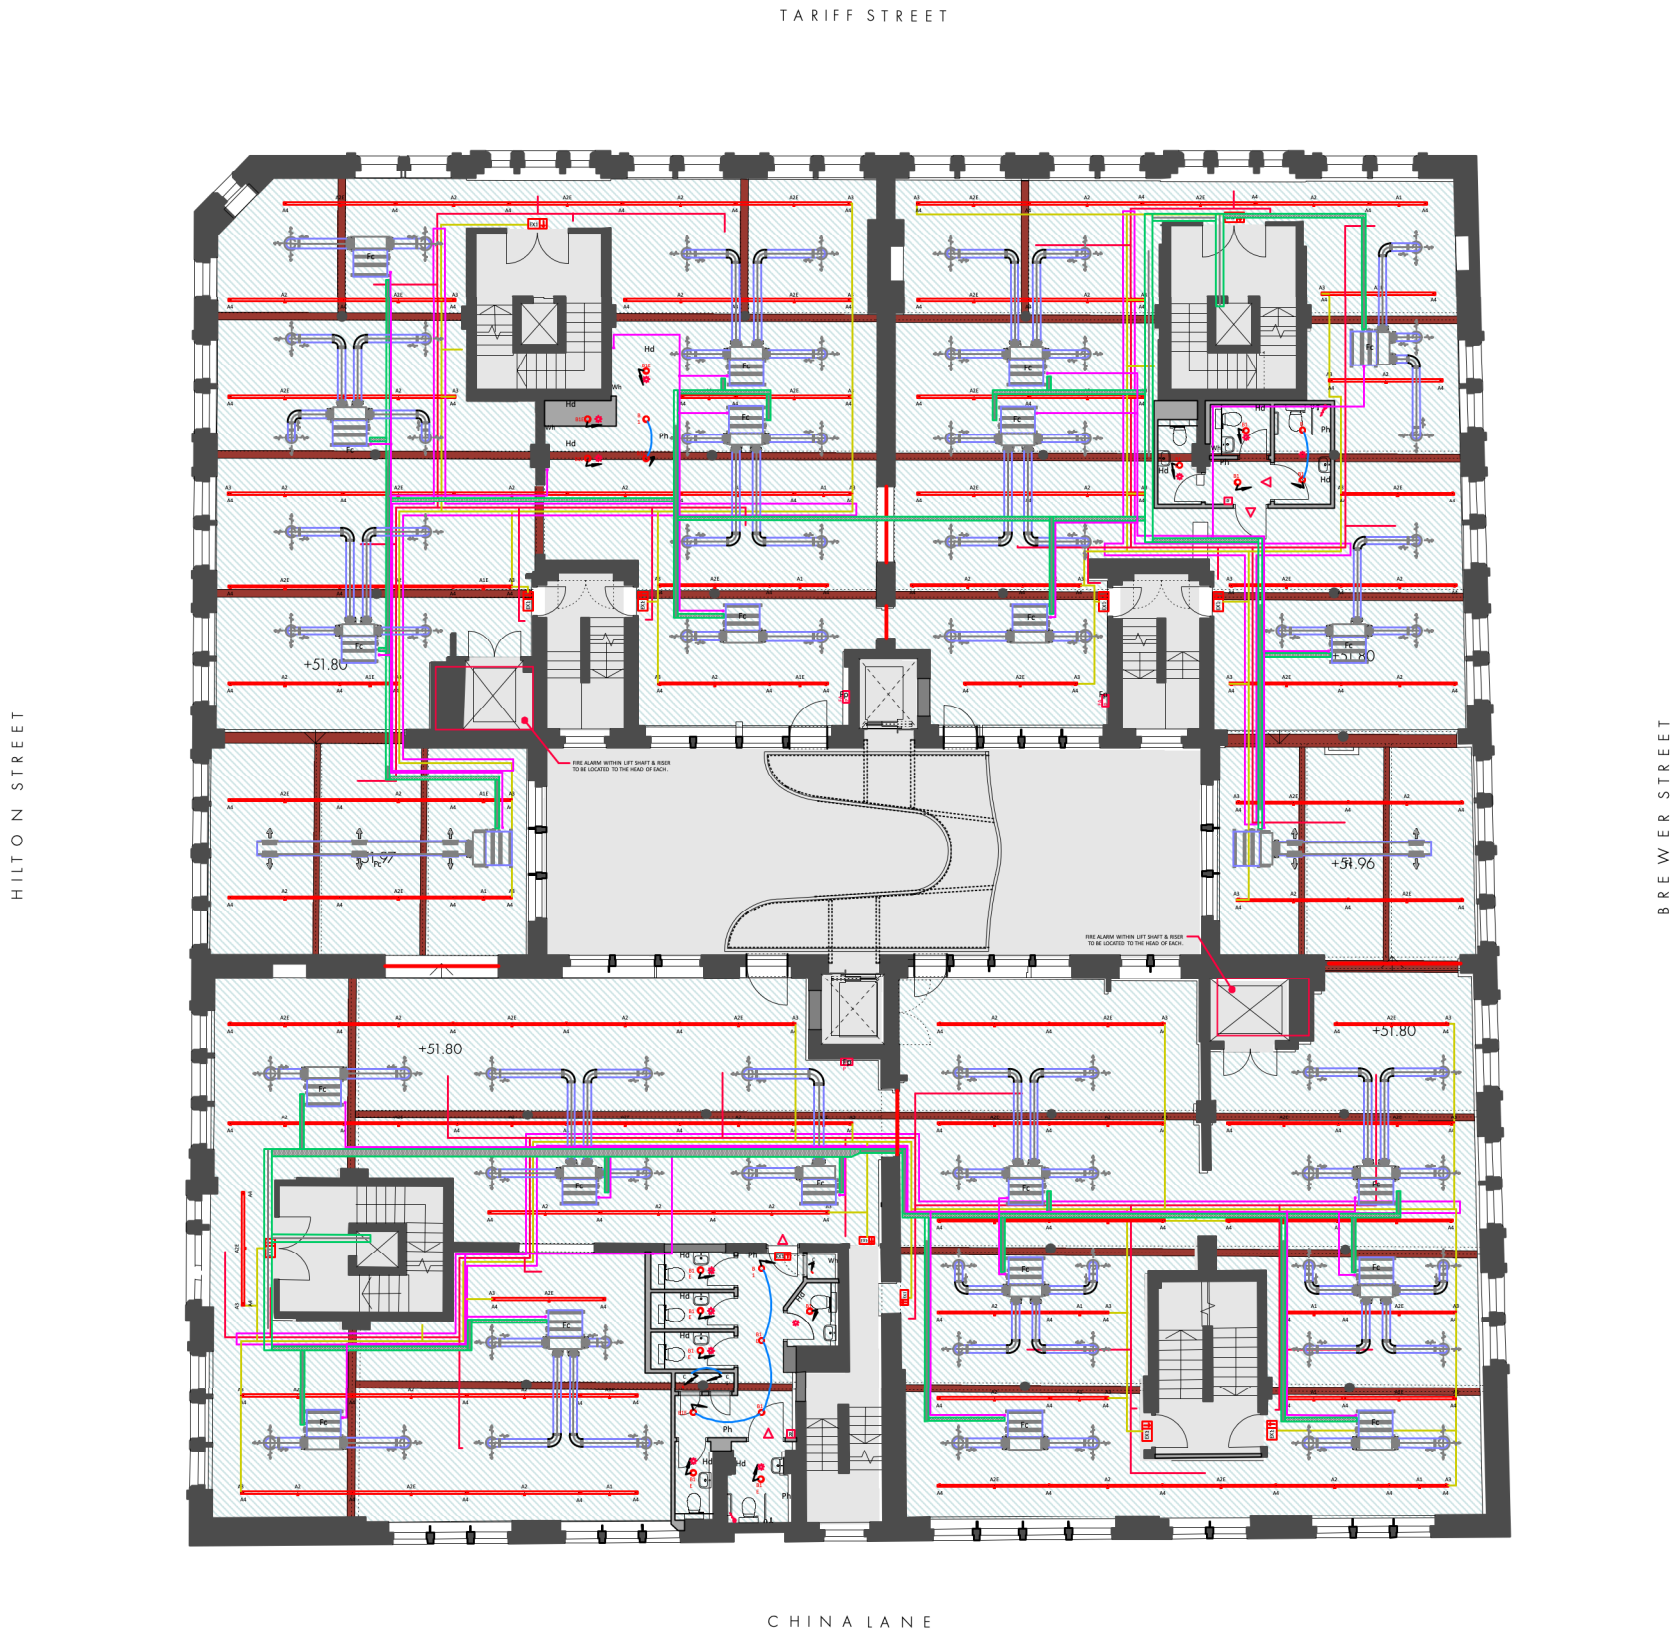

FOURWAYS HOUSE, FIRST FLOOR
EXISTING REFLECTED CEILING PLAN


1:200 @ A3

REFLECTED CEILINGS KEY

EXISTING PLASTERED CEILING

ORIGINAL BEAM EXPOSED

AREA NOT SUBJECT OF THIS APPLICATION
SEE APPLICATIONS No.s 122935/LO/2019& 123242/FO/2019

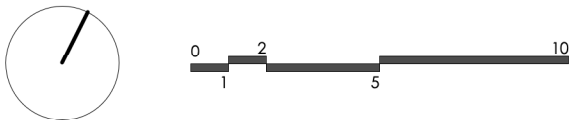MECHANICAL AND ELECTRICAL KEYA1 Thorlux 30/45w LED 1500mm Hi-Bar Suspended Continuous Luminaire - Smart Scan (Colour TBC)A1E Thorlux 30/45w LED 1500mm Hi-Bar Suspended Continuous Luminaire - Smart Scan Emergency (Colour TBC)A2 Thorlux 60/90w LED 3000mm Hi-Bar Suspended Continuous Luminaire - Smart Scan (Colour TBC)A2E Thorlux 60/90w LED 3000mm Hi-Bar Suspended Continuous Luminaire - Smart Scan Emergency (Colour TBC)A3 Thorlux Hi-Bar Suspended End KitA4 Thorlux Hi-Bar Suspension KitLED Recessed Open DownlighterE Denotes Emergency VersionX1 Maintained LED Scanlight c/w Arrow UpX2 Maintained LED Scanlight c/w Arrow DirectionalPIR Surface Mounted PIR c/w HVAC Contact For Fan ControlSD Smoke DetectorSDS Smoke Detector c/w SounderHTD Heat DetectorMCP Manual Call PointFB Flashing BeaconDWCARU Disabled WC Alarm Reset UnitAALI Assistance Alarm Indicator Light & BuzzerDWCAP Disabled WC Alarm PullcordFAP Fire Alarm PanelP Conduit To Serve Lighting InstallationPFI Conduit To Serve Fire Alarm InstallationGCT 300mm x 25mm Galvanised Cable TrayMFCU Mitsubishi PEFY Series Fan Coil Unit (Or Equal & Approved)SCS Supply Circular Swirl c/w Coanda Plate (Giberts Or Equal & Approved)VCD Volume Control DamperSAD Supply Air DuctworkRP Refrigerant Pipework (High Level)CD Condensate Drain

PLANNING ISSUE

OMIArchitects

31 Blackfriars Road, Salford, Manchester, M3 7AQ
+44(0)161 832 3242 / info@omiarchitects.com / www.omiarchitects.com

PROJECT	FIRST FLOOR, FOURWAYS HOUSE				
DRAWING	EXISTING REFLECTED CEILINGS PLAN				
DATE	MAR' 21	DRAWN BY	KT	SCALE	1:200@A3
JOB NO.	1412	DWG.NO.	L 2202		