


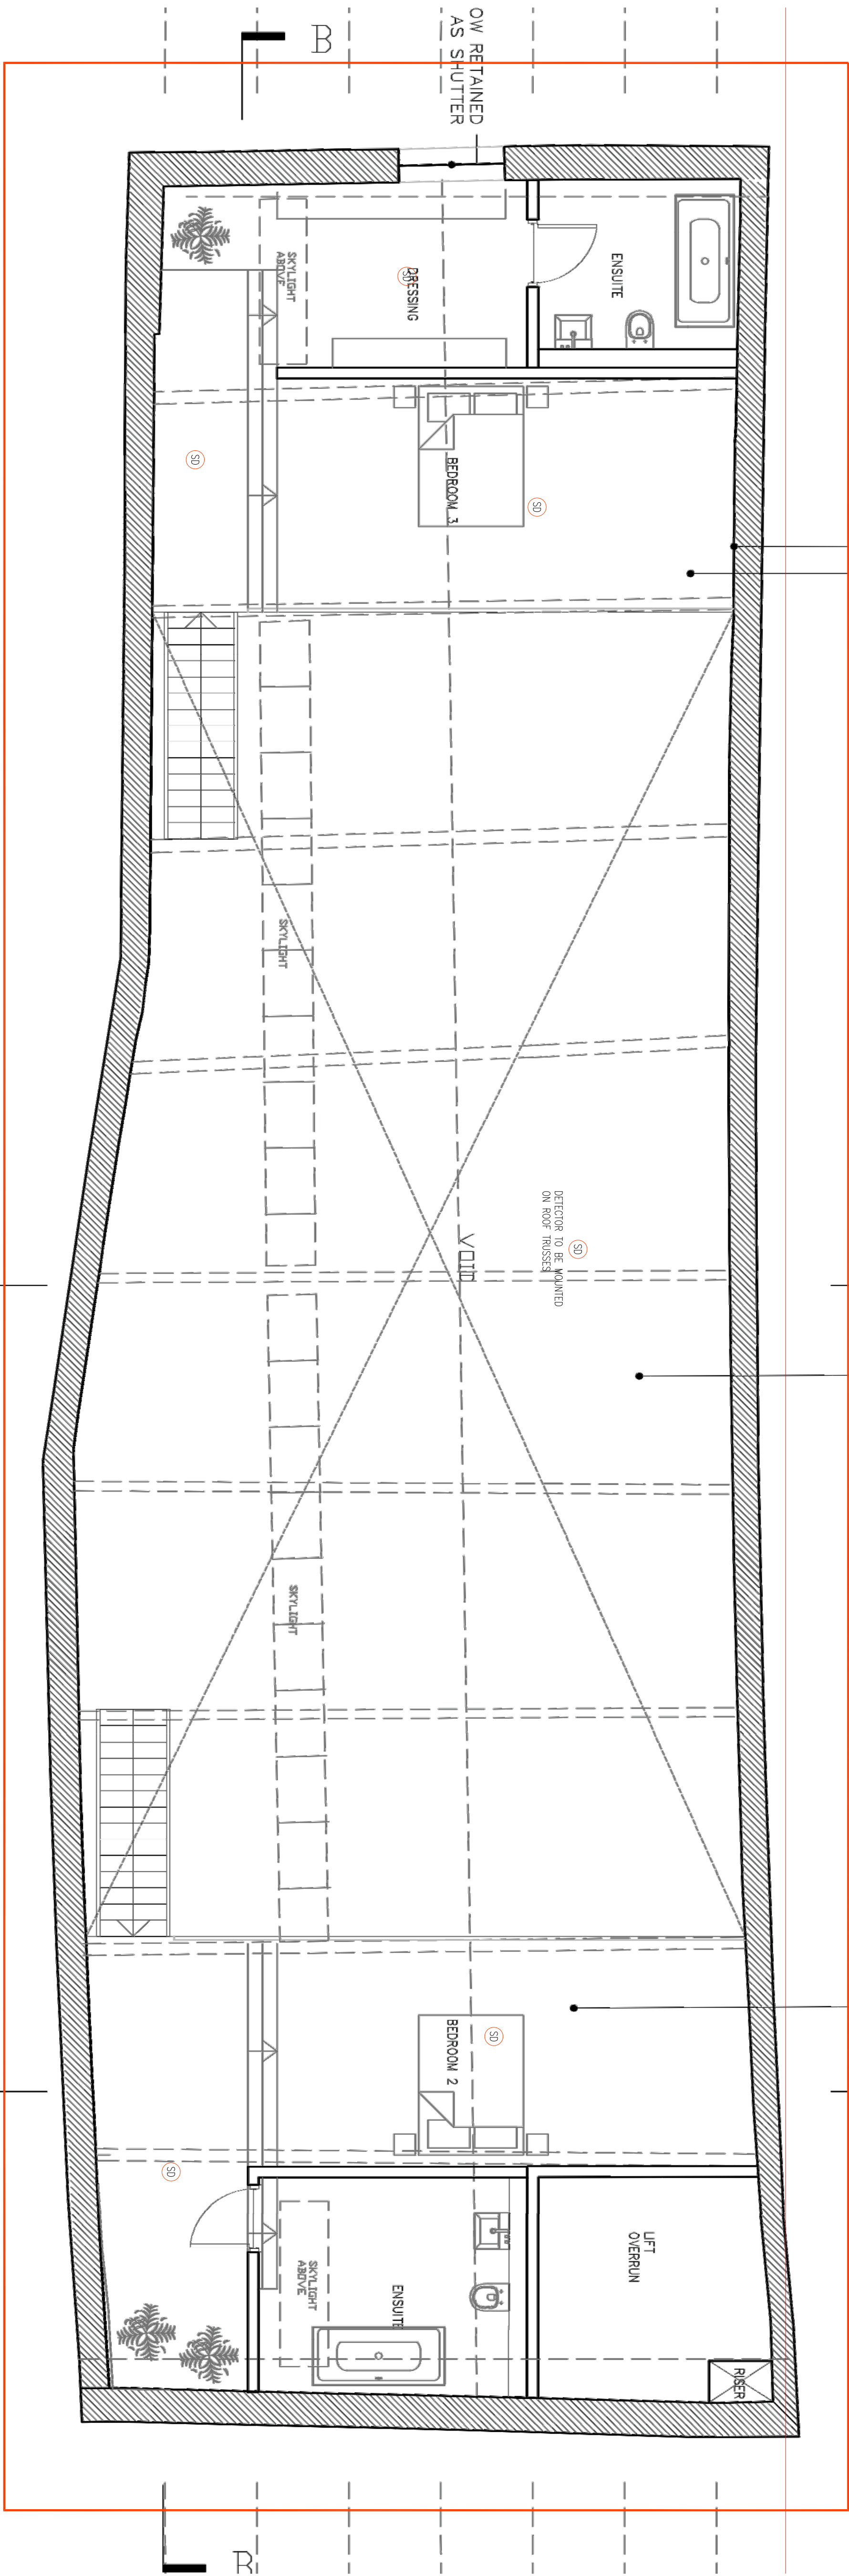


APARTMENT TYPE	PENTHOUSE
----------------	-----------



WE&CE DRAWINGS ARE FOR DESIGN INTENT ONLY. THE MEP CONTRACTOR IS RESPONSIBLE FOR THE FINAL INSTALLATION DRAWINGS INCLUDING ALL SETTING OUT, DIMENSIONS, ALIGNMENT AND COORDINATION WITH THE ARCHITECT'S REQUIREMENTS.

1. This drawing is subject to copyright and is not to be reproduced in part or whole without approval.
2. Do not scale this drawing - check all dimensions on site.
3. This drawing shall be read in conjunction with the project specifications, and all other contract documents.
4. All dimensions are in millimeters unless otherwise stated.
5. Location of all equipment shown shall be confirmed/approved with the Client/Architect/engineer prior to any installation.
6. This drawing must be read in conjunction with Mechanical and Electrical performance specifications and all other drawings as issued by the Architect, Structural Engineer and Wat, Energy and Consulting Engineers.
7. The location of equipment is typical only. The Contractor shall perform all calculations to determine the exact quantity and agree the final locations with the Architect.
8. This drawing shows the intended location of building services plant and service outlets in situ (as used) as to indicate the design. The drawing does not show all components that may be necessary to provide a full working installation.
9. The positions of connection points, accessories and building services items are approximate and shown for guidance to assist during the tender process.
10. Fully co-ordinated drawings: Construction drawings and Builderswork drawings shall be produced by the contractor. Under no circumstances shall the tender drawings be used as installation drawings.

COMMUNAL FIRE ALARM & SECURITY LEGEND:

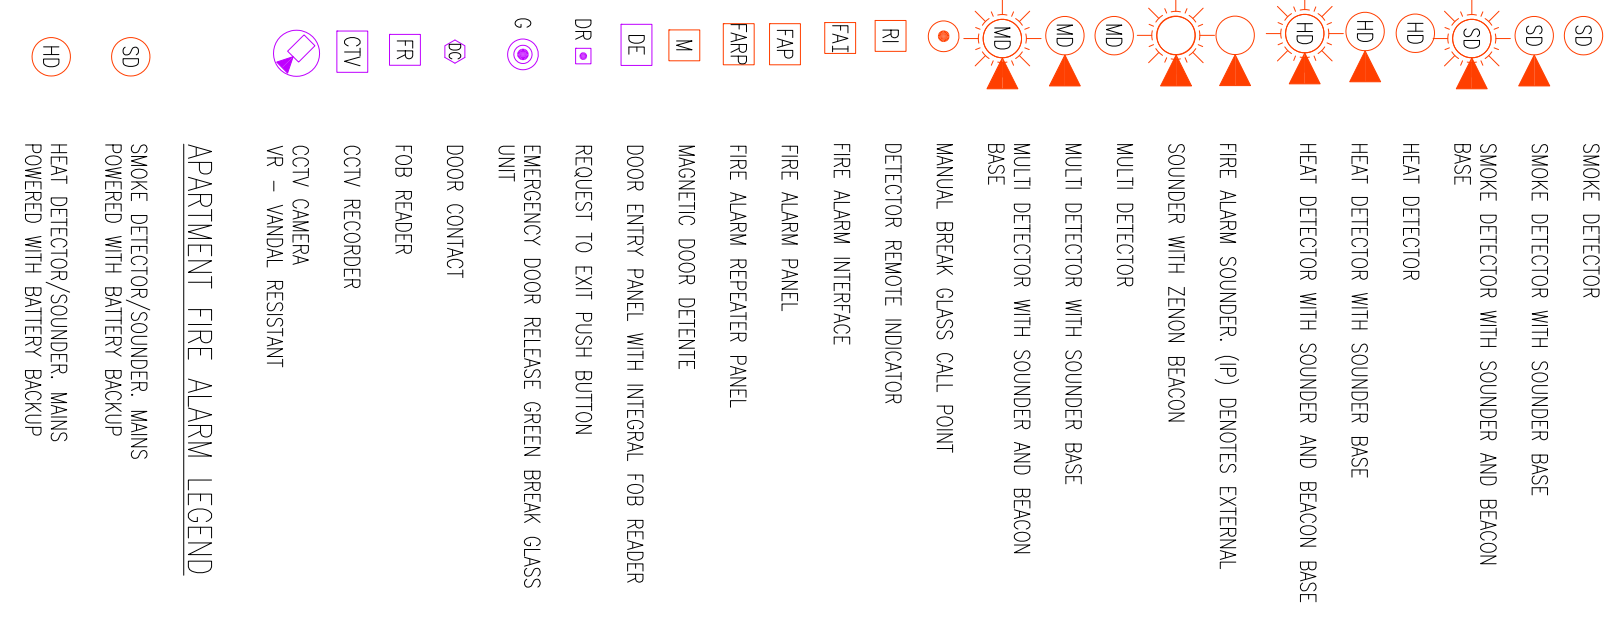

APARTMENT FIRE ALARM LEGEND

SMOKE DETECTOR/SOUNDER, MAINS
POWERED WITH BATTERY BACKUP

HEAT DETECTOR/SOUNDER, MAINS
POWERED WITH BATTERY BACKUP



Client:
ARTISAN

Project:
**CABLE STREET, ANCOATS
MANCHESTER**

Drawing Title:
ELECTRICAL SERVICES
FIRE ALARM & SECURITY LAYOUT
MEZZANINE FLOOR

Drawn By: KH	Checked By: DW	Cad By: KH
Scale: 1:50	Paper Size: A1	Date Created: 08 / 04 / 2019
Drawing Number: WECE-286-E-117		Drawing Revision: T1