



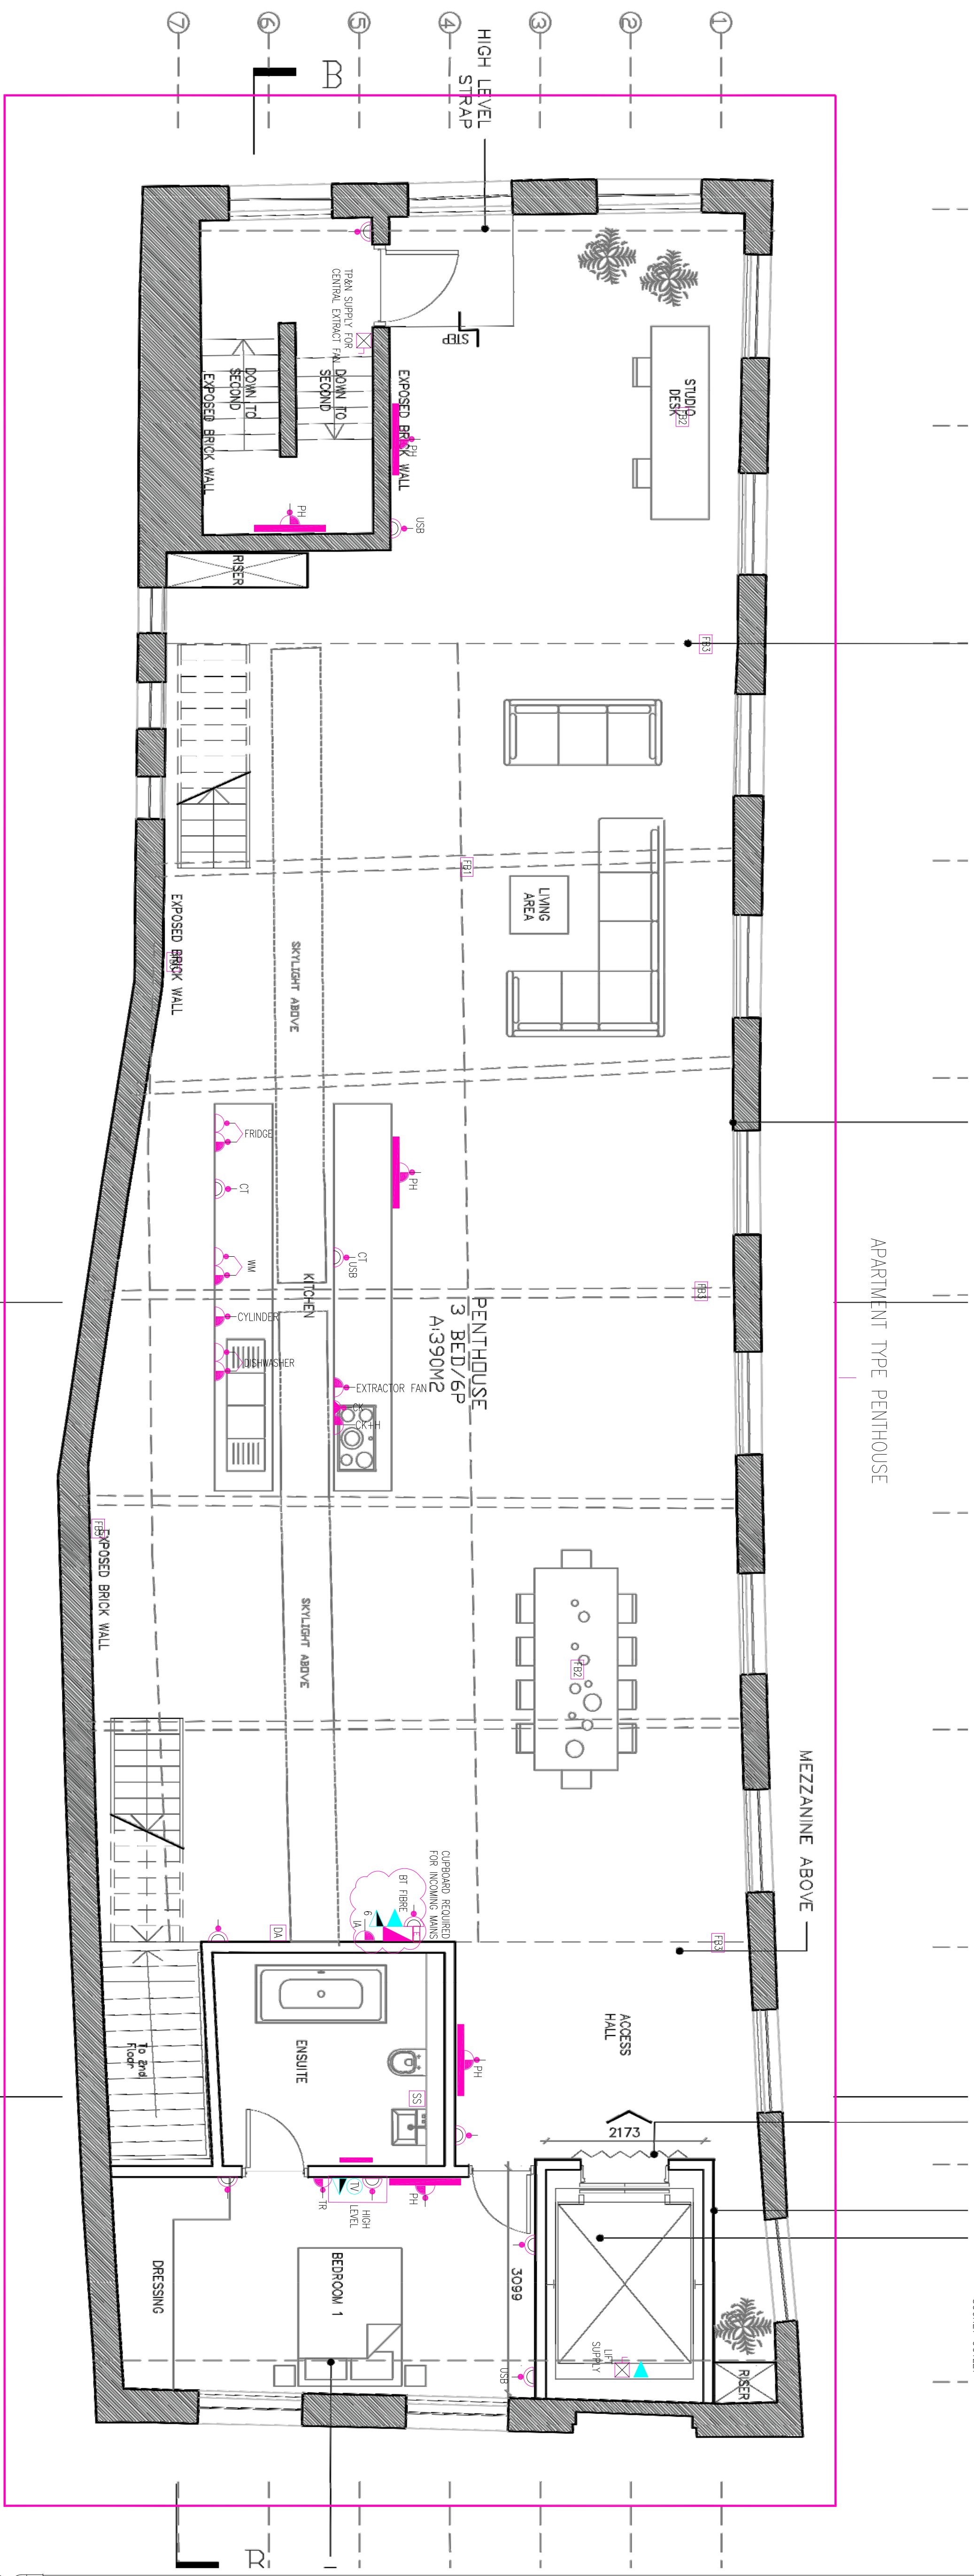

- | | |
|---|---|
|  | APARTMENT SMALL POWER OUTLET |
|  | SWITCHED SINGLE SOCKET OUTLET |
|  | SWITCHED DOUBLE SOCKET OUTLET
USB-DEVICES SOCKET C/W USB OUTLETS |
|  | SWITCHED DOUBLE SOCKET OUTLET MOUNTED 150mm ABOVE
KITCHEN COUNTER |
|  | SWITCHED FUSED CONNECTION UNIT
TRIP-OWEL PAUL
HP-HEATING PROGRAMMER |
|  | SWITCHED FUSED CONNECTION UNIT AND LOW LEVEL SOCKET FOR
Fridge |
|  | SWITCHED FUSED CONNECTION UNIT AND LOW LEVEL SOCKET FOR
DISHWASHER |
|  | SWITCHED FUSED CONNECTION UNIT AND LOW LEVEL SOCKET FOR
WASHER/DRYER |
|  | SWITCHED FUSED CONNECTION POINT FOR OVEN AND
FLEX OUTLET PLATE FOR HOB |
|  | 45A COOKER CONTROL UNIT C/W 13A SINGLE SOCKET + LED
MODIFIED 60mm ABOVE KITCHEN COUNTER FOR ISOLATION OF
OVEN AND HOB |
|  | DUAL RCD RESIDUAL CONSUMER UNIT |
|  | TV AERIAL POINT |
|  | SATELLITE TV POINT |
|  | BT MASTER TELEPHONE OUTLET, ONT & BBU. |
|  | DATA & DATA OUTLET |
|  | SHAVER SOCKET OUTLET |
|  | INCOMING ELECTRIC METER |
|  | UNSWITCHED FUSED CONNECTION UNIT FOR
FRIDGE INSTALLATION OF FRIDGE ALARM
RELEASE FUNCTION |
|  | VIDEO DOOR ACCESS INTERCOM UNIT C/W REMOTE |
|  | MEDIA PLATE C/W 2 NO TWIN SWITCHED
SOCKETS, 1 NO TV OUTLET, 2 NO RJ45
SOCKETS, 1 NO SATELLITE SOCKET. |
|  | ELECTRIC PANEL HEATER |
|  | HEATING PROGRAMMER |
|  | 4 COMPARTMENT FLOOR BOX C/W 2 NO TWIN
SWITCHED SOCKETS, 1 NO SATELLITE SOCKET, NO
RJ45 SOCKETS |
|  | 3 COMPARTMENT FLOOR BOX C/W 2 NO TWIN
SWITCHED SOCKETS & 2 NO RJ45 SOCKETS |
|  | FLOOR GROMMET C/W SINGLE SWITCHED
SOCKET OUTLET |

1. The drawing is subject to copyright and is not to be reproduced or part without approval.
2. Do not scale this drawing - check all dimensions on site.
3. The drawing shall be read in conjunction with the project specifications and all other contract documentation.
4. All dimensions are in millimeters unless otherwise stated.
5. Location of all equipment shall be confirmed/approved with the Client/Architect/Engineer prior to any installation
6. This drawing must be read in conjunction with Mechanical and Electrical performance specifications and all other drawings as issued by the Architect, Structural Engineer and Water Engineer and Consulting Engineer
7. The location of equipment is typical only, The Contractor shall perform all calculations to determine the exact quantity and agree the final calculations with the Architect.
8. This drawing shows the intended location of building services plant and service routes in such detail as to indicate the design. The drawing does not show the components that may be necessary to provide a full working installation.
9. The positions of connection points, accessories and building services items are approximate and shown for guidance to assist during the tendering process.
10. Fully co-ordinated drawings, Construction drawings and Builderswork drawings shall be produced by the contractor. Under no circumstances shall the drawings be used as installation drawings.

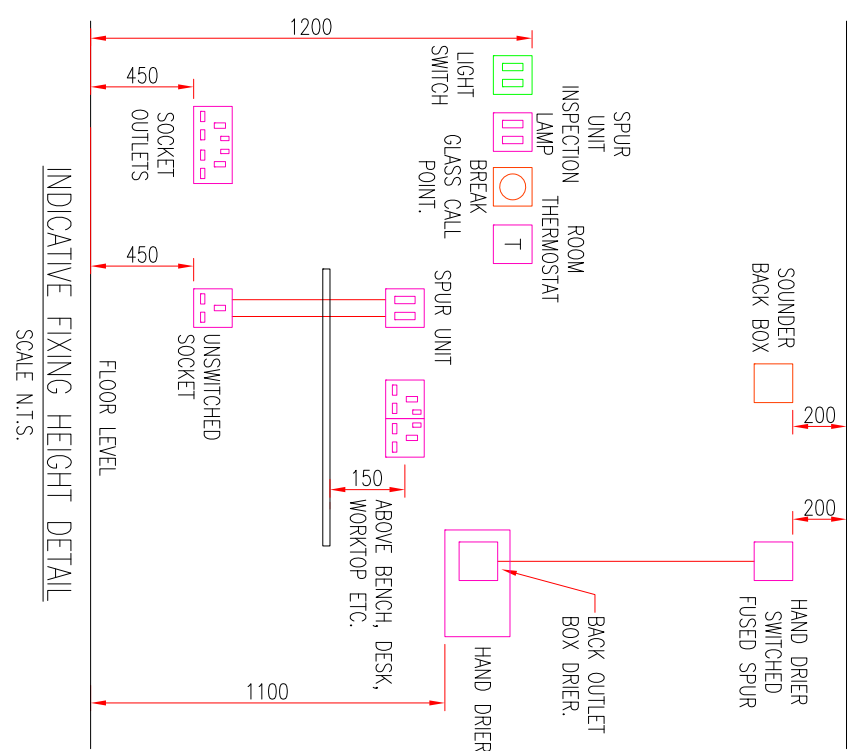

T1	29/01/21	TENDER ISSUE	KH
Rev:	Date:	Status/Amendments:	By:

40 KING STREET, MANCHESTER, M2 6BA
TEL: 0161 434 3103 EMAIL: office@wece.co.uk

ARTISAN

Project:
CABLE STREET, ANCOATS
MANCHESTER

Drawing Title:
ELECTRICAL SERVICES
SMALL POWER & COMMUNICATIONS LAYOUT
THIRD FLOOR

<i>Drawn By:</i> KH	<i>Checked By:</i> DW	<i>Cad By:</i> KH
<i>Scale:</i> 1:50	<i>Paper Size:</i> A1	<i>Date Created:</i> 08/04/2019
<i>Drawing Number:</i> WECE-286-E-104		<i>Drawing Revision:</i> T1