




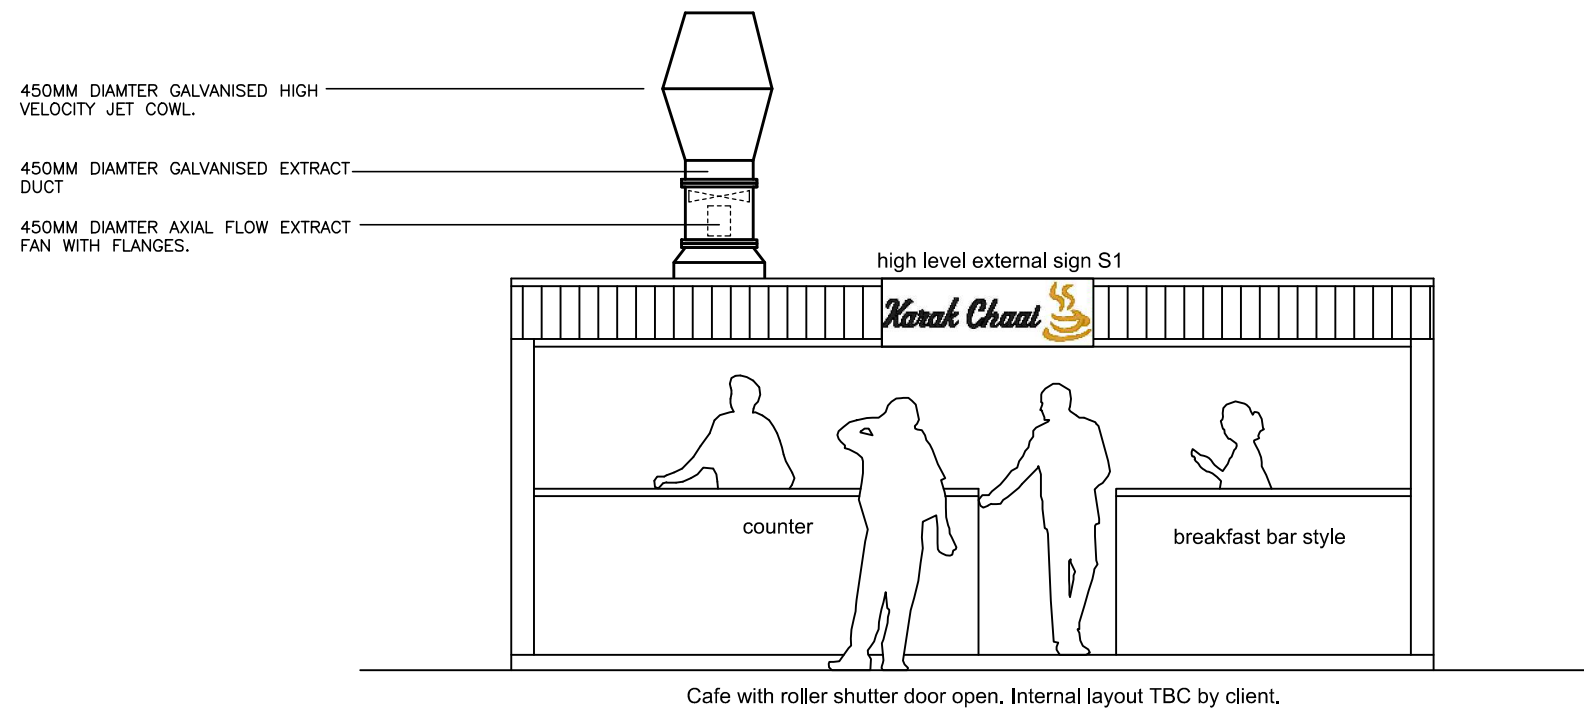


Proposed Front / East / Car Wash Elevation

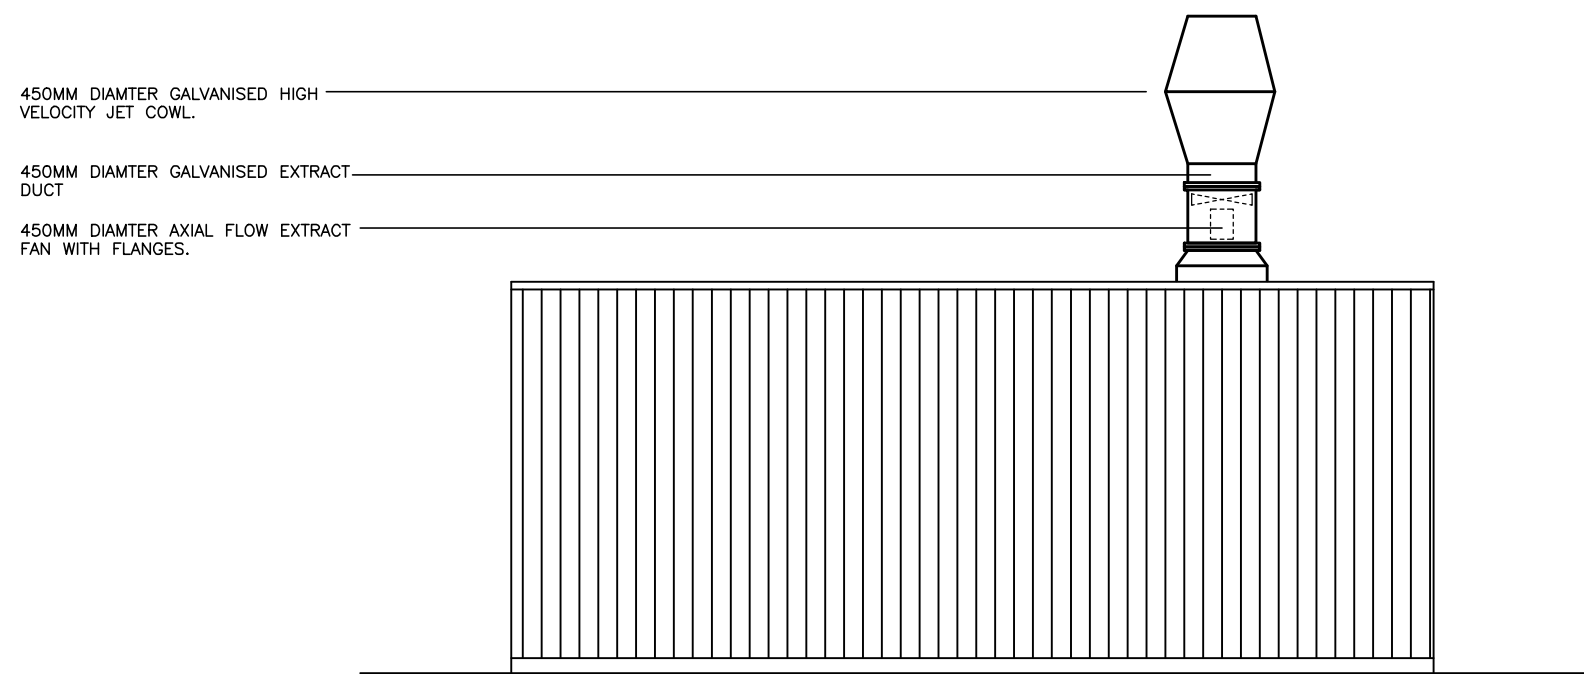

Proposed Rear / West / Road Elevation

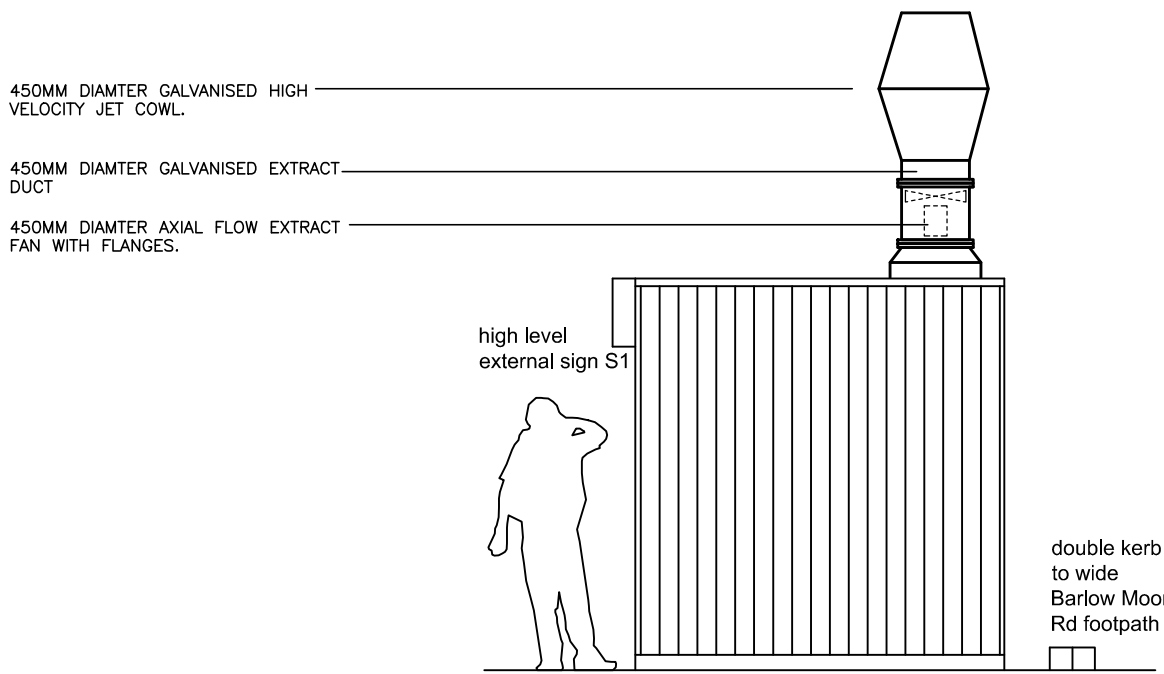

Proposed North Elevation

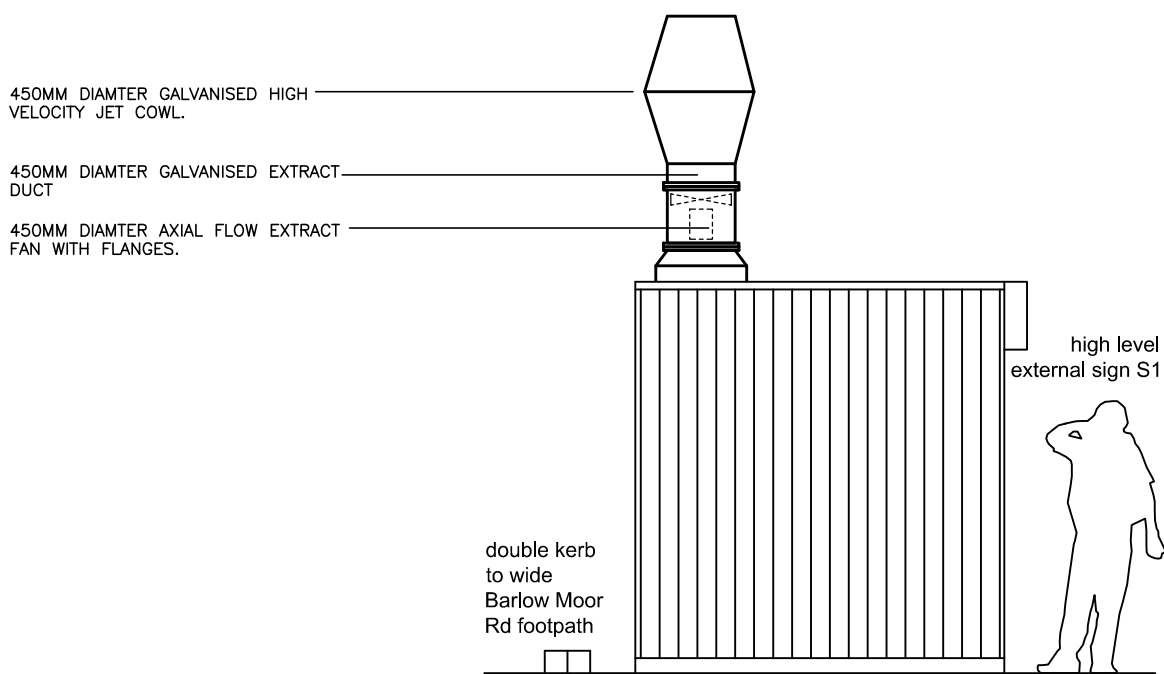

Proposed South Elevation

EXTRACT SPECIFICATION

COOKING EQUIPMENT LIST.

ELECTRICALLY HEATED DOUGHNUT FRYER = 700MM X 600MM
ELECTRICALLY HEATED TEA URN = 365MM X 365MM
ELECTRICALLY HEATED TEA URN = 365MM X 365MM
WALL BENCH = 1000MM X 650MM

DW172 AIR FLOW CALCULATION = 0.35M3/S
THE VELOCITY ACROSS THE CANOPY FACE IS HIGHER
THAN STANDARD INLINE WITH ODOUR IMPACT ASSESSMENT

EXTRACT CANOPY

STAINLESS STEEL EXTRACT CANOPY – 2400MM X 1200MM X 600MM HIGH
4 OFF 500MM X 500MM STAINLESS STEEL BAFFLE FILTERS
450MM DIAMTER GALVANISED EXTRACT DUCTWORK AND TERMINATING WITH A HIGH VELOCITY JET COWL
450MM DIAMTER AXIAL FLOW MAXFAN WITH FLANGES – SEE FAN DATA SHEET.

ODOUR CONTROL

EXTRACT SYSTEM TO BE FITTED WITH AN OZONE ODOUR CONTROL UNIT WHICH WILL BE SITED INTERNALLY WITHIN THE CATERING KITCHEN AND INJECT OZONE DIRECTLY INTO THE EXTRACT CANOPY FILTER BANK DUCTWORK TO DISCHARGE AT HIGH LEVEL – SEE ATTACHED SPECIFICATION SHEET

NOISE LEVELS

EXTRACT FAN = 49 DBA @ THREE METRES.

Rev.	Date.	Revision.	By.
MAINLAND CATERING EQUIPMENT LTD. Unit 1a, Fountain Mill, Church Street, Rakefoot, Haslingden, Rossendale, Lancashire, BB4 5RE Tel : 01706 244810 Fax: 01706 244811			
Client. KARAK CHAAI			
Job Title. 302 BARLOW MOOR ROAD, LONGSIGHT			
Drawing Title. PROPOSED EXTRACT SCHEME			Scale. 1:50
Drawn by. C. ASPDEN		Drg No. 7203-1	
Date. 28-10-20			