


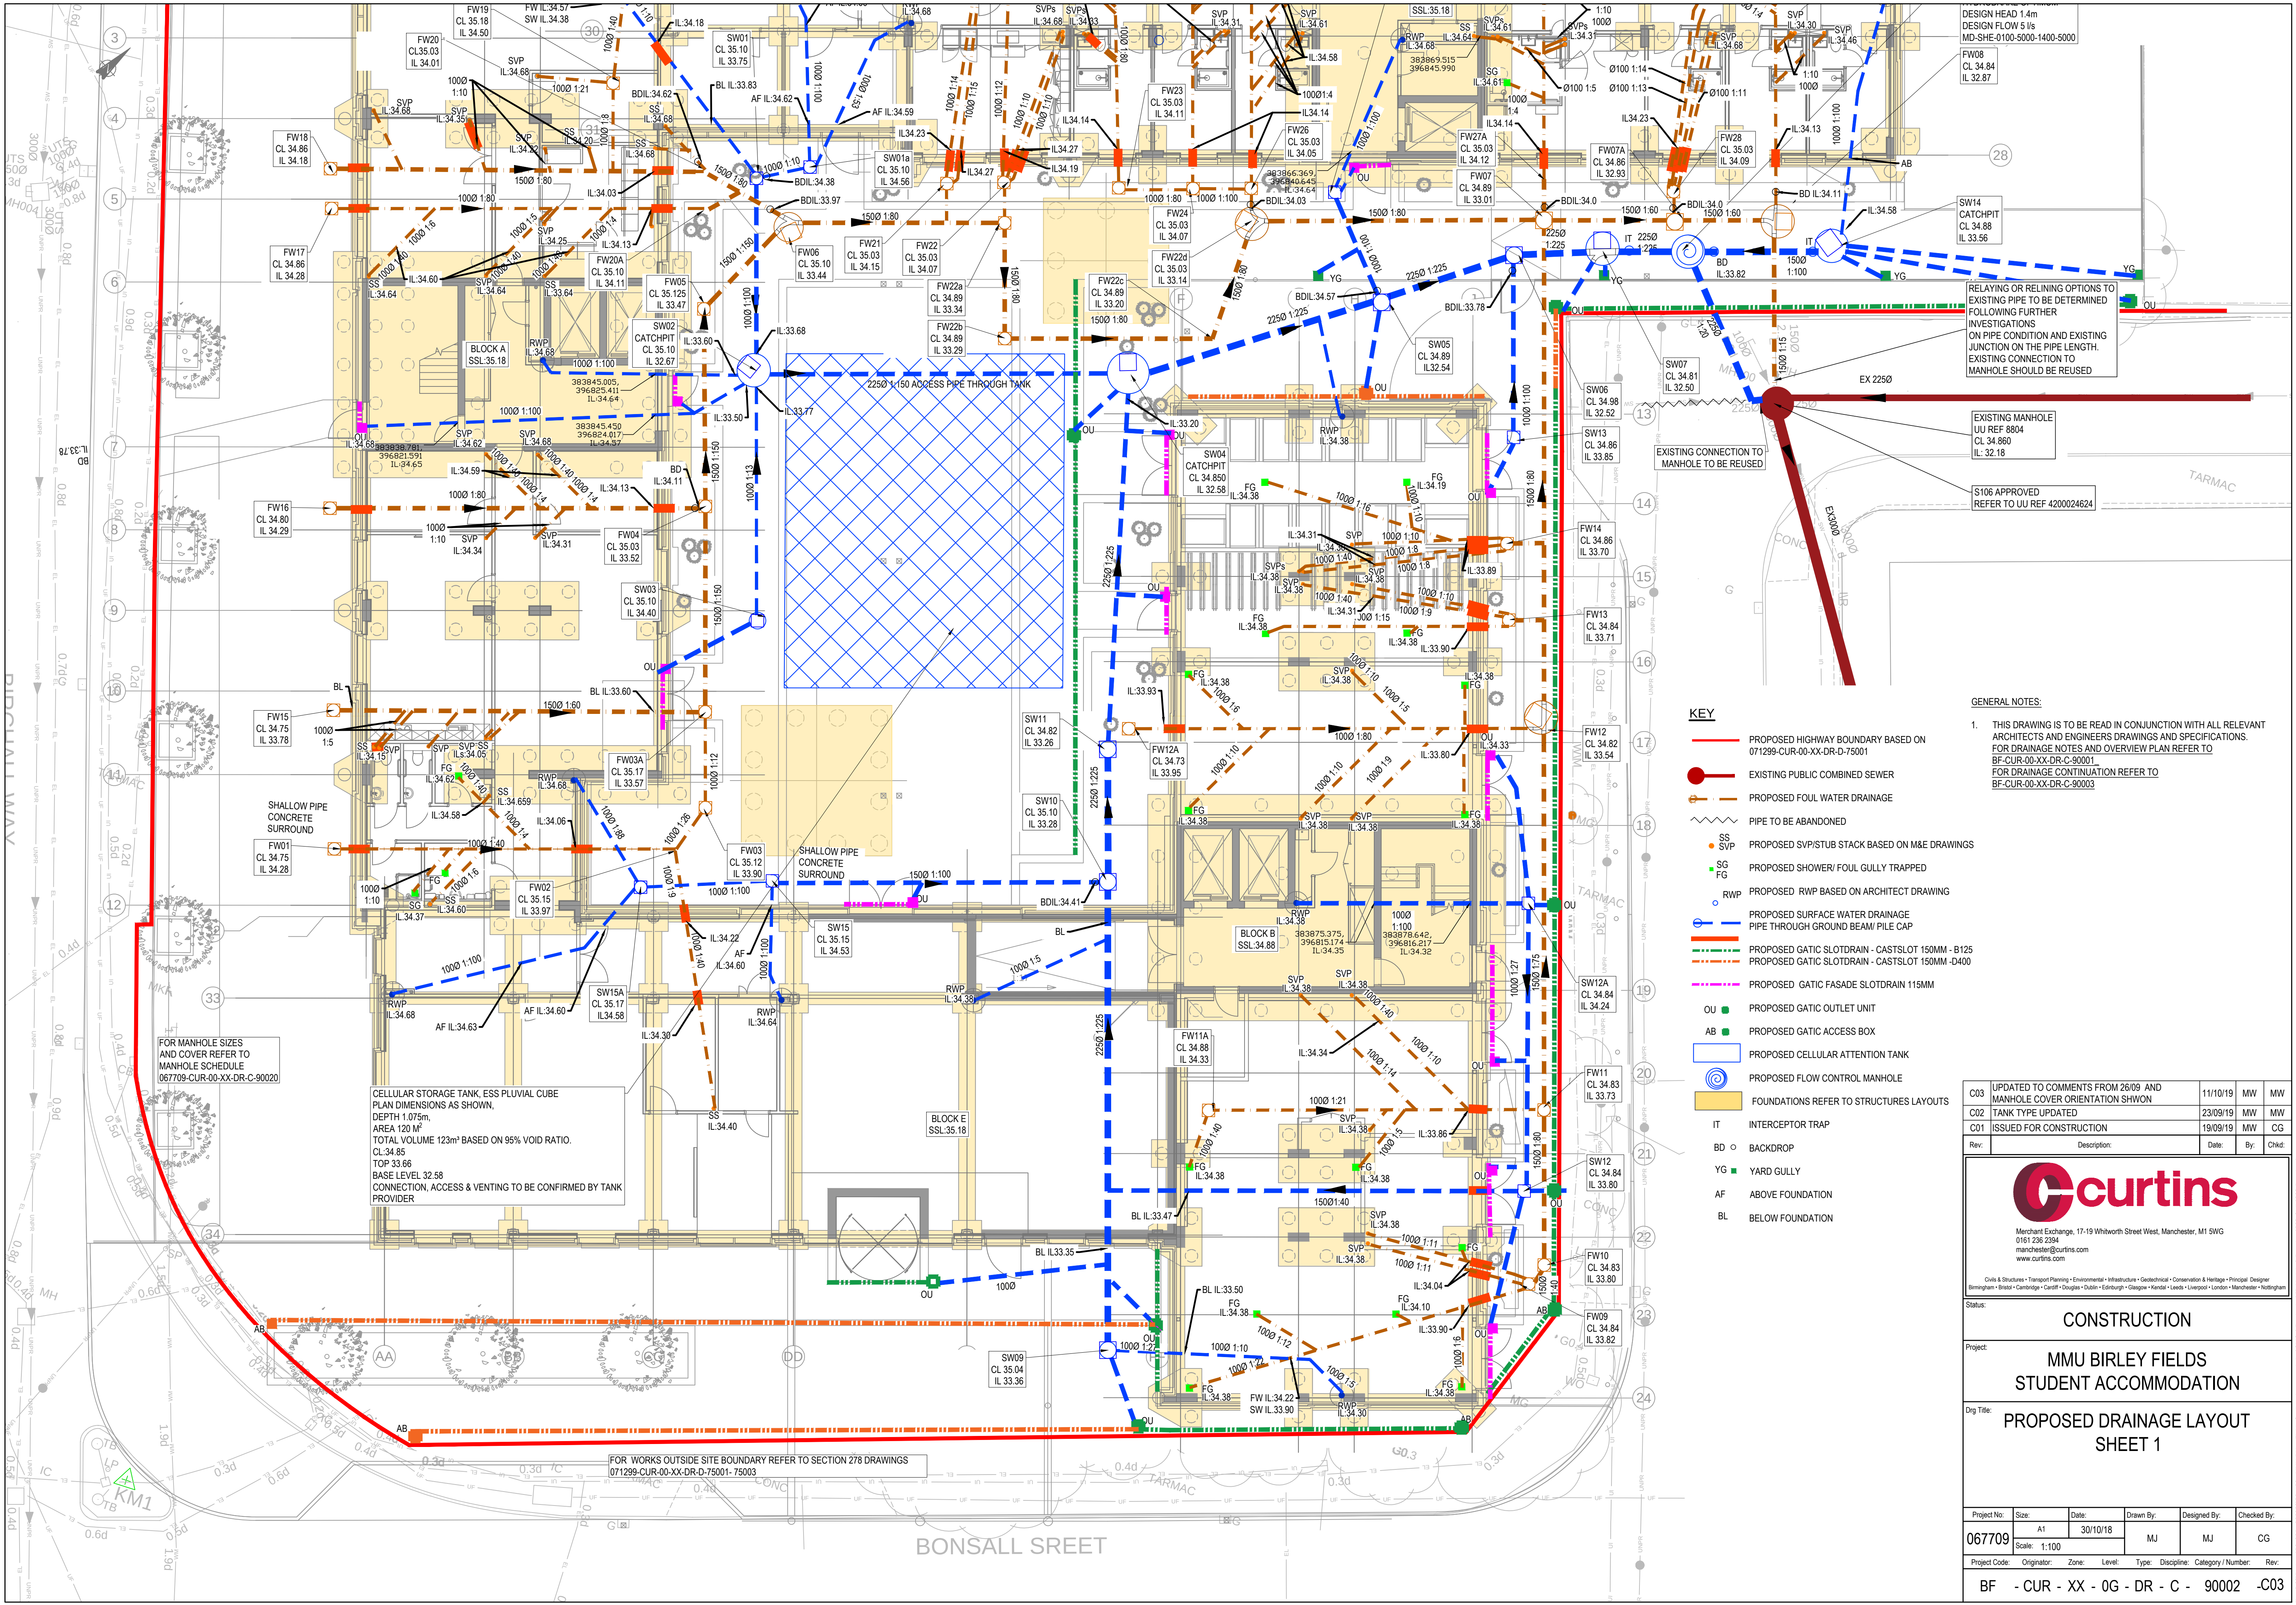

DESIGN HEAD 1.4m
DESIGN FLOW 5 l/s
MD-SHE-0100-5000-1400-5000

RELAYING OR RELINING OPTIONS TO EXISTING PIPE TO BE DETERMINED FOLLOWING FURTHER INVESTIGATIONS ON PIPE CONDITION AND EXISTING JUNCTION ON THE PIPE LENGTH. EXISTING CONNECTION TO MANHOLE SHOULD BE REUSED

EXISTING MANHOLE
UU REF 8804
CL 34.86
IL 32.18

S106 APPROVED
REFER TO UU REF 4200024624

KEY

- PROPOSED HIGHWAY BOUNDARY BASED ON 071299-CUR-00-XX-DR-D-75001
- EXISTING PUBLIC COMBINED SEWER
- PROPOSED FOUL WATER DRAINAGE
- PIPE TO BE ABANDONED
- PROPOSED SVP/STUB STACK BASED ON M&E DRAWINGS
- PROPOSED SHOWER/ FOUL GULLY TRAPPED
- PROPOSED RWP BASED ON ARCHITECT DRAWING
- PROPOSED SURFACE WATER DRAINAGE
- PIPE THROUGH GROUND BEAM/ PILE CAP
- PROPOSED GATIC SLOTDRAIN - CASTSLOT 150MM - B125
- PROPOSED GATIC SLOTDRAIN - CASTSLOT 150MM - D400
- PROPOSED GATIC FASADE SLOTDRAIN 115MM
- PROPOSED GATIC OUTLET UNIT
- PROPOSED GATIC ACCESS BOX
- PROPOSED CELLULAR ATTENTION TANK
- PROPOSED FLOW CONTROL MANHOLE
- FOUNDATIONS REFER TO STRUCTURES LAYOUTS
- INTERCEPTOR TRAP
- BACKDROP
- YARD GULLY
- ABOVE FOUNDATION
- BELOW FOUNDATION

GENERAL NOTES:
1. THIS DRAWING IS TO BE READ IN CONJUNCTION WITH ALL RELEVANT ARCHITECTS AND ENGINEERS DRAWINGS AND SPECIFICATIONS. FOR DRAINAGE NOTES AND OVERVIEW PLAN REFER TO BF-CUR-00-XX-DR-C-90001 FOR DRAINAGE CONTINUATION REFER TO BF-CUR-00-XX-DR-C-90003

C03	UPDATED TO COMMENTS FROM 26/09 AND MANHOLE COVER ORIENTATION SHOWN	11/10/19	MW	MW
C02	TANK TYPE UPDATED	23/09/19	MW	MW
C01	ISSUED FOR CONSTRUCTION	19/09/19	MW	CG
Rev:	Description:	Date:	By:	Chkd:



Merchant Exchange, 17-19 Whitworth Street West, Manchester, M1 5WG
0161 235 2334
manchester@curtins.com
www.curtins.com

Status:

CONSTRUCTION

Project: MMU BIRLEY FIELDS STUDENT ACCOMMODATION
Orig Title: PROPOSED DRAINAGE LAYOUT SHEET 1

Project No:	Size:	Date:	Drawn By:	Designed By:	Checked By:
067709	A1	30/10/18	MJ	MJ	CG
Scale:	1:100				

Project Code: BF - CUR - XX - 0G - DR - C - 90002 -C03