


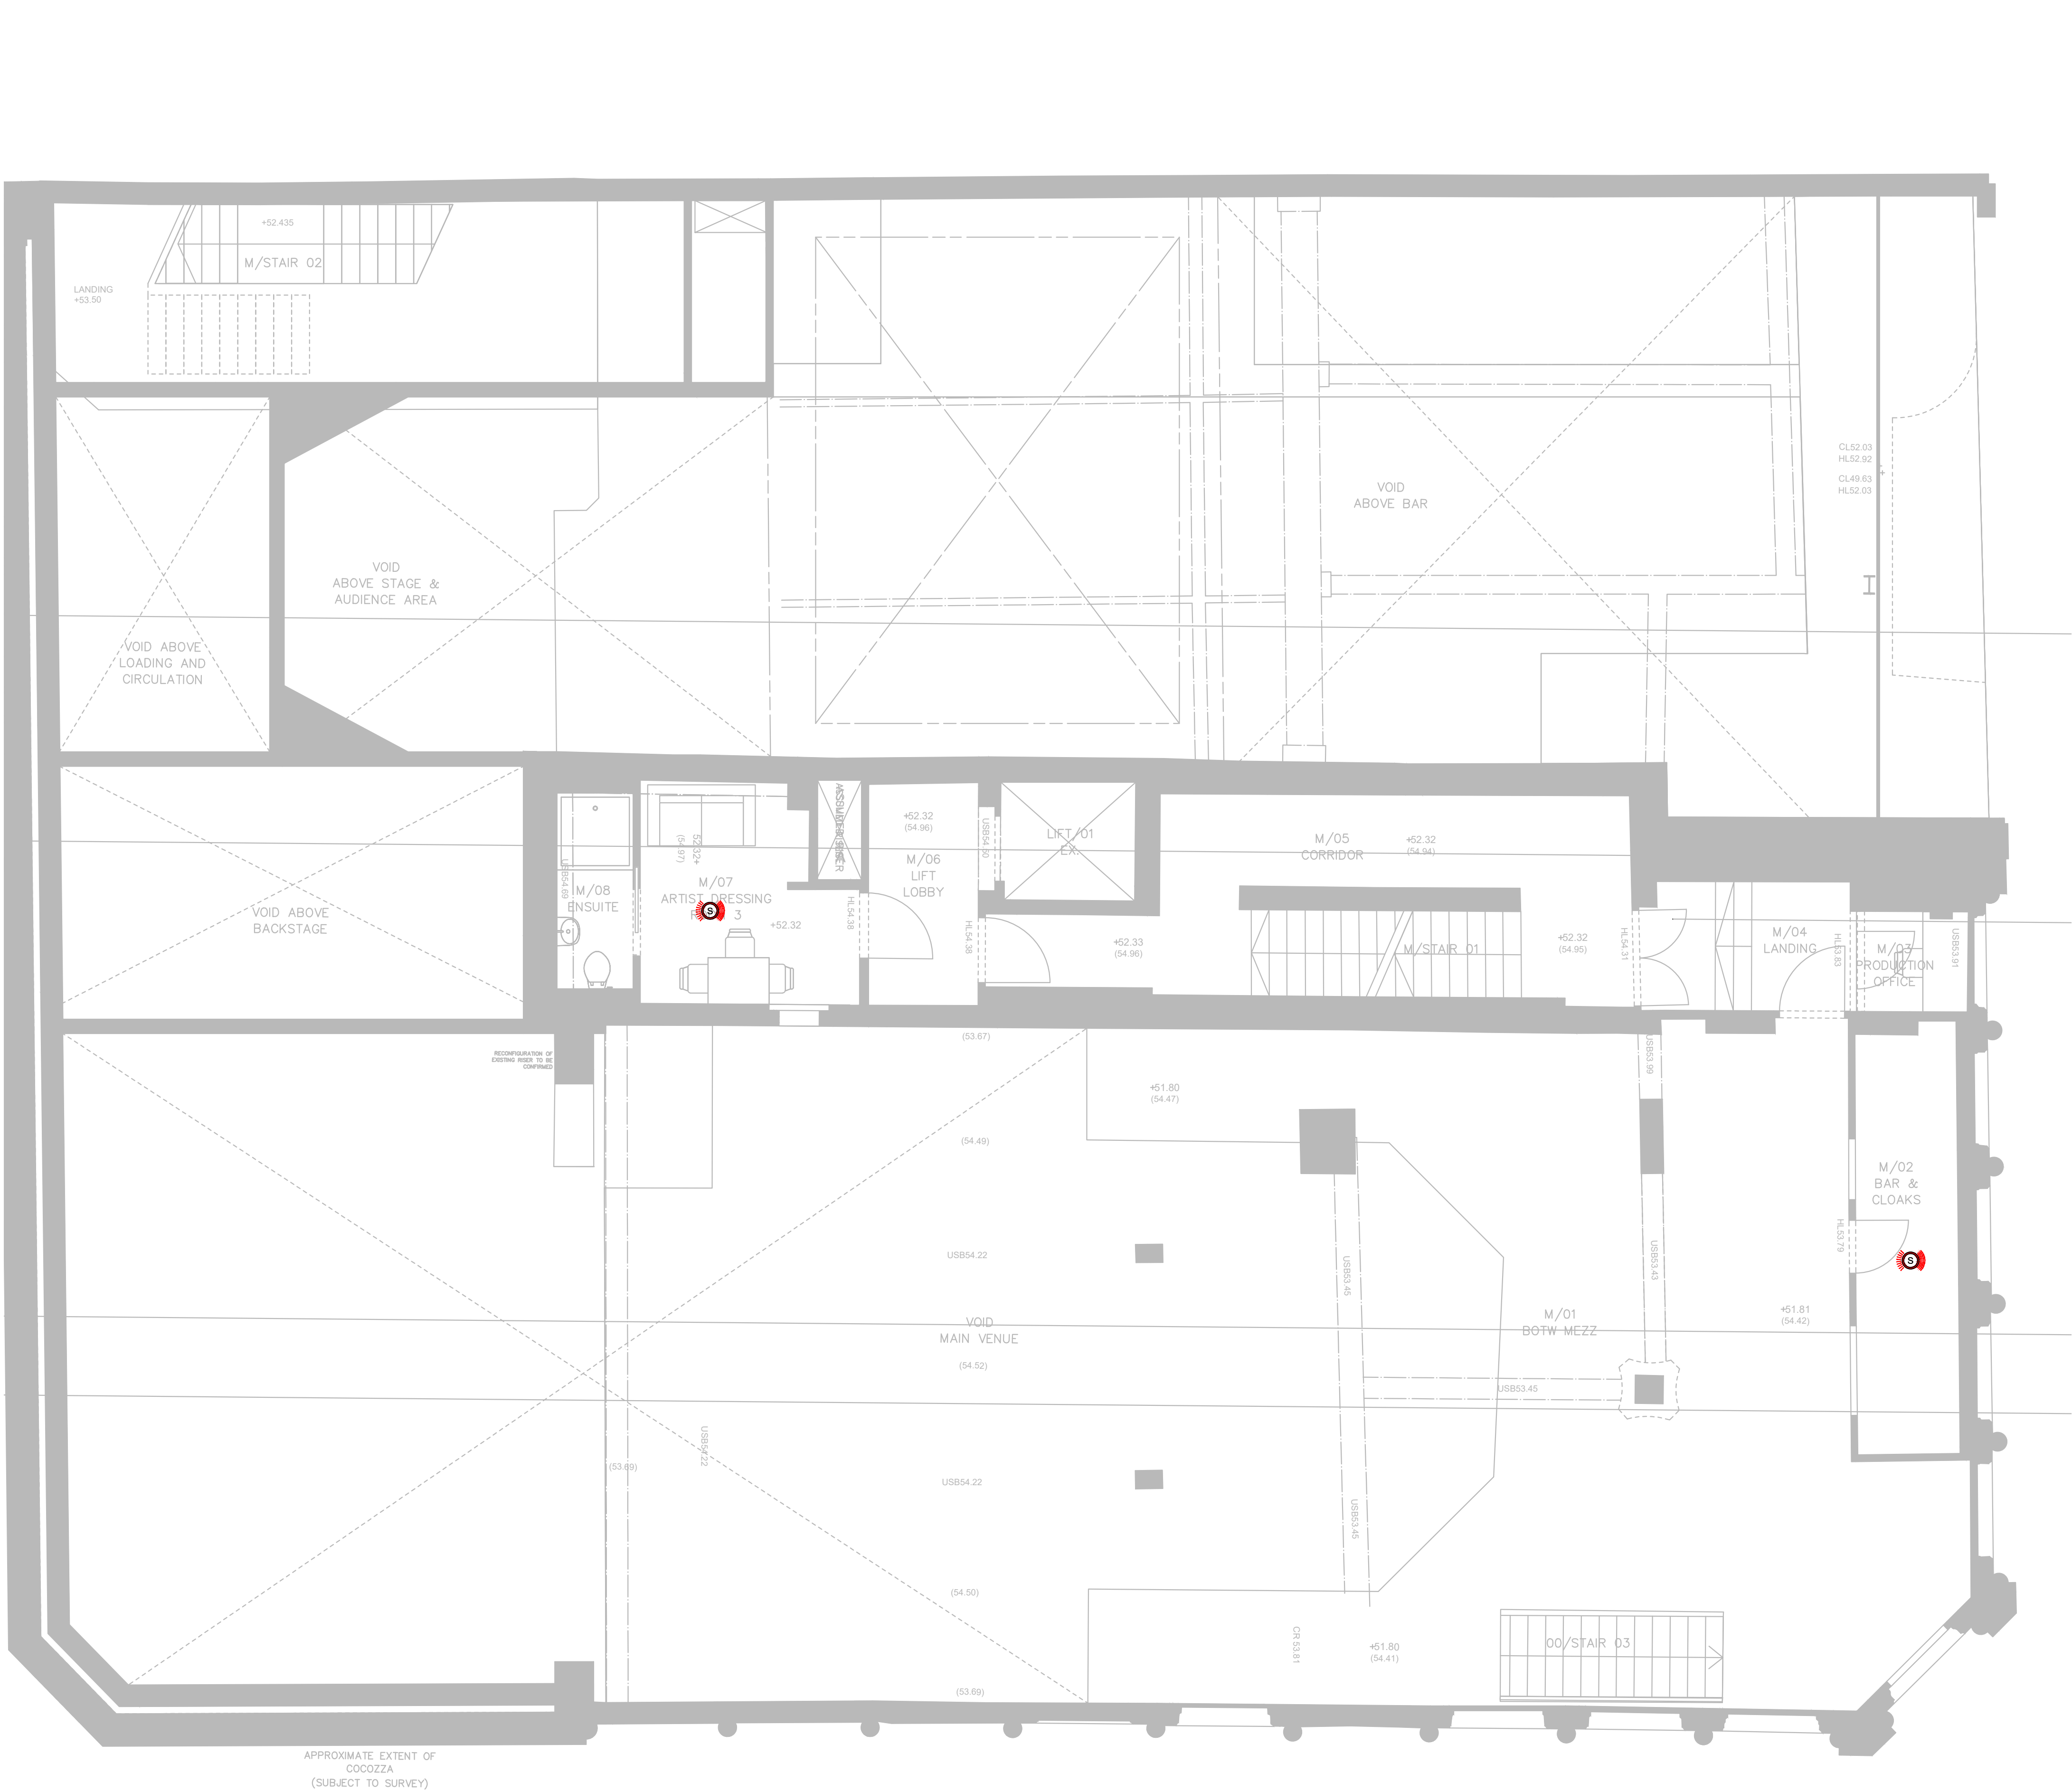

- LEGEND
- PROTEC SMOKE DETECTOR - 6000PLUS/DP
 - PROTEC HEAT DETECTOR - 6000PLUS/HT
 - PROTEC SMOKE DETECTOR WITH SOUNDER - 6000PLUS/DP/S
 - PROTEC SMOKE DETECTOR WITH STROBE - 6000PLUS/DP/CO/VAD
 - PROTEC SMOKE DETECTOR WITH SOUNDER & STROBE - 6000PLUS/DP/HTCO/SVAD
 - PROPOSED PROTEC COMBINED SOUNDER & FLASHING BEACON OF 6000 PLUS RANGE PROD REF - 6000/7SW/VAD
 - PROPOSED FIRE ALARM SOUNDER OF PROTEC 6000 PLUS RANGE PROD REF - 6000/5SW/2
 - PROPOSED ADDRESSABLE MANUAL CALL POINT OF PROTEC 6000 PLUS RANGE PROD REF - 6000/MCP/WP
 - EXISTING PROTEC ADDRESSABLE FIRE ALARM PANEL TO BE UPGRADED TO 6500.
 - PROTEC FIRE ALARM SINGLE CHANNEL INTERFACE PROD REF - 6000/MCCO
 - EXISTING OMNISCARE DISABLED REFUGE PANEL
 - ADDRESSABLE DISABLED CALL W.C. KIT, COMES COMPLETE AS OVERDOOR LIGHT AND SOUNDER, RESET BUTTON AND PULL CORD, RESET BUTTON TO BE MOUNTED AT 1500mm AFL AS INDICATED. KIT TO ALSO INCLUDE ADDITIONAL INTERFACE FOR EACH W.C. TO FACILITATE ADDRESSING OF EQUIPMENT. INTERFACE TO BE LOCATED ADJACENT THE W.C. BEING SERVED. CABLING TO BE OF ENHANCED 4 CORE 1.5sqmm FP200 FIRE RATED CABLE AS A LOOP WITH OTHER OUTSTATIONS AND DIS W.C. SYSTEMS BETWEEN PANEL AND OUTSTATIONS. PRODUCT REF - BVOC6PG
 - QUAD INTRUDER ALARM PIR DETECTOR TEXECOM PROD REF - PREMIER ELITE DT
 - PAYTON DOOR ACCESS PROXIMITY CARD READER MOUNTED AS INDICATED 950mm AFL PROD REF - DS1013
 - SECURITY DOOR CONTACT
 - CDV MAGNETIC DOOR LOCK PROD REF - CS31
 - NEW HK VISION TURBO MODEL IP CCTV CAMERA MOUNTED AT HIGH LEVEL UNLESS STATED PROD REF - DS-2CE56H0T-VP13ZF
 - NEW HK VISION TURBO MODEL IP CCTV CAMERA MOUNTED AT HIGH LEVEL UNLESS STATED PROD REF - DS-2CD2542FWD-I
 - NEW HK VISION IP65 RATED EXTERNAL IP CCTV CAMERA MOUNTED AT HIGH LEVEL UNLESS STATED TO BE CABLED WITH NEW CATE CABLE PROD REF - DS-2CE18H5T-IT5E
 - EXISTING INTERNAL ANALOGUE CCTV CAMERAS WHICH ARE TO BE UPGRADED TO A NEW HK VISION DIGITAL CAMERA PROD REF - DS-2CE56H0T-VP13ZF
 - EXISTING EXTERNAL ANALOGUE CCTV CAMERAS WHICH ARE TO BE UPGRADED TO A NEW HK VISION DIGITAL CAMERA PROD REF - DS-2CE18H5T-IT5E
 - EXISTING SECURITY ALARM PANEL TO BE RETAINED
 - ELECTRIC DOOR CONTACT
 - SECURITY KEYPAD
 - DOOR ACCESS VIDEO INTERCOM UNIT TBC

- GENERAL NOTES
- THIS DRAWING IS COPYRIGHT AND SHALL NOT BE REPRODUCED WITHOUT PERMISSION
 - THIS DRAWING IS TO BE READ IN CONJUNCTION WITH ALL OTHER DISCIPLINES, DRAWINGS, SCHEDULES AND SPECIFICATIONS, LEGENDS AND STANDARD DETAILS
 - DIMENSIONS GOVERN ON ALL DRAWINGS AND DETAILS. SHOULD ANY DISCREPANCIES BE FOUND ON THIS DRAWING AND ANY ASSOCIATED DRAWINGS OR SPECIFICATIONS, THIS SHOULD BE BROUGHT TO THE ATTENTION OF BRENTWOOD DESIGN IMMEDIATELY
 - CONTRACTORS MUST CHECK AND VERIFY ALL INFORMATION / DIMENSIONS / LEVELS IN CONJUNCTION WITH ALL RELEVANT DRAWINGS AND ACTUAL SITE CONDITIONS BEFORE COMPLETING ANY MANUFACTURING / INSTALLATION DRAWINGS OR COMMENCING SITE INSTALLATION WORK
 - DO NOT SCALE FROM THIS DRAWING
- ALL LEVELS/DIMENSIONS TO BE CHECKED ON SITE BY CONTRACTOR.
- NOTES
- ALL ITEMS OF WORK TO BE EXECUTED IN A NEAT AND WORKMANLIKE MANNER.
 - ADJACENT PROTECTION SHALL BE PROVIDED TO ALL NEW SERVICES AND FINISHES.
 - ALL WORKS TO BE COMPLETED IN ACCORDANCE WITH THE SPECIFICATION AND DRAWINGS.
 - ALL CABLING WORKS SHALL BE COMPLETED BY THE ELECTRICAL CONTRACTOR. FINAL COMMISSIONING WORKS SHALL BE COMPLETED BY THE APPROVED SPECIALIST ASSOCIATED WITH THE MANUFACTURER OF THE EQUIPMENT.
 - THE SYSTEM HAS BEEN DESIGNED IN ACCORDANCE WITH BS5839 PART1 AND SHALL BE INSTALLED IN ACCORDANCE WITH THE SAME STANDARD.
 - ALL NEW FIRE ALARM CABLING SHALL BE COMPLETED USING 1.5SQMM ENHANCED SOFT SKIN FIRE RATED CABLING. ALL DETECTORS, SOUNDERS AND INTERFACE UNITS WITHIN THE BUILDING ARE WIRED ON MULTI-LOOP WIRING. ALL CABLING SHALL BE TAKEN FROM THE BUILDING FIRE ALARM CONTROL PANEL.
 - THE CONTRACTOR IS TO TEST THE SYSTEM PRIOR TO MAKING ALTERATIONS TO PROVE THE INTEGRITY OF DEVICES AND CABLING. ALL FAULTS TO BE REPORTED PRIOR TO COMMENCING WORKS.
 - ALL NEW DEVICES TO BE COMPATIBLE WITH THE EXISTING PROTEC FIRE ALARM PANEL.
 - ALL CABLING TO BE COMPLETED WITHOUT JOINTS OTHER THAN AT PANEL AND EQUIPMENT LOCATIONS.
 - COVERS TO BE PROVIDED TO ALL MANUAL CALL POINTS TO PREVENT ACCIDENTAL OPERATION OF THE FIRE ALARM SYSTEM.
 - ALL DOOR ACCESS PROXIMITY READERS TO BE INTERFACED WITH FIRE ALARM SYSTEM.
 - CONTRACTOR IS TO ENGAGE THE SERVICES OF PROTEC TO UNDERTAKE ALL WORKS TO THE FIRE ALARM SYSTEM.
 - ALL SOUND SYSTEMS TO SHUT DOWN ON 2ND STAGE FIRE ALARM ACTIVATION
 - ALL NEW AFD DEVICES TO COME WITH BASES FROM 6000PLUS RANGE
 - COVERS TO BE PLACED AND MAINTAINED OVER AFD'S DURING WORKS
 - CABLING TO BE REROUTED TO NEW RISER LOCATION AND LOOP LEADS REPLACED WHERE REQUIRED
 - CCTV CABLING TO BE CAT5 AND TO RUN TO NEW SERVER ROOM ON CABLE TRAY WHERE AVAILABLE TO TERMINATE INTO DVR EQUIPMENT
 - ALL AFD'S TO COME WITH BASES
 - ALL TESTING AND COMMISSIONING TO BE INCLUDED
 - ALL DIMENSIONS IN MILLIMETERS UNLESS SPECIFIED WITH MOUNTING HEIGHTS TO THE UNDERSIDE OF THE ACCESSORY
 - UNLESS SHOWN, ALL EXISTING DEVICES ARE TO BE RETAINED. CABLING IS TO BE ADAPTED TO ACCOMMODATE THE NEW DEVICES AND TO MAINTAIN THE LOOP INTEGRITY
 - TO BE REA IN CONJUNCTION WITH : ELECTRICAL SPECIFICATION 5453-65-64-03
 - THE EXISTING FIRE ALARM DETECTION TO THE BOTW AREA IS TO BE RETAINED AND LARGELY REMAIN UNALTERED

TOL	24/07/20	TENDER ISSUE	IDS	SD
Rev	Date	Description	Dwn	Chk

BRENTWOOD CONSULTING ENGINEERS

www.brentwoodgroup.co.uk
The Learning Building, Moor Lane, Leeds, LS2 7PF
Jacton House, Hood Street, Manchester, M4 6WV T: 0161 318 3336
T: 0161 503 4620

CLIENT
BAND ON THE WALL

PROJECT
THE BAND ON THE WALL

DRAWING TITLE
ELECTRICAL SERVICES
PROPOSED FIRE ALARM AND SECURITY
MEZZANINE LEVEL

DRAWING STATUS
TENDER

DRAWN BY	CHK BY	DATE	SCALE	REVISION
IDS	SD	02/04/20	1:50	@A1
5453-E-64-03				T01