


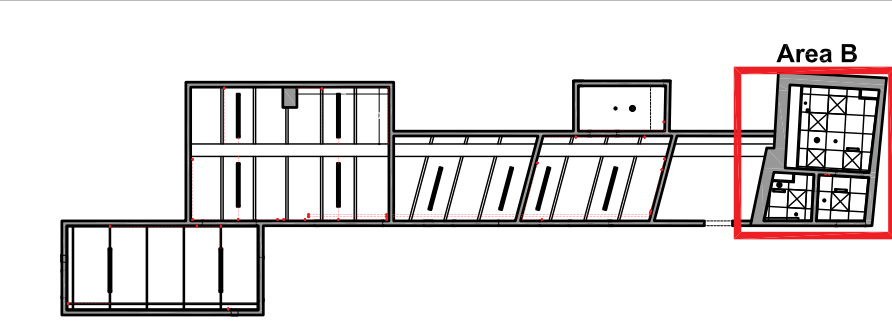

Location Plan
Scale 1 : 250



Area B - Existing Female & Male WC Reflected Ceiling Plan
Scale 1 : 25

©

DO NOT SCALE. Use figured dimensions only. Contractor is to check all dimensions before commencement of works. This drawing is copyright. This data to be used as well file only - not as live data. This drawing must only be used for the purpose for which it is supplied.

KEY

Existing Suspended Grid Ceiling

Existing Suspended Plaster Ceiling

Existing Unknown M&E vertical conduit/piping.

Existing Unknown M&E horizontal conduit/piping.

/	16/10/20	TP	FOR LISTED BUILDING CONSENT	AF	RS	
no.	date	by	revision details	Ckd	App	

STR  ALA architects

Studio 103
The Courtyard Royal Mills
Ancoats Manchester M4 5BA

Tel: 0161 236 5866
Fax: 0161 236 5884
E: office@strzarch.co.uk

client



NETWORK RAIL TECHNICAL APPROVAL
AUTHORISED FOR ISSUE:
DESIGNER.....
CHECKER.....
AUTHORISER (CRE).....
DATE.....

APPROVED FOR FORM (N/A)
CEM.....
DATE.....

project

ELR: COL MILEAGE: 189m 29ch. OS Ref: SJ840974
MANCHESTER OXFORD ROAD
TRAIN STATION

drawing status

FOR LISTED BUILDING CONSENT

drawing title

AREA B
EXISTING STAFF WC
REFLECTED CEILING PLAN

drawn by	date	checked by	date
TP	16/10/20	AF	16/10/20
CRE Approved by	date	CEM Reviewed by	date
RS	16/10/20		

Network Rail dwg no.	revision no.	sht no.
	/	1 of 1

consultant dwg no.	scale	sht size
2876-MCO-LB006	1 : 25	A1