


FALCONER CHESTER HALL

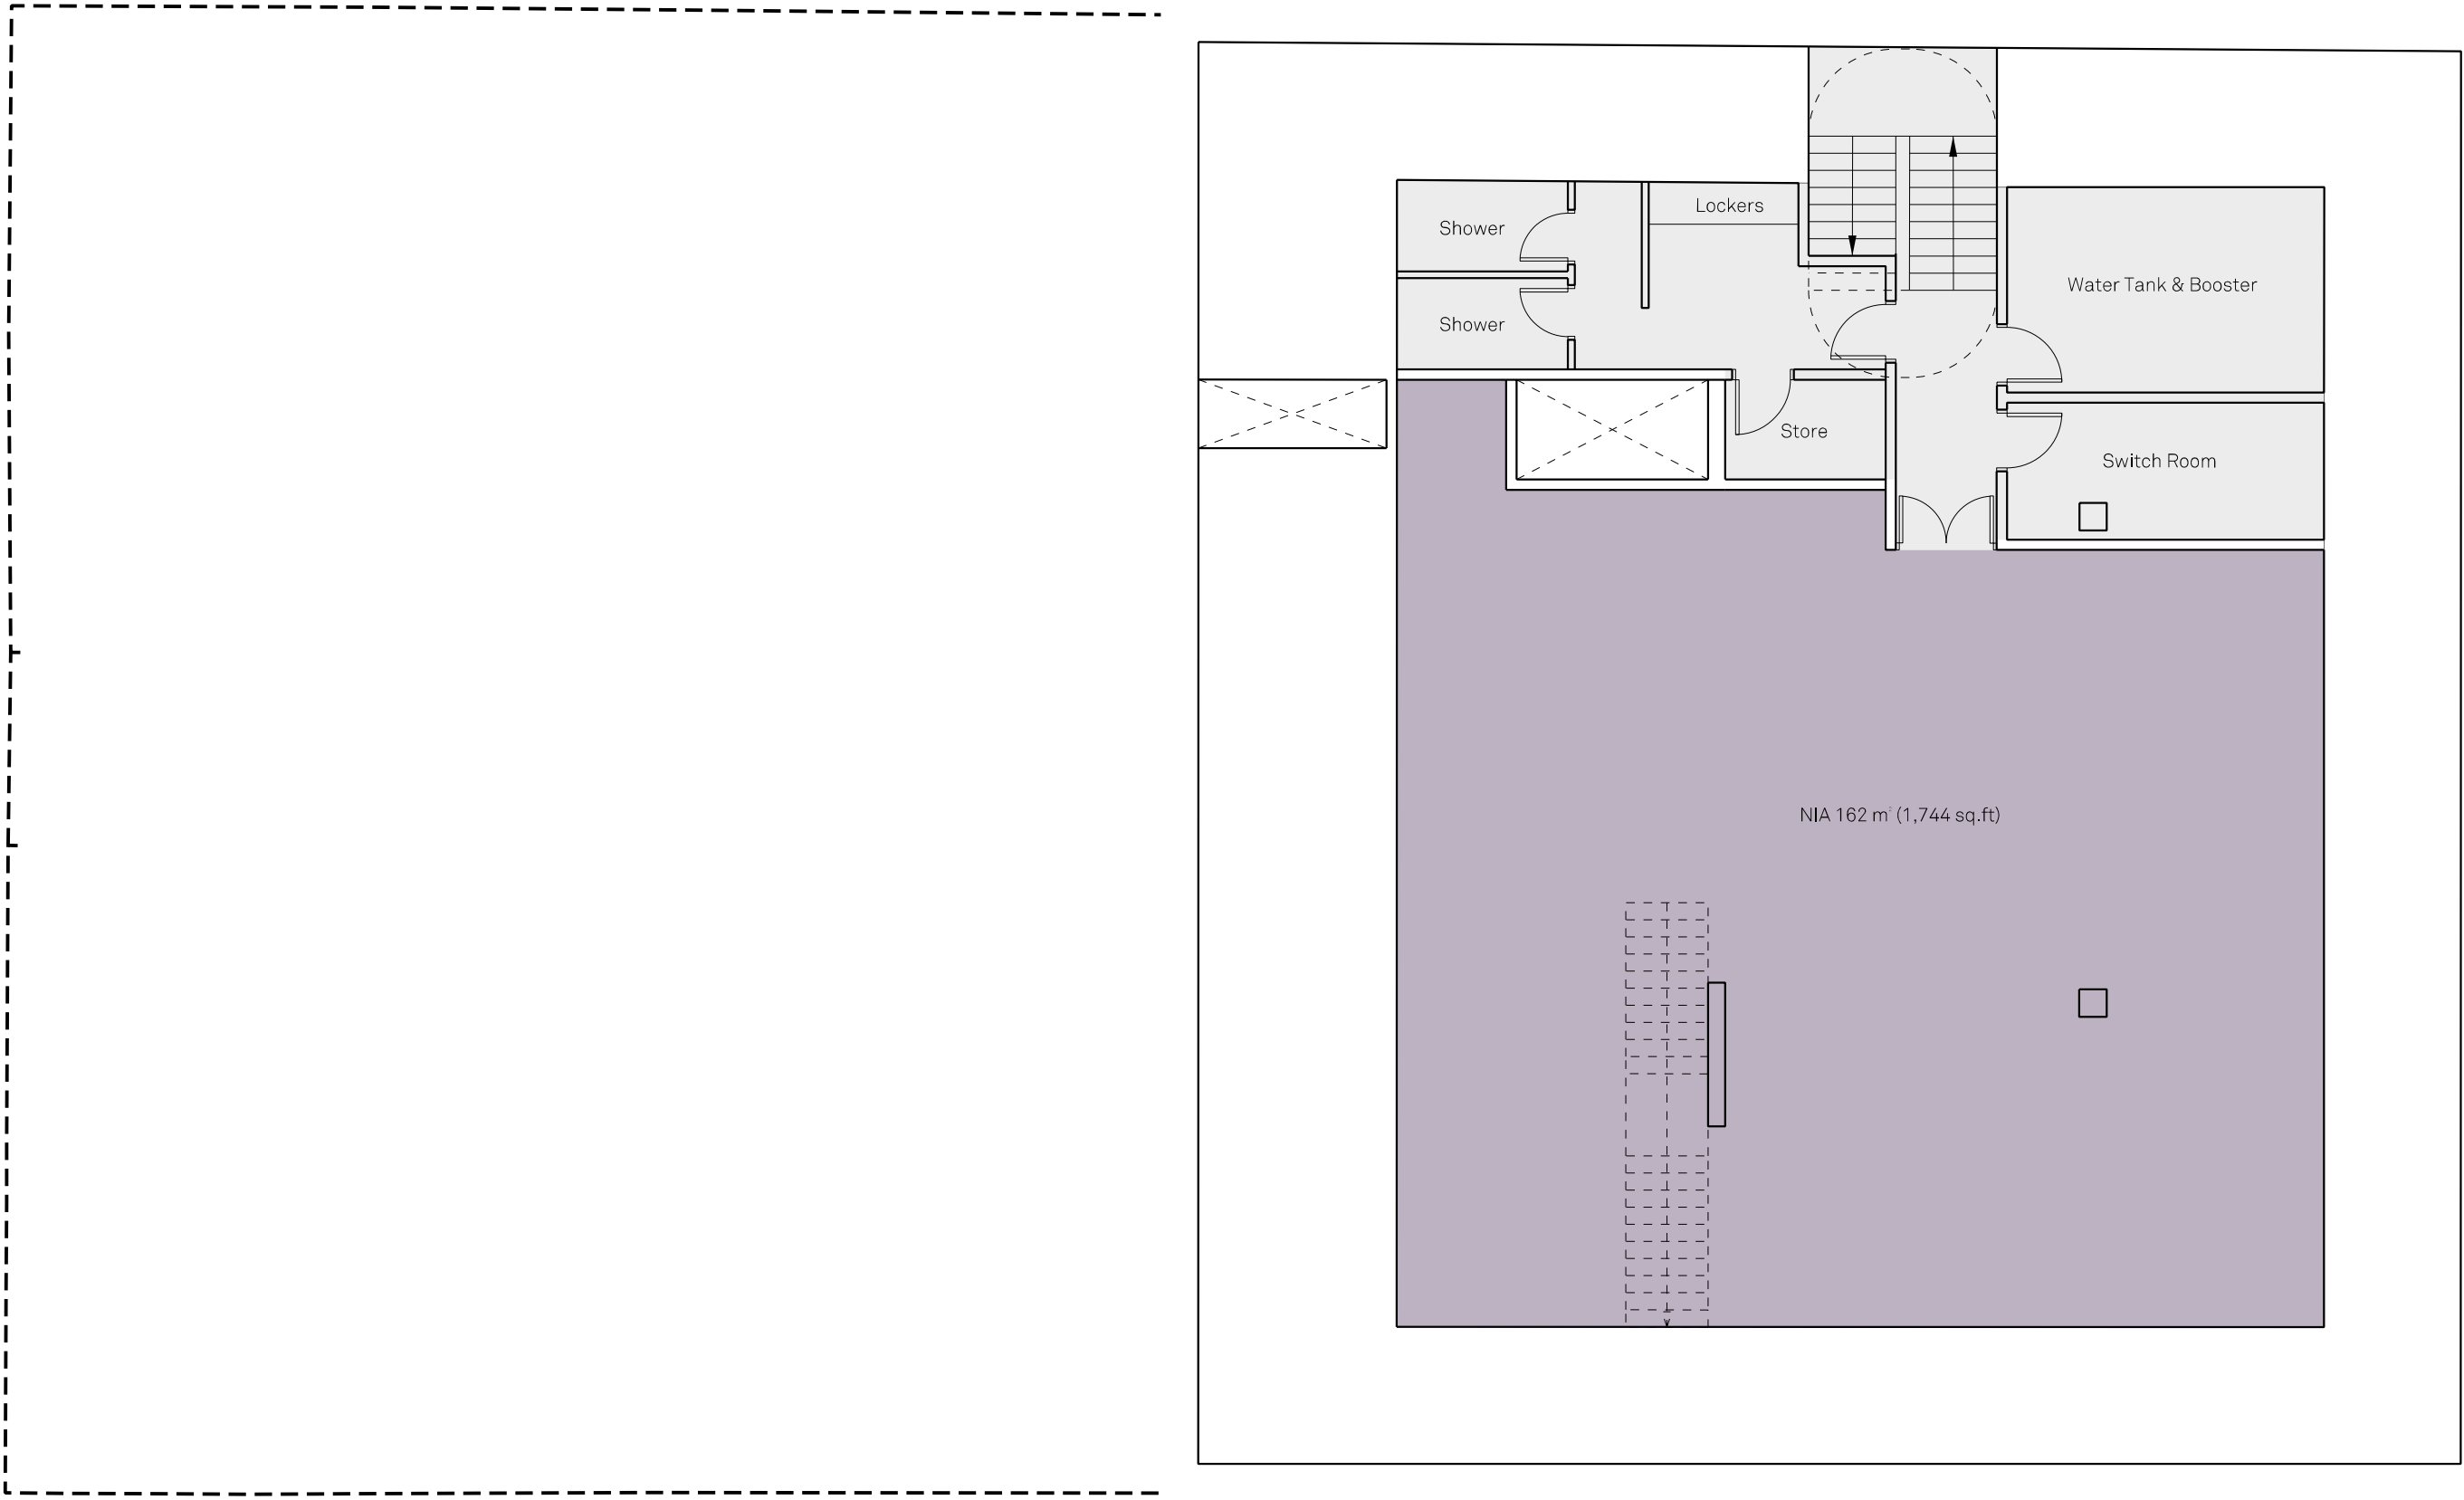

London | Liverpool | Manchester | Kuala Lumpur | Telephone +44(0)151 243 5800

REV.A 08.05.17 Planning Submission

Project Title
27, Dale Street, Manchester
Drawing Title
Proposed Basement Floor Plan
Client
Kamrani Commercial Property Ltd
Drawn By
DAG
Scale
1:100 @ A1
Date
28.04.17
Project No.
P16-019
Drawing No.
02-03-01A

www.fcharchitects.com
© F.C.H.