


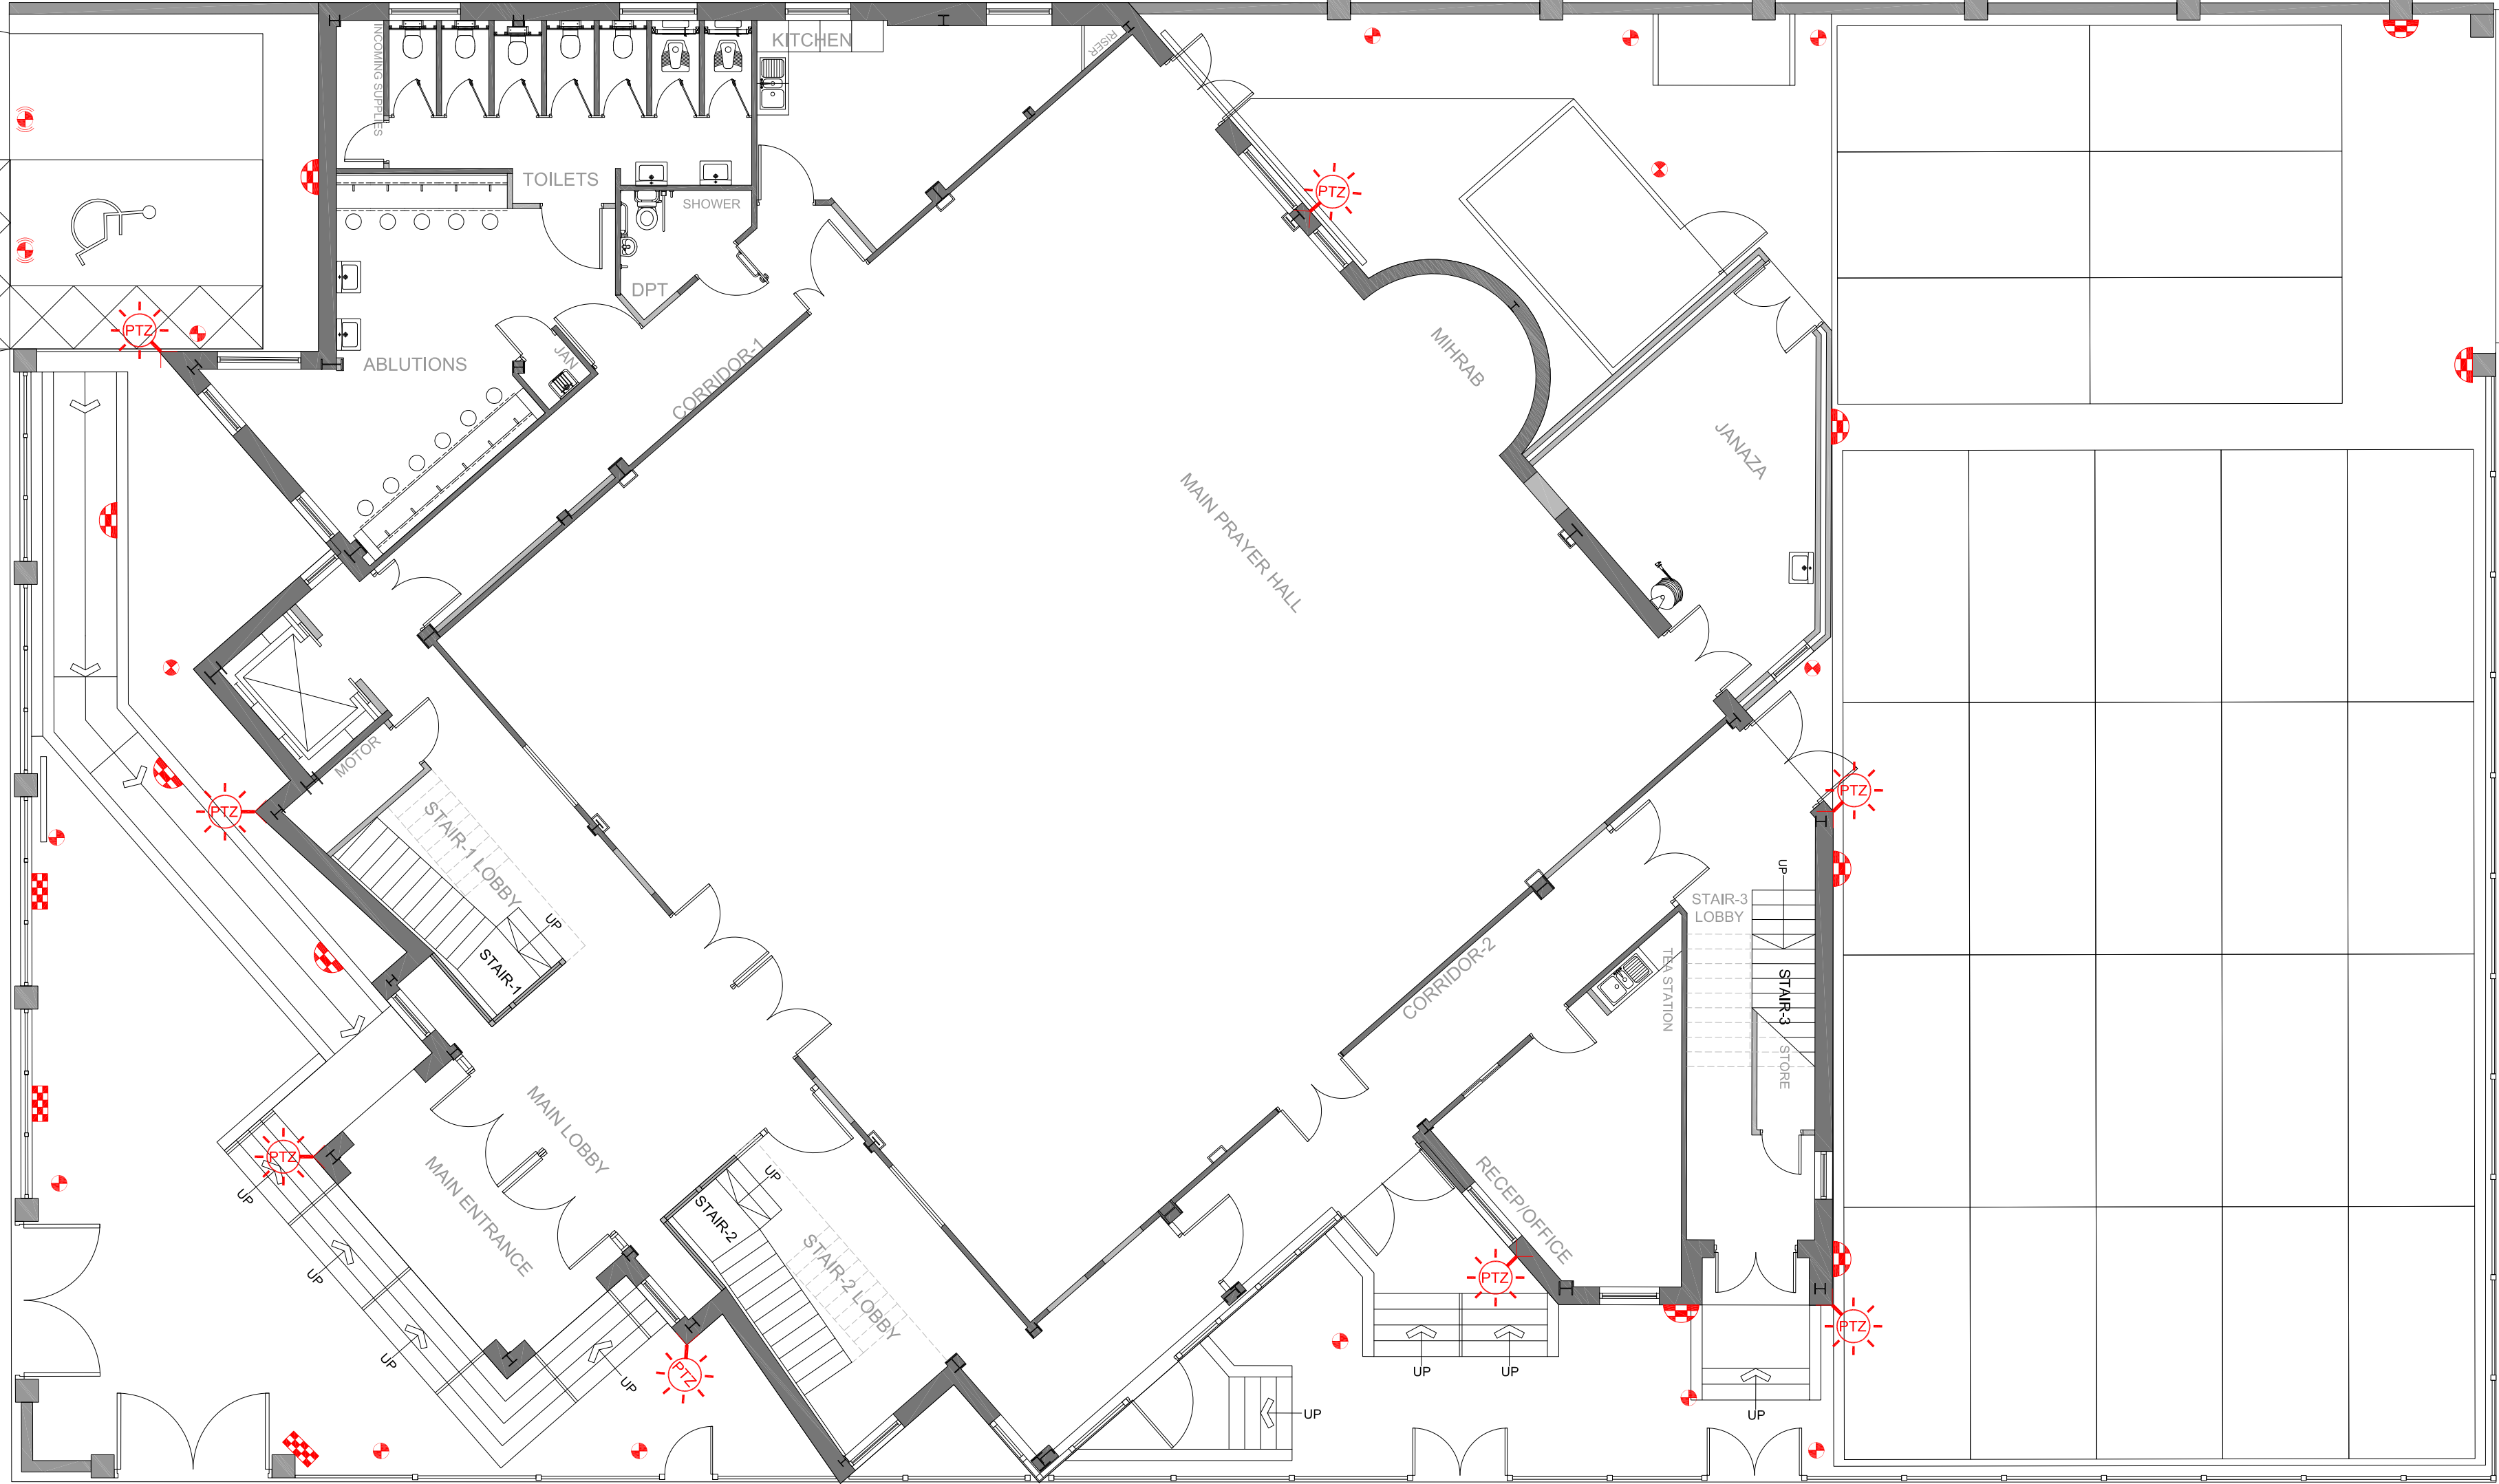

SITE PLAN - GROUND FLOOR PLAN

BERESFORD ROAD SIDE

EXTERNAL LIGHTING KEY (ALL LED)	
	COLUMN MOUNTED LED
	GROUND (OR COLUMN) MOUNTED
	WALL (OR FLOOR) MOUNTED
	LED BOLLARD
	LED RISING BOLLARD (FOB OPERATED)
	WALL MOUNTED
	CEILING MOUNTED
	CCTV CAMERAS (PTZ)
	CCTV




LIGHTING BOLLARDS




WALL LIGHTS AROUND THE BUILDING & THE CAR PARK



FLOODLIGHT TO DOME & MINARET

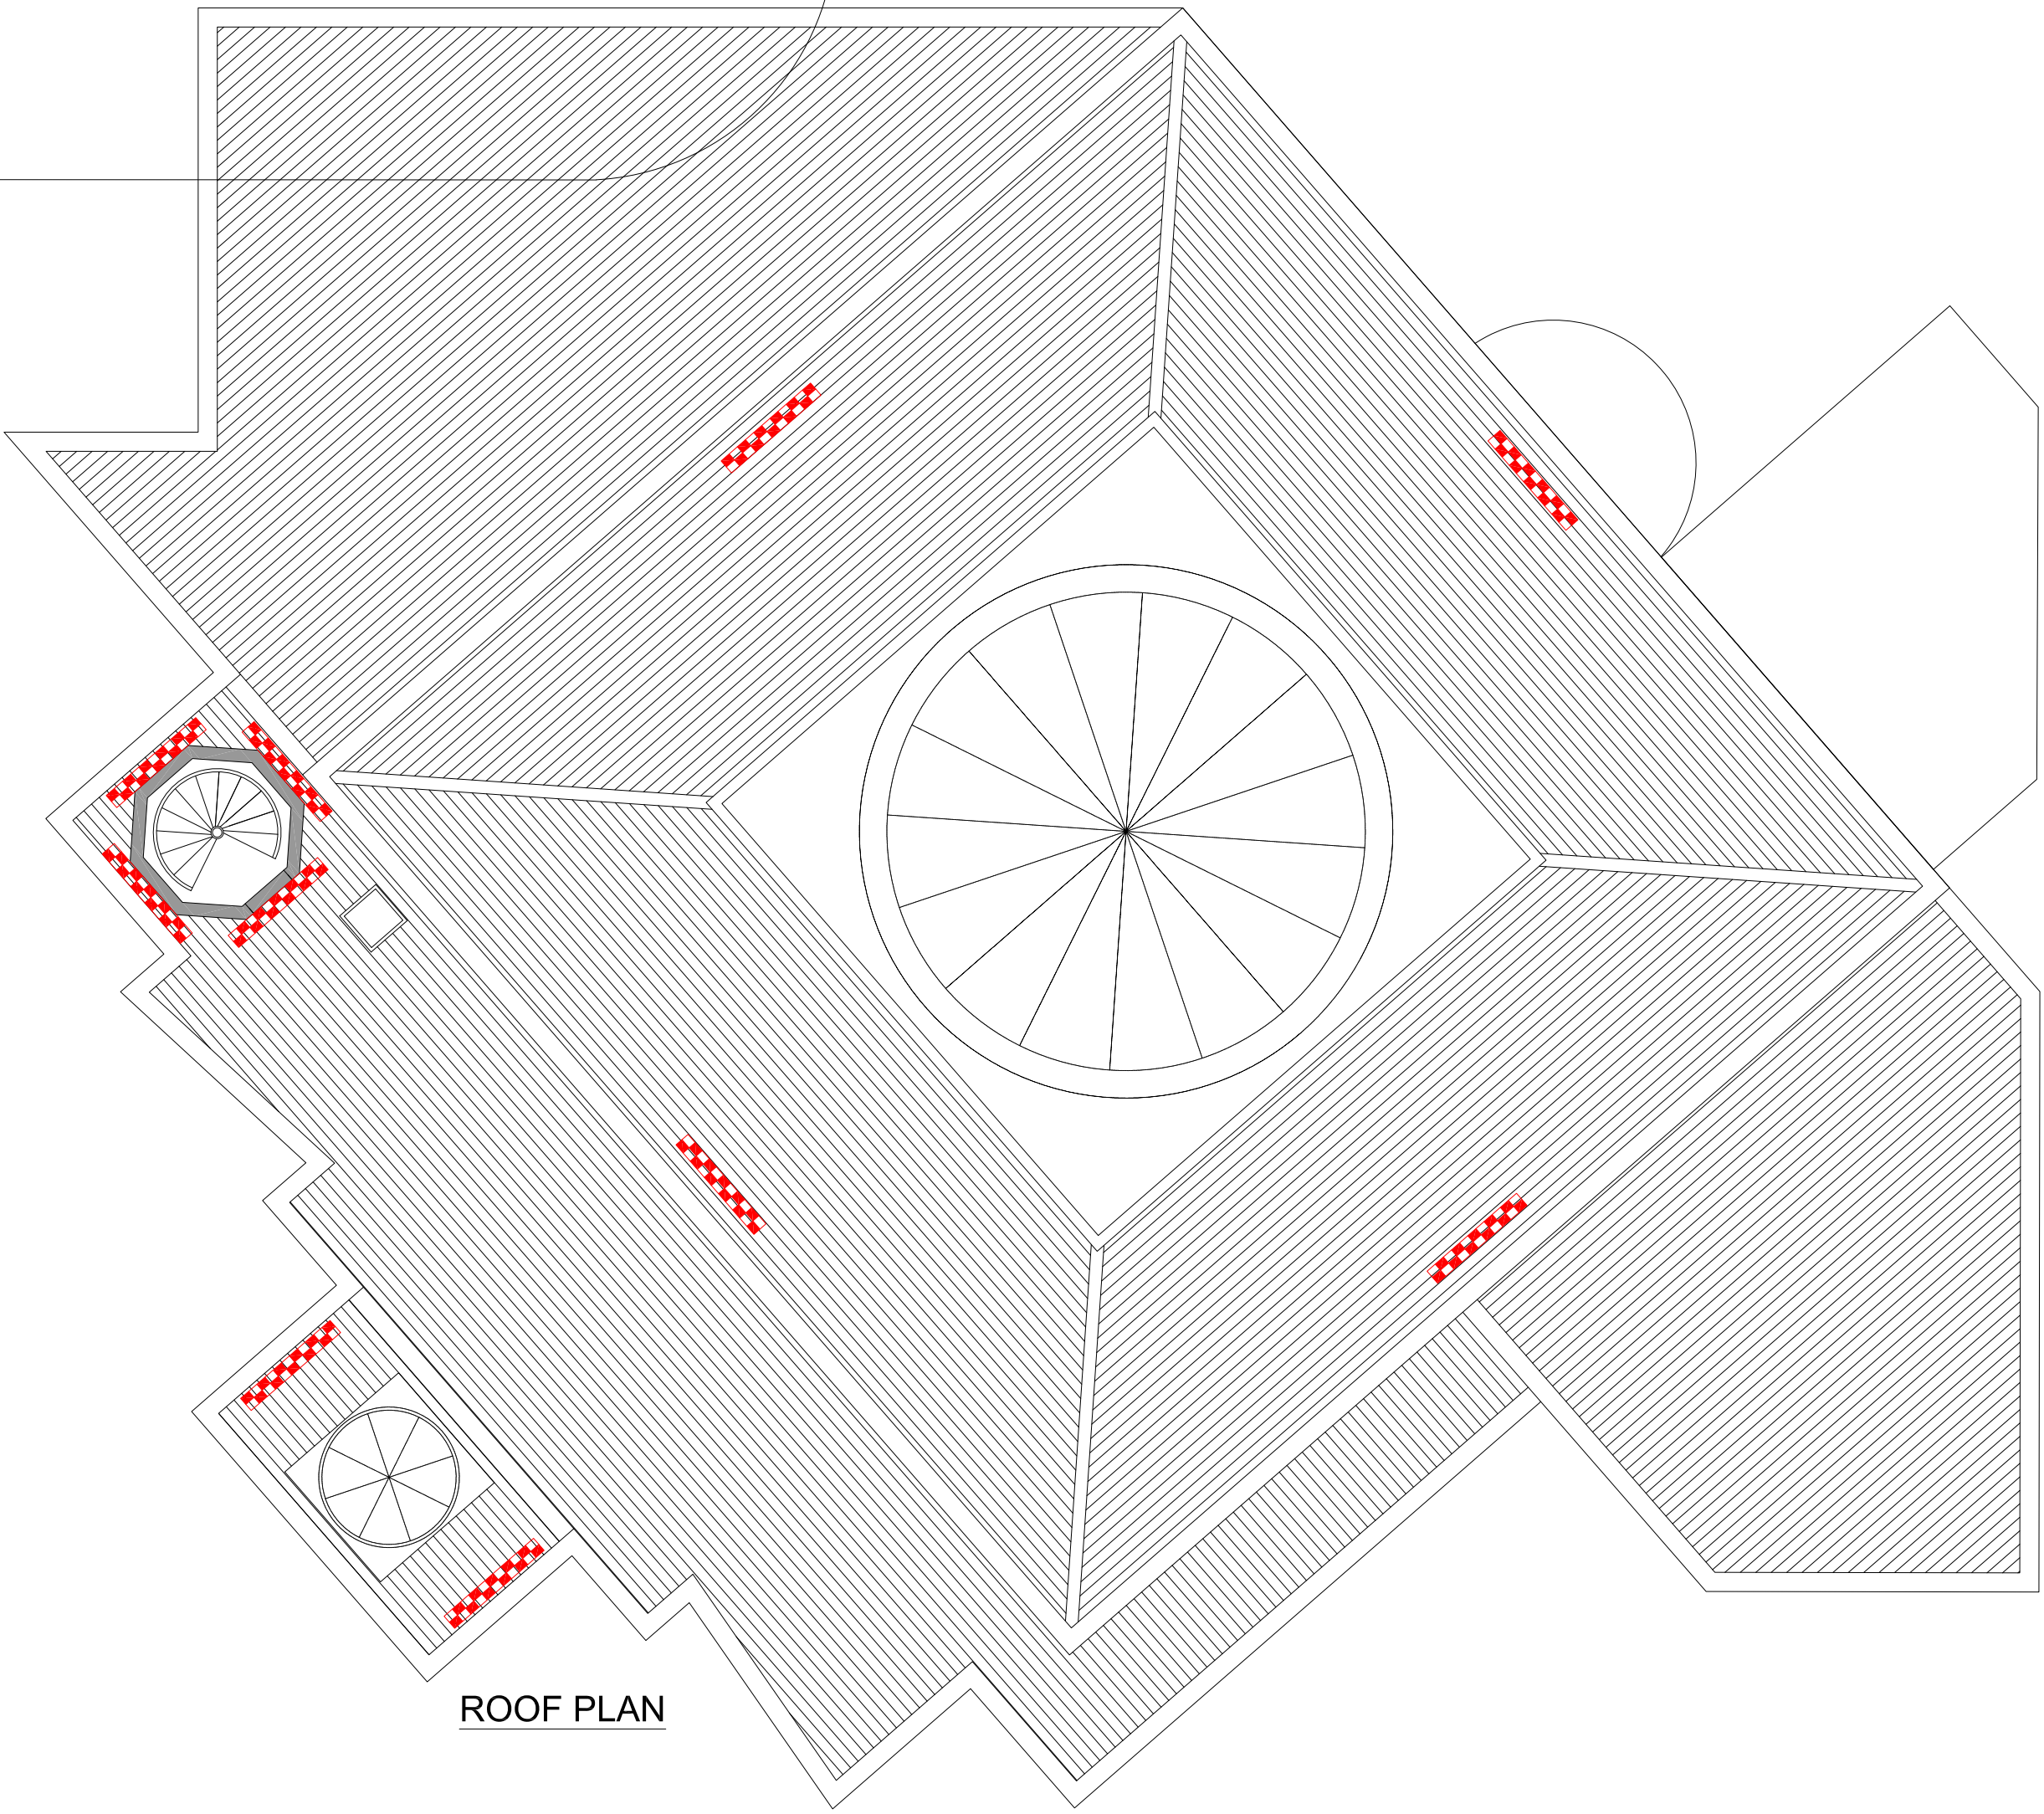

ROOF PLAN

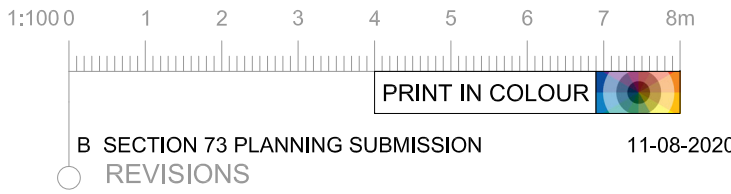

CLIENT	MAKKI MASJID TRUST
PROJECT NAME	THE NEW MAKKI MASJID 125 BERESFORD ROAD MANCHESTER M13 0TA
DRAWING TITLE	SITE PLAN EXTERNAL LIGHTING & CCTV
DRAWN / CHECK	AS/GWC
DATE	DEC 2019
PROJECT	218-185
DRAWING No.	E07
SCALE	1:100 @ A1
REV.	B