


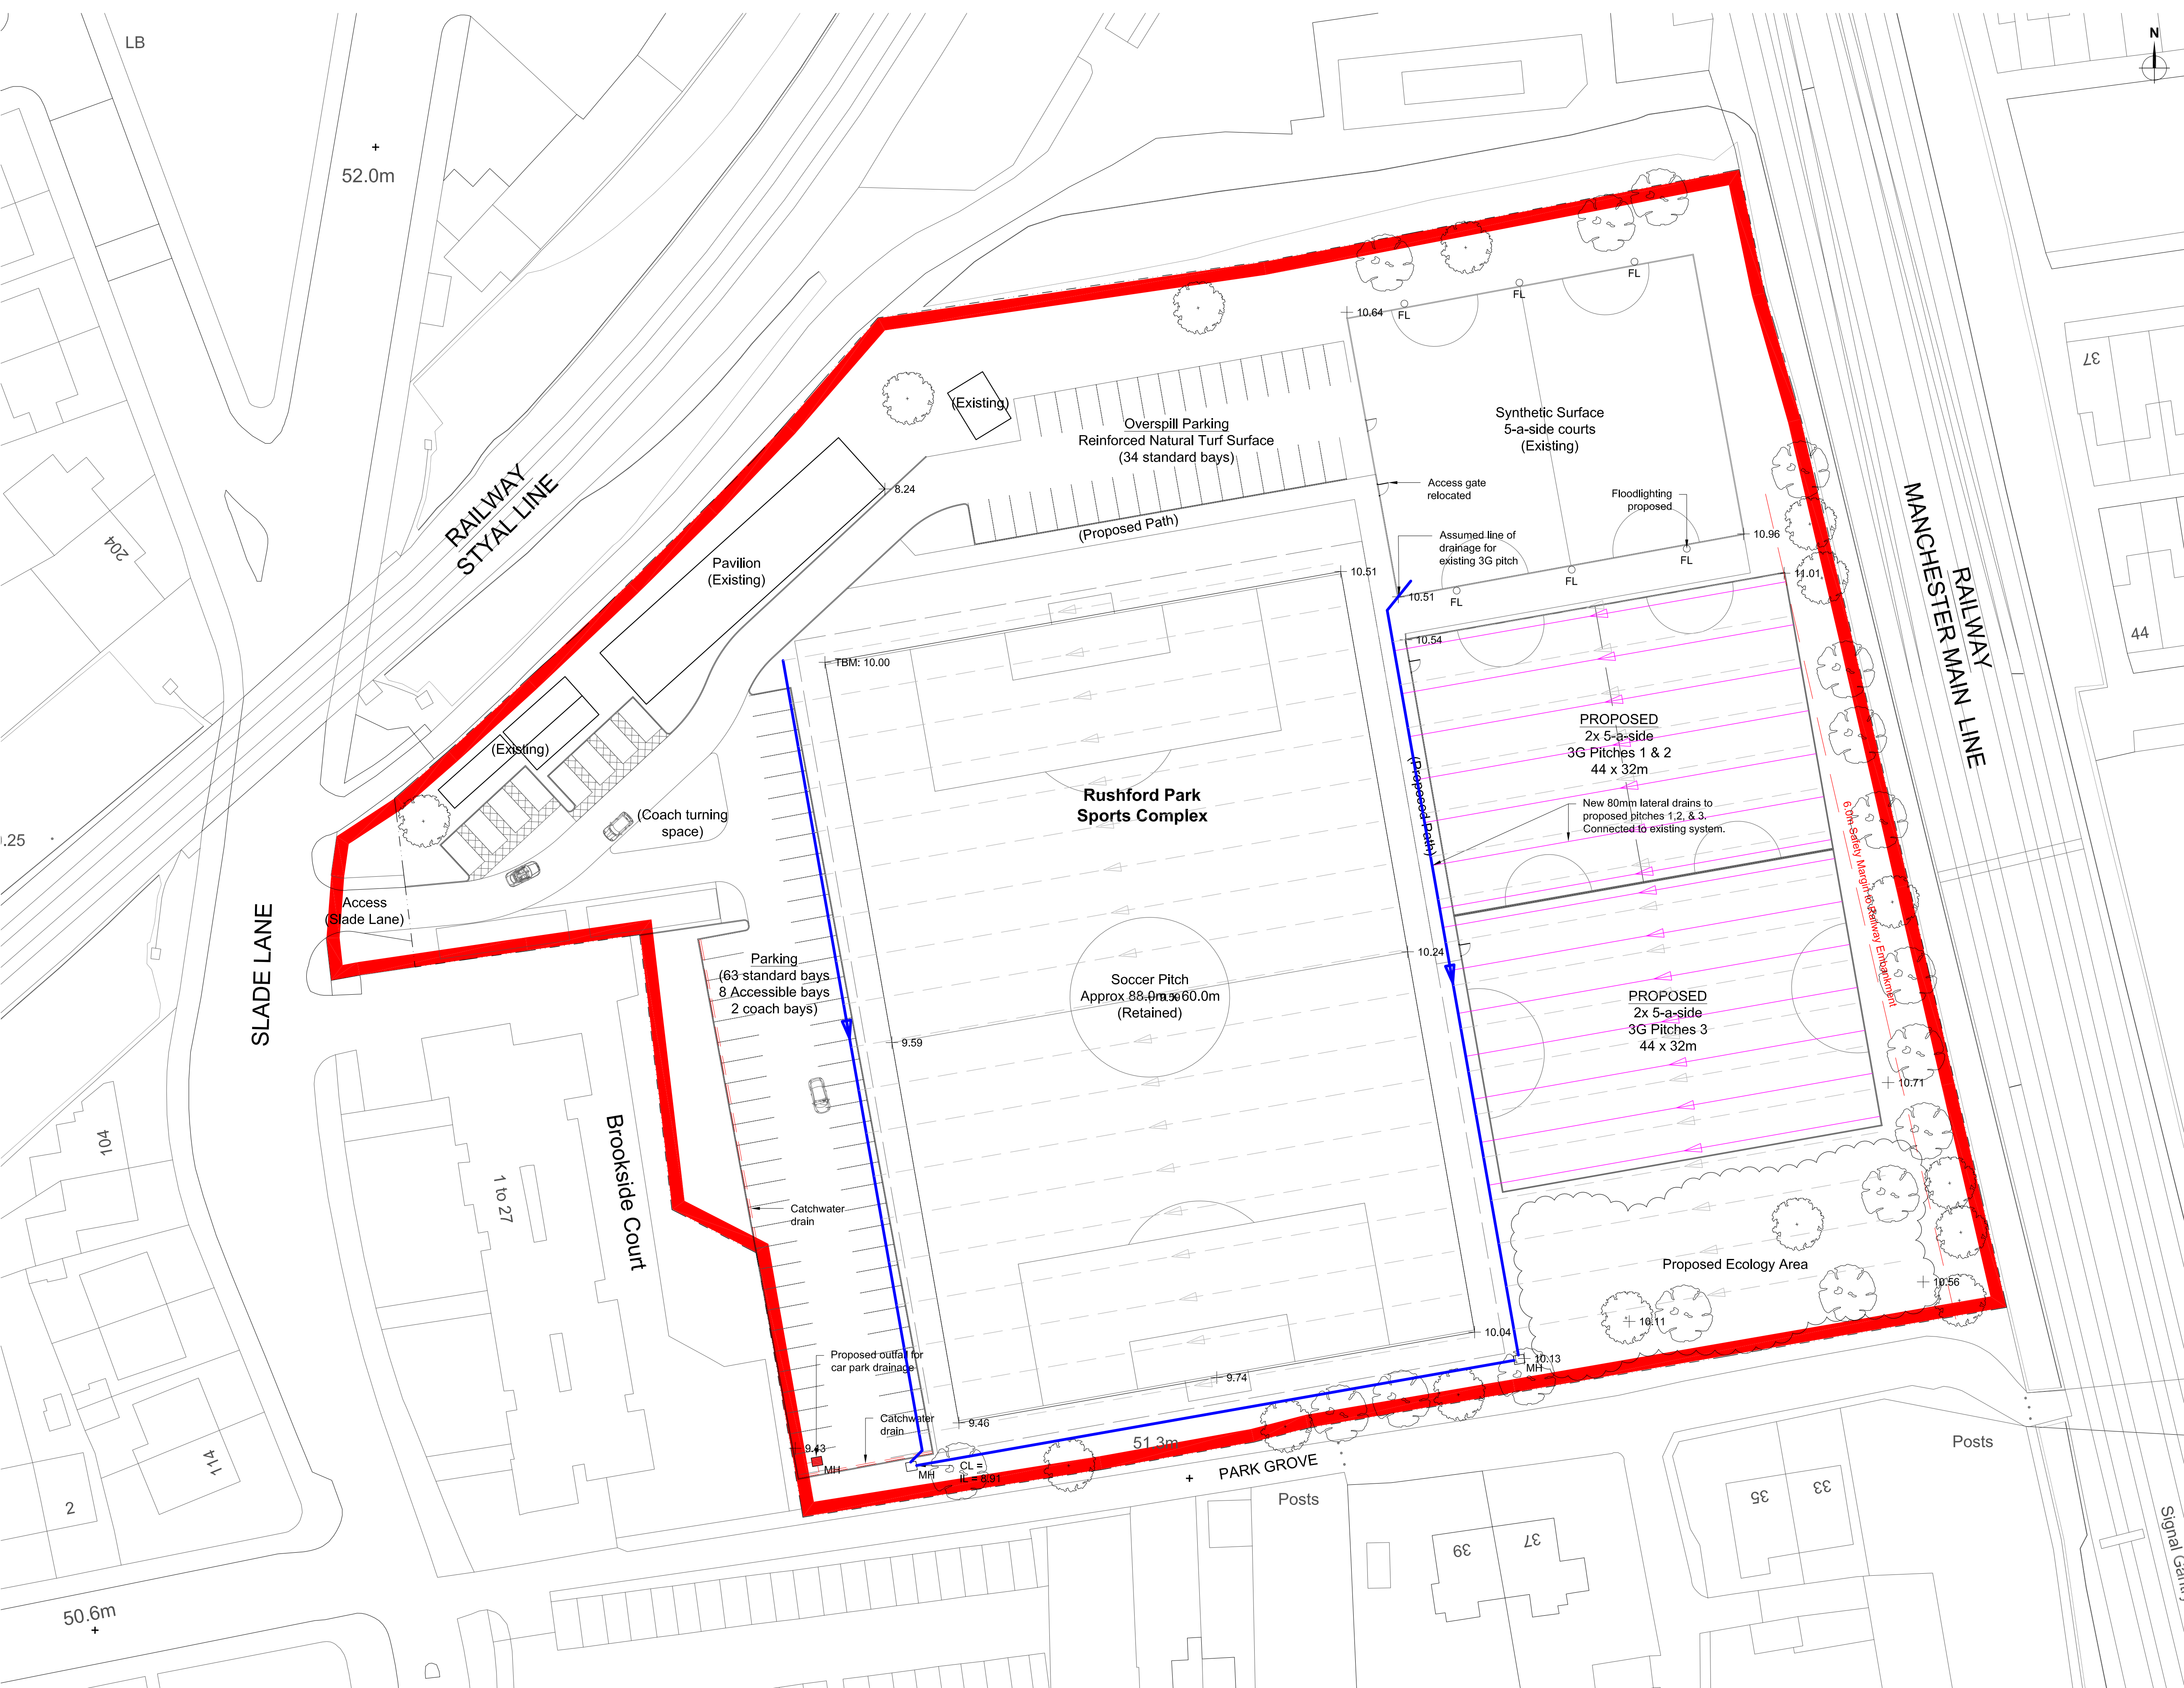

© 2020 This drawing is the property of Hemstock Design Ltd., copyright reserved. This drawing is issued on the condition that it is not duplicated, reproduced or disclosed to unauthorised persons without prior written consent of the copyright holder. Hemstock Design Ltd. will not be held liable for improper use, or use other than directed, of this drawing or the information contained within.

Registered Head Office: Hemstock Design Ltd., 10A Dig Street, Ashbourne, Derbyshire, DE6 1GF, UK.

Do Not Scale. Refer to original sheet size and scale as indicated below.

Preliminary Status
Issued for information to accompany planning application.

Rev: P-0
Date: 06/06/20
By: CH

LEGEND: DRAINAGE

80mm Drain

110mm Drain

160mm Drain

SC Silt Chamber

MH Manhole (Existing)

MH Manhole (Proposed)

Catchwater Drain

Outfall

Client:
BPG Sportsgrounds Ltd (on behalf of)
Manchester Youth Academy Ltd

Project:
Planning Application
Rushford Park: New 3G Synthetic Turf Pitches
Grid Ref: SJ 86986 94720 (E 386986;N 394720)

Title:
Drainage Plan
Proposed Drainage to New 3G Pitches &
Car Park

Drawn by:
ODH

Scale:
1:350

Date:
JUNE 2020

Drawing Number:
2005-ZZ-LI-DR-A-52101

Checked by:
DKH

Original size:
A1

Revision:
P-0

Hemstock Design

**DRAINAGE PLAN: PROPOSED DRAINAGE TO
NEW 3G PITCHES & CAR PARK**
Scale - 1:350 @ A1