


SITE LOCATION



 
Reproduced by permission of Ordnance Survey on behalf of the Controller of Her Majesty's Stationery Office
All rights reserved. © Crown Copyright licence no. 100022432

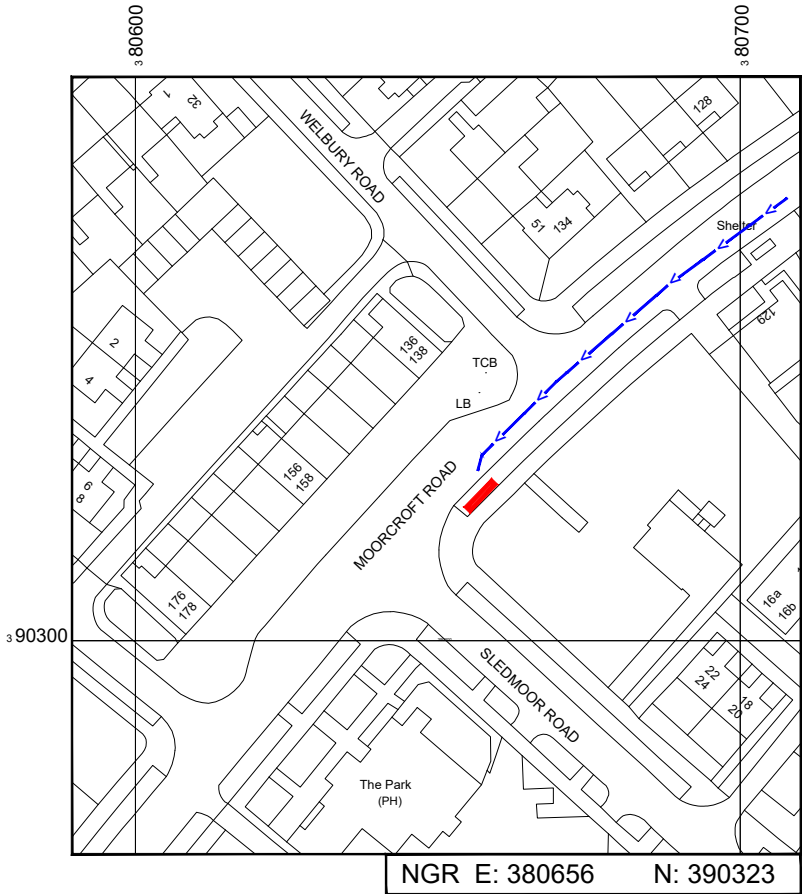

Reproduced by permission of Ordnance Survey on behalf of the
Controller of Her Majesty's Stationery Office
All rights reserved. © Crown Copyright licence no. 100022432


NGR E: 380656 N: 390323

SITE AREA PLAN



SITE PHOTOGRAPH

 SITE LOCATION PLAN



GOOGLE MAPS QR CODE

GOOGLE MAPS -<https://goo.gl/maps/jPg6ubZBaDTvKL2Q8>

GOOGLE STREETVIEW -<https://goo.gl/maps/tdm8qGQUvTaVrTGQA>

NOTES:

1. ALL DIMENSIONS IN MM UNLESS OTHERWISE NOTED.

DIRECTIONS TO SITE:

Head north-west on M60, At junction 6, take the A6144 exit to Sale, At the roundabout, take the 1st exit onto Old Hall Rd/A6144, Turn left onto Wythenshawe Rd/B5397, Turn left onto Northenden Rd/B5166, Continue to follow B5166, Turn right onto Button Lane, Turn right onto Moorcroft Road, the site is located on the left hand side on the Grass verge

Site Provider's
Property Boundary:



Access Route To Site:



Access Route:



Master:	MBNL / EE / H3G:	Project:	Purpose of Issue:	Issue:
M001	MBNL	H3G 5G UNILATERAL	Planning	A
Date:	30/06/2020	Revision / Upgrade Description:		
Drawn:	PS	First Issue - Site nomination dated: 15/04/2020		
Checked:	DH			
Approved:	SD			



Hutchison 3G UK Limited
Star House, 20 Grenfell Road
Maidenhead, SL6 1EH
Tel: 01628 765 000
Fax: 01628 765 001

H3G Base Station Information line:
0845 6043000
Available 8am-8pm Monday to Friday

Design Consultant & Principal Contractor:



WHP Telecoms
Unit 1 Maple Park,
Low Fields Avenue, Leeds
LS12 6HH

Tel: 01133023550
e-mail: info@whptelecoms.com

Site Name: MOORCROFT ROAD SW

Site ID: TFD14537

Address: MOORCROFT ROAD,
NORTHERN MOOR,
MANCHESTER,
GREATER MANCHESTER,
M23 0WJ



Title: 002 SITE LOCATION PLAN

Project: H3G 5G UNILATERAL

Purpose of Issue: PLANNING

EE Cell ID:	MBNL Cell ID:	3UK Cell ID:
N/A	N/A	N/A

Master Drawing No:	Issue:
TFD14537_M001	A

 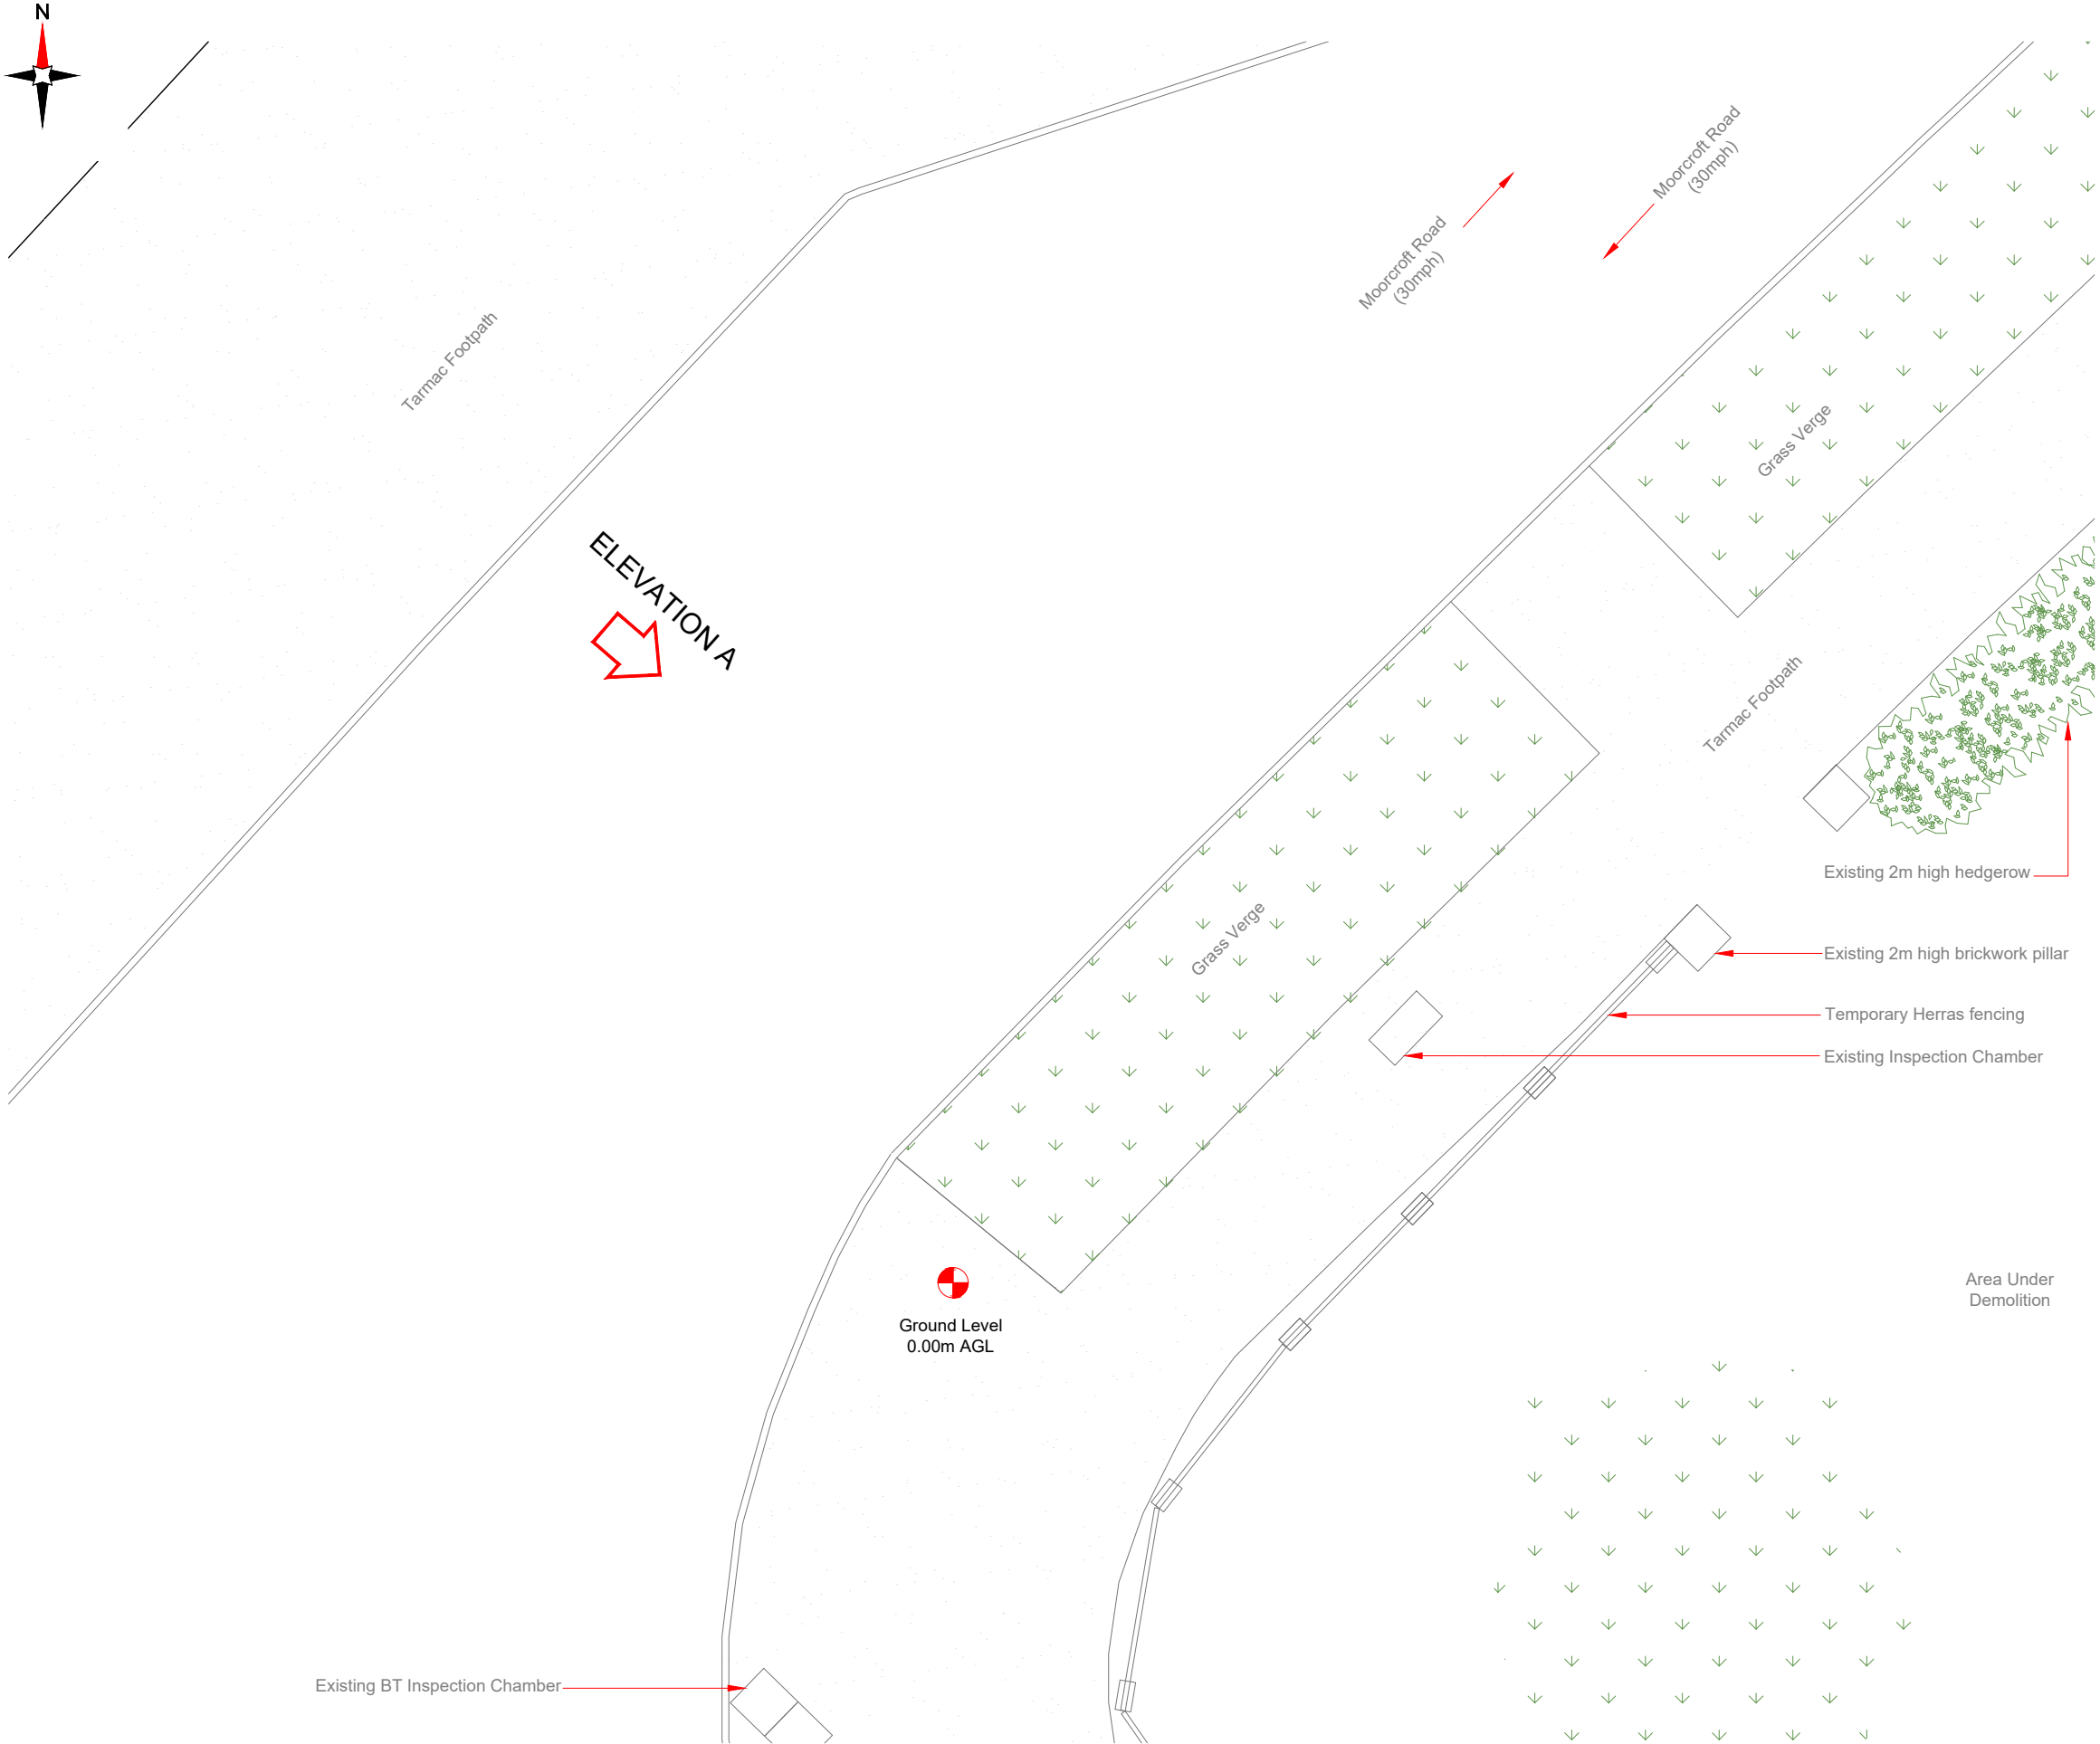

NOTES:

1. ALL DIMENSIONS IN MM UNLESS OTHERWISE NOTED.

Master:	MBNL / EE / H3G:	Project:	Purpose of Issue:	Issue:
M001	MBNL	H3G 5G UNILATERAL	Planning	A
Date:	30/06/2020	Revision / Upgrade Description:		
Drawn:	PS	First Issue - Site nomination dated: 15/04/2020		
Checked:	DH			
Approved:	SD			

Hutchison 3G UK Limited
Star House, 20 Grenfell Road
Maidenhead, SL6 1EH
Tel: 01628 765 000
Fax: 01628 765 001

H3G Base Station Information line:
0845 6043000
Available 8am-8pm Monday to Friday

Design Consultant & Principal Contractor:

WHP Telecoms
Unit 1 Maple Park,
Low Fields Avenue, Leeds
LS12 6HH
Tel: 01133023550
e-mail: info@whptelecoms.com

Site Name:
MOORCROFT ROAD SW

Site ID:
TFD14537

Address:
MOORCROFT ROAD,
NORTHERN MOOR,
MANCHESTER,
GREATER MANCHESTER,
M23 0WJ

Title:
100 EXISTING SITE PLAN

Project:
H3G 5G UNILATERAL

Purpose of Issue:
PLANNING

EE Cell ID:	MBNL Cell ID:	3UK Cell ID:
N/A	N/A	N/A


Master Drawing No:
TFD14537_M001

Issue:
A

100mm

50mm

10mm

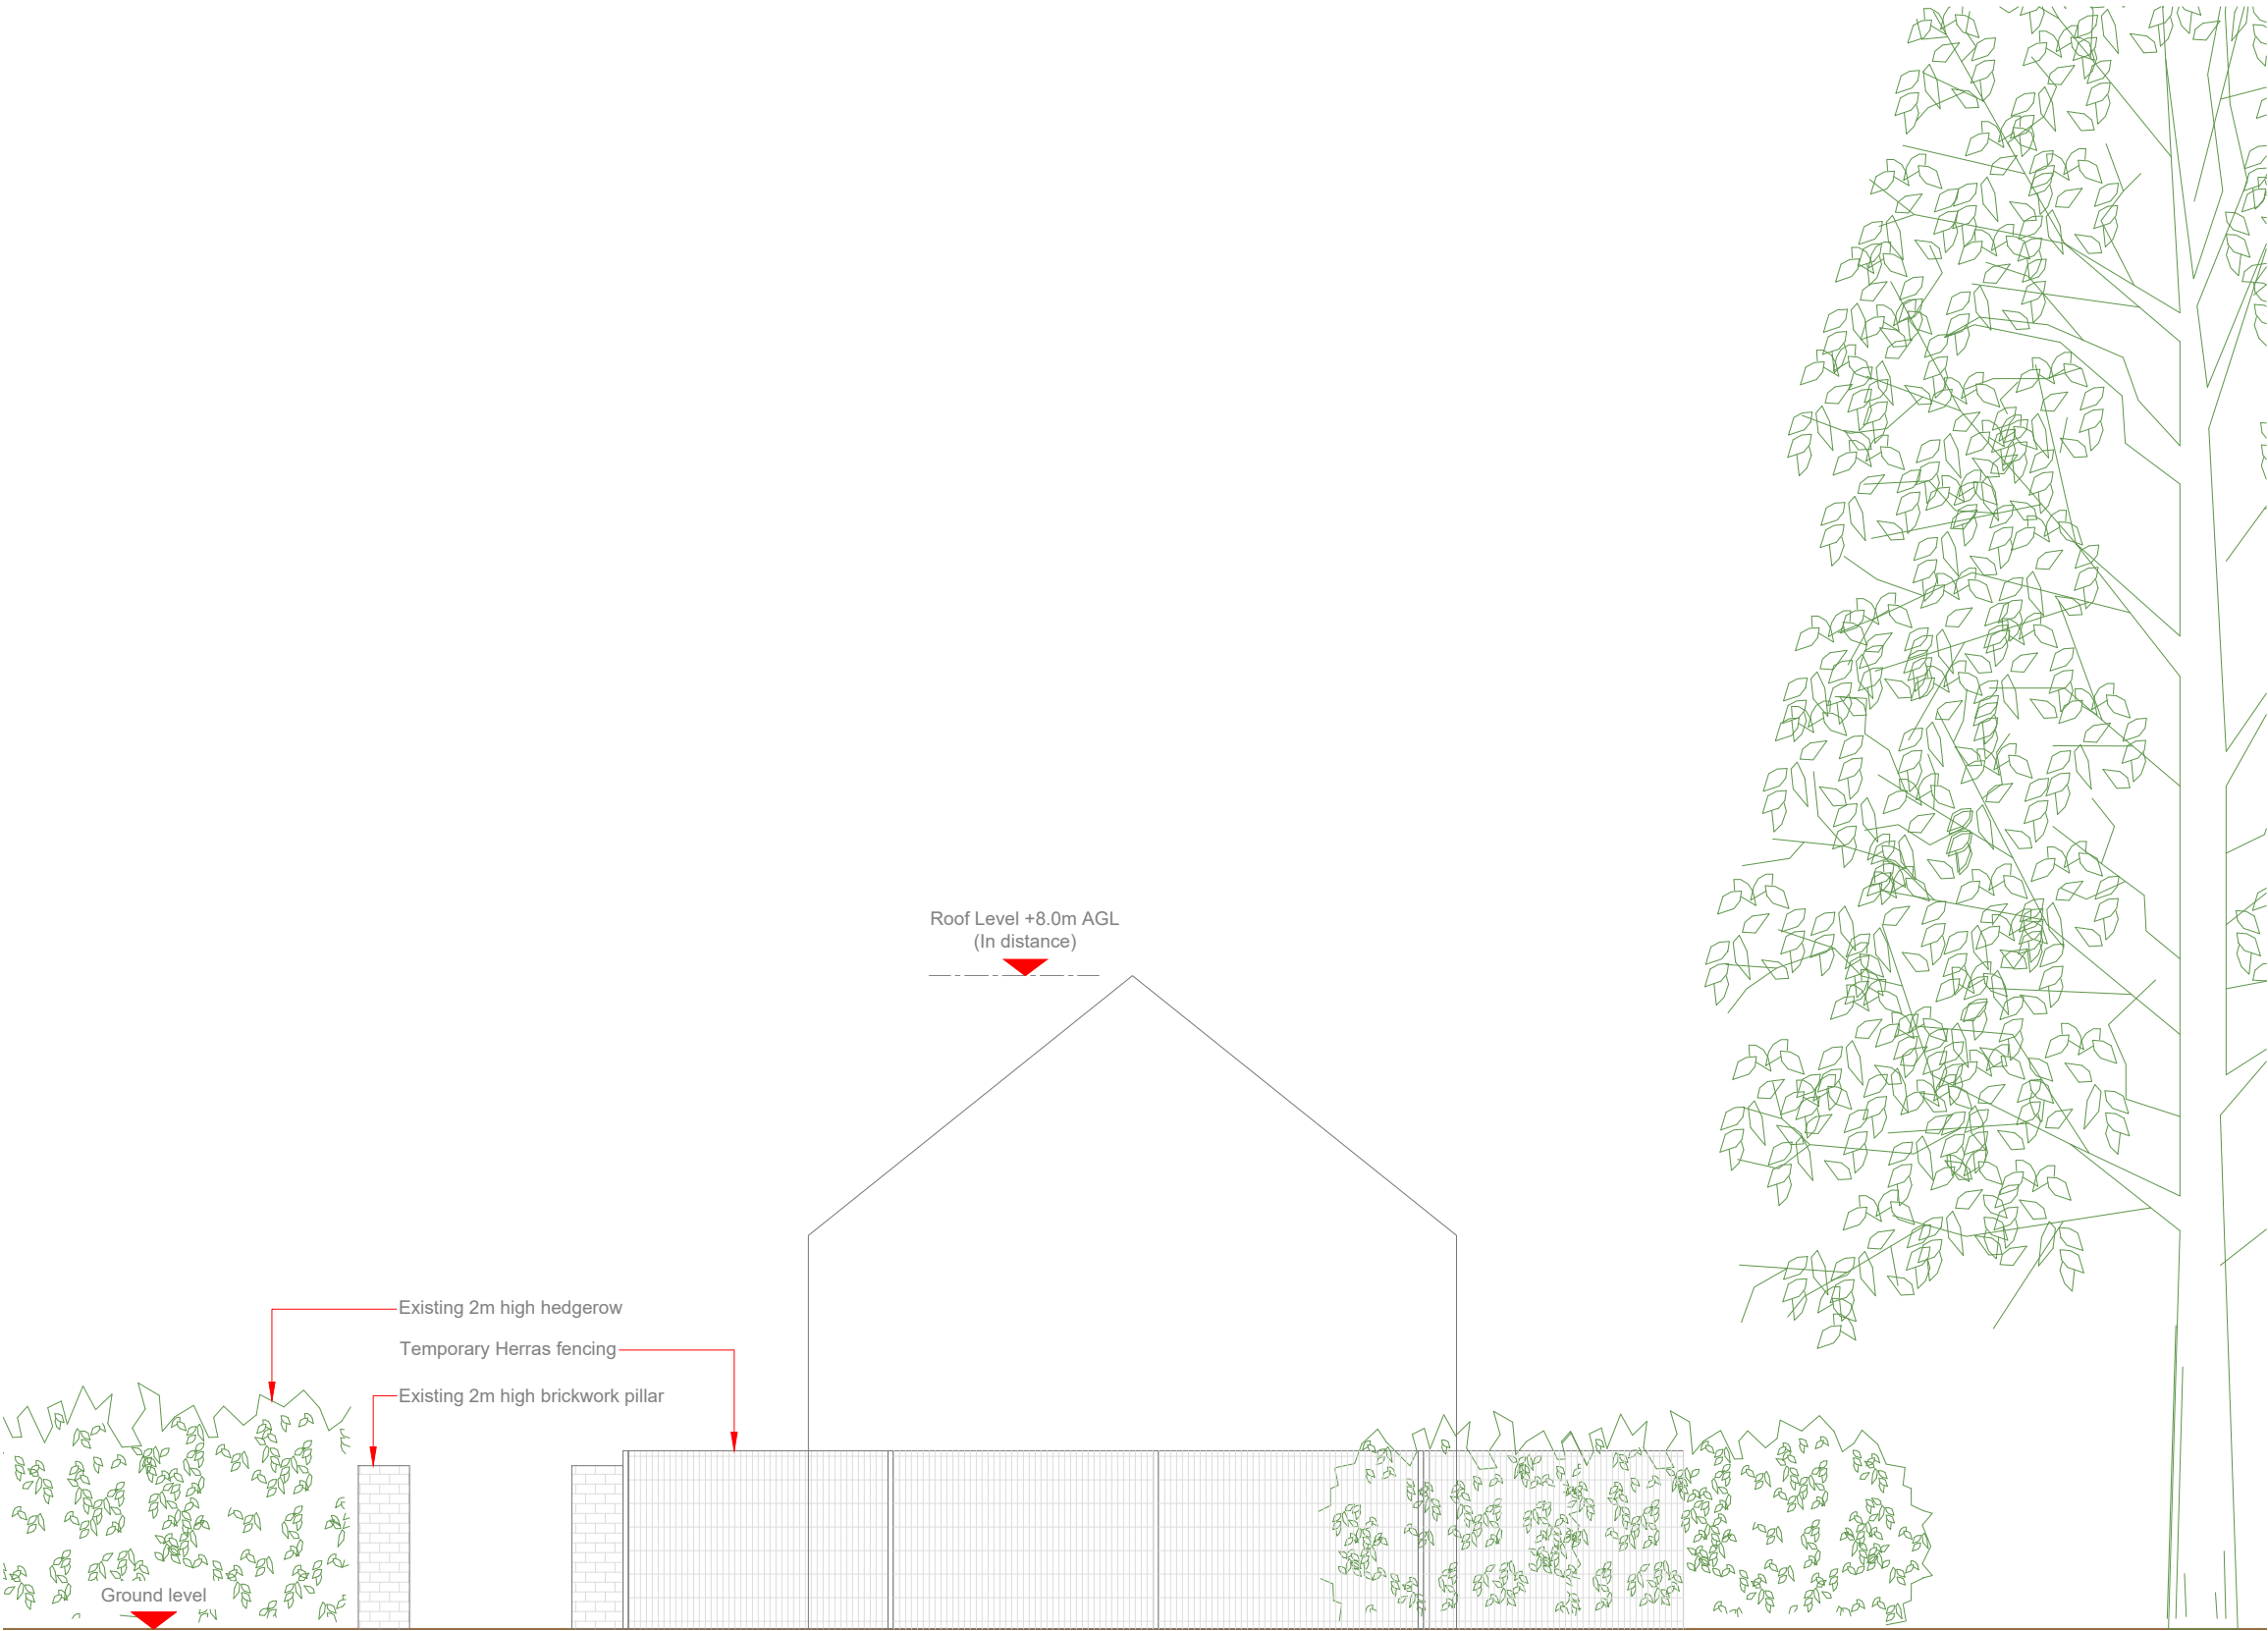

Roof Level +8.0m AGL
(In distance)

 
Existing 2m high hedgerow

Temporary Herras fencing

Existing 2m high brickwork pillar

Ground level

EXISTING ELEVATION A



NOTES:

1. ALL DIMENSIONS IN MM UNLESS OTHERWISE NOTED.

Master:	MBNL / EE / H3G:	Project:	Purpose of Issue:	Issue:
M001	MBNL	H3G 5G UNILATERAL	Planning	A
Date:	30/06/2020	Revision / Upgrade Description:		
Drawn:	PS	First Issue - Site nomination dated: 15/04/2020		
Checked:	DH			
Approved:	SD			



Hutchison 3G UK Limited
Star House, 20 Grenfell Road
Maidenhead, SL6 1EH
Tel: 01628 765 000
Fax: 01628 765 001

H3G Base Station Information line:
0845 6043000
Available 8am-8pm Monday to Friday

Design Consultant & Principal Contractor:



WHP Telecoms
Unit 1 Maple Park,
Low Fields Avenue, Leeds
LS12 6HH

Tel: 01133023550
e-mail: info@whptelecoms.com

Site Name:
MOORCROFT ROAD SW

Site ID:
TFD14537

Address:
MOORCROFT ROAD,
NORTHERN MOOR,
MANCHESTER,
GREATER MANCHESTER,
M23 0WJ

Title:
150 EXISTING ELEVATION A

Project:
H3G 5G UNILATERAL

Purpose of Issue:
PLANNING

EE Cell ID:	MBNL Cell ID:	3UK Cell ID:
N/A	N/A	N/A

Master Drawing No:	Issue:
TFD14537_M001	A



Tarmac Footpath

ELEVATION A

Moorcroft Road
(30mph)

Moorcroft Road
(30mph)

Grass Verge

Tarmac Footpath

Existing 2m high hedgerow

Existing 2m high brickwork pillar

Temporary Herras fencing

Existing Inspection Chamber

Area Under
Demolition

 
Proposed Phase 8 monopole
c/w wraparound cabinet at base

Proposed 1No. Commscope G100876
Cabinet (power & transmission)
Proposed 1No. Commscope
Bowler cabinet
Proposed 1No. Huawei
APM5930 cabinet

Ground Level
0.00m AGL

Existing BT Inspection Chamber

PROPOSED H3G CONFIGURATION SITE PLAN



Antenna Aperture ID	Proposed 4G/5G Bearing	Operator: Shared/ EE/H3G
A1	65°	H3G
A2	65°	H3G
B1	185°	H3G
B2	185°	H3G
C1	305°	H3G
C2	305°	H3G

NOTES:
1. ALL DIMENSIONS IN MM UNLESS OTHERWISE NOTED.

Master:	MBNL / EE / H3G:	Project:	Purpose of Issue:	Issue:
M001	MBNL	H3G 5G UNILATERAL	Planning	A
Date:	30/06/2020	Revision / Upgrade Description:		
Drawn:	PS	First Issue - Site nomination dated:15/04/2020		
Checked:	DH			
Approved:	SD			



Hutchison 3G UK Limited
Star House, 20 Grenfell Road
Maidenhead, SL6 1EH
Tel: 01628 765 000
Fax: 01628 765 001

H3G Base Station Information line:
0845 6043000
Available 8am-8pm Monday to Friday

Design Consultant & Principal Contractor:



WHP Telecoms
Unit 1 Maple Park,
Low Fields Avenue, Leeds
LS12 6HH


Tel: 01133023550
e-mail: info@whptelecoms.com

Site Name:			MOORCROFT ROAD SW		
Site ID:			TFD14537		
Address:			MOORCROFT ROAD, NORTHERN MOOR, MANCHESTER, GREATER MANCHESTER, M23 0WJ		
Title:			210 PROPOSED H3G SITE PLAN		
Project:			H3G 5G UNILATERAL		
Purpose of Issue:			PLANNING		
EE Cell ID:	MBNL Cell ID:	3UK Cell ID:			
N/A	N/A	N/A			
Master Drawing No:			TFD14537_M001		Issue:
					A

100mm

50mm

10mm

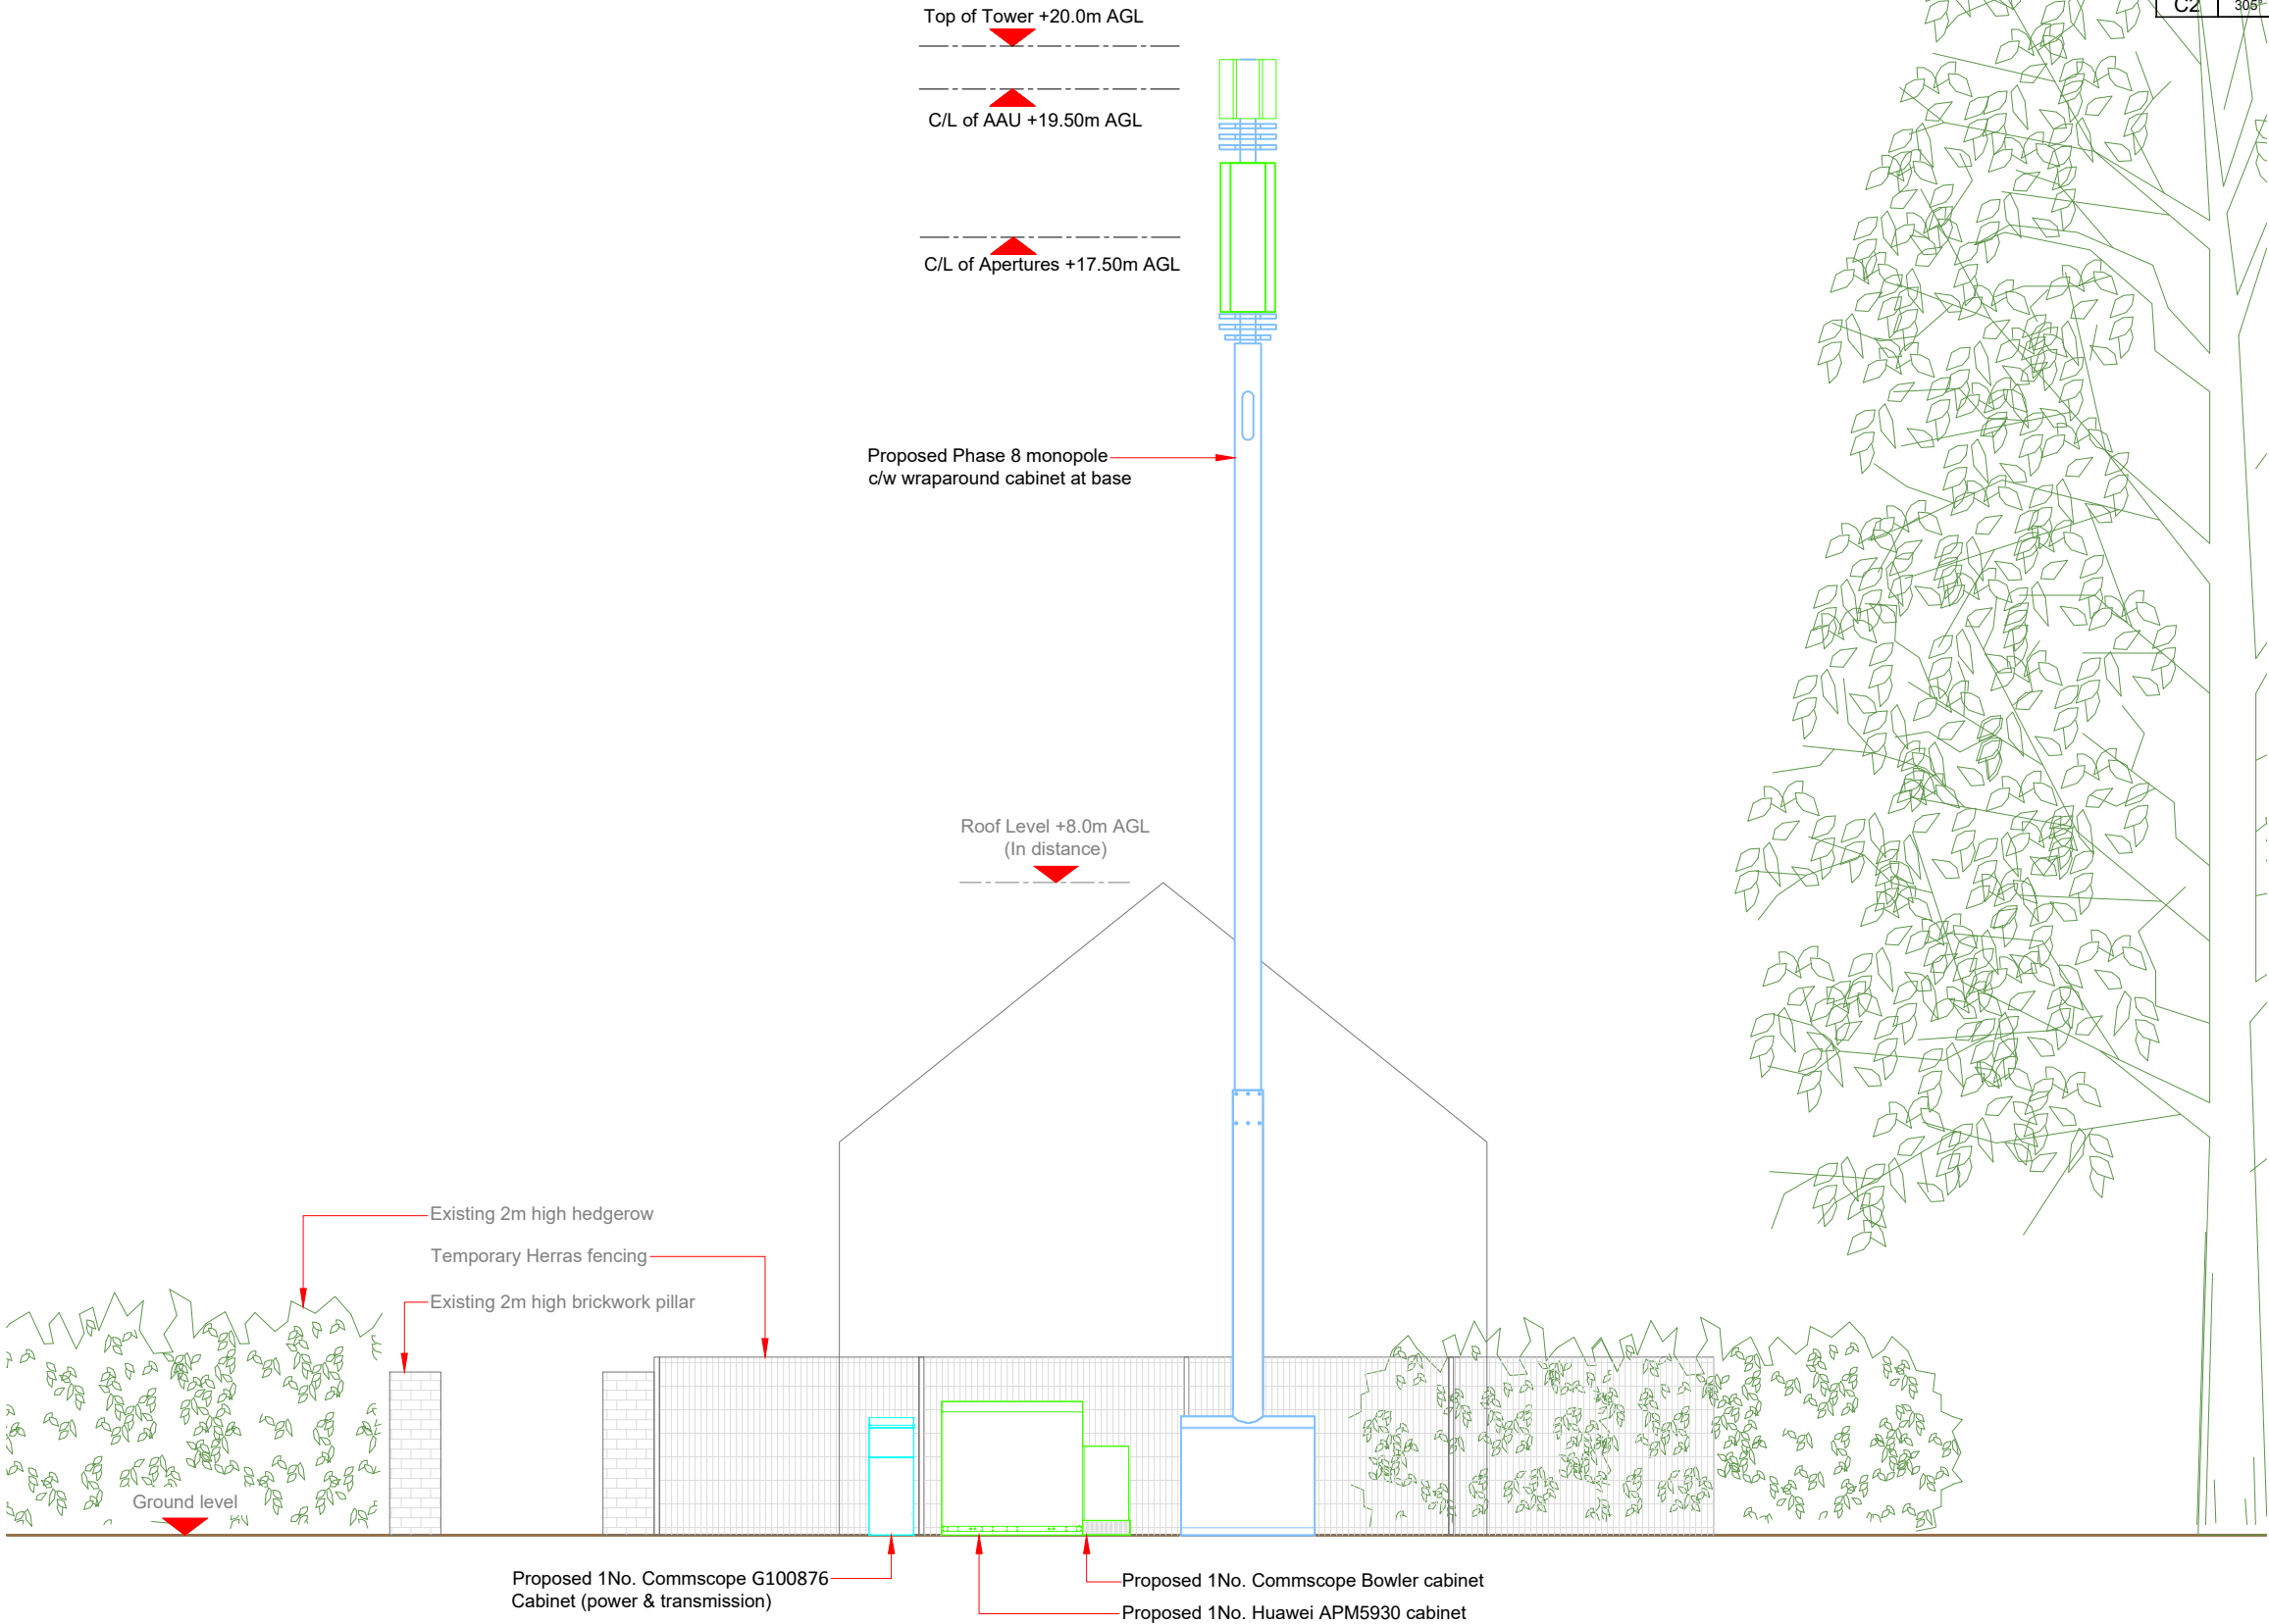

Antenna Aperture ID	Proposed 4G/5G Bearing	Operator: Shared/ EE/H3G
A1	65°	H3G
A2	65°	H3G
B1	165°	H3G
B2	185°	H3G
C1	305°	H3G
C2	305°	H3G

NOTES:
1. ALL DIMENSIONS IN MM UNLESS OTHERWISE NOTED.

Master:	MBNL / EE / H3G:	Project:	Purpose of Issue:	Issue:
M001	MBNL	H3G 5G UNILATERAL	Planning	A
Date:	30/06/2020	Revision / Upgrade Description:		
Drawn:	PS	First Issue - Site nomination dated:15/04/2020		
Checked:	DH			
Approved:	SD			



Hutchison 3G UK Limited
Star House, 20 Grenfell Road
Maidenhead, SL6 1EH
Tel: 01628 765 000
Fax: 01628 765 001

H3G Base Station Information line:
0845 6043000
Available 8am-8pm Monday to Friday

Design Consultant & Principal Contractor:



WHP Telecoms
Unit 1 Maple Park,
Low Fields Avenue, Leeds
LS12 6HH
Tel: 01133023550
e-mail: info@whptelecoms.com

Site Name: **MOORCROFT ROAD SW**

Site ID: **TFD14537**

Address: **MOORCROFT ROAD,
NORTHERN MOOR,
MANCHESTER,
GREATER MANCHESTER,
M23 0WJ**

Title: **260 PROPOSED H3G ELEVATION**


Project: **H3G 5G UNILATERAL**

Purpose of Issue: **PLANNING**

EE Cell ID:	MBNL Cell ID:	3UK Cell ID:
N/A	N/A	N/A

Master Drawing No:	Issue:
TFD14537_M001	A

Proposed H3G Antenna Aperture Schedule & RF Equipment Capacity																	
Antenna Aperture ID	Antenna Aperture Size (Length x Width x Depth)	Aperture Height C/L	Aperture Max Weight (kg)	Proposed 4G/5G Bearing	Tech: 4G/5G	Operator: Shared/ EE/H3G	Antenna Aperture Coordinates		RRU No. Max Size & Weight L=320mm W=400mm D=150mm Weight=25kg	MHA No. Max Size & Weight L=300mm W=300mm D=150mm Weight=10kg	Main Feeder			BOB Max Size & Weight (300x300x250mm & 5kg)		Active Router No. Max Size & Weight (370x260x150mm & 10kg)	Passive Router No. Max Size & Weight (350x220x150mm & 10kg)
							Eastings	Northings			Size	Length	No.	No. Top	No. Bottom		
A1	795x395x220mm	19.50m	45kg	65°	5G	H3G	-	-	0	0	TBC	TBC	4	1	1	1	1
A2	2009x469x206mm	17.50m	TBC	65°	3G/4G	H3G	-	-	3	0	TBC	TBC	4	1	1	1	1
B1	795x395x220mm	19.50m	45kg	185°	5G	H3G	-	-	0	0	TBC	TBC	4	1	1	1	1
B2	2009x469x206mm	17.50m	TBC	185°	3G/4G	H3G	-	-	3	0	TBC	TBC	4	1	1	1	1
C1	795x395x220mm	19.50m	45kg	305°	5G	H3G	-	-	0	0	TBC	TBC	4	1	1	1	1
C2	2009x469x206mm	17.50m	TBC	305°	3G/4G	H3G	-	-	3	0	TBC	TBC	4	1	1	1	1

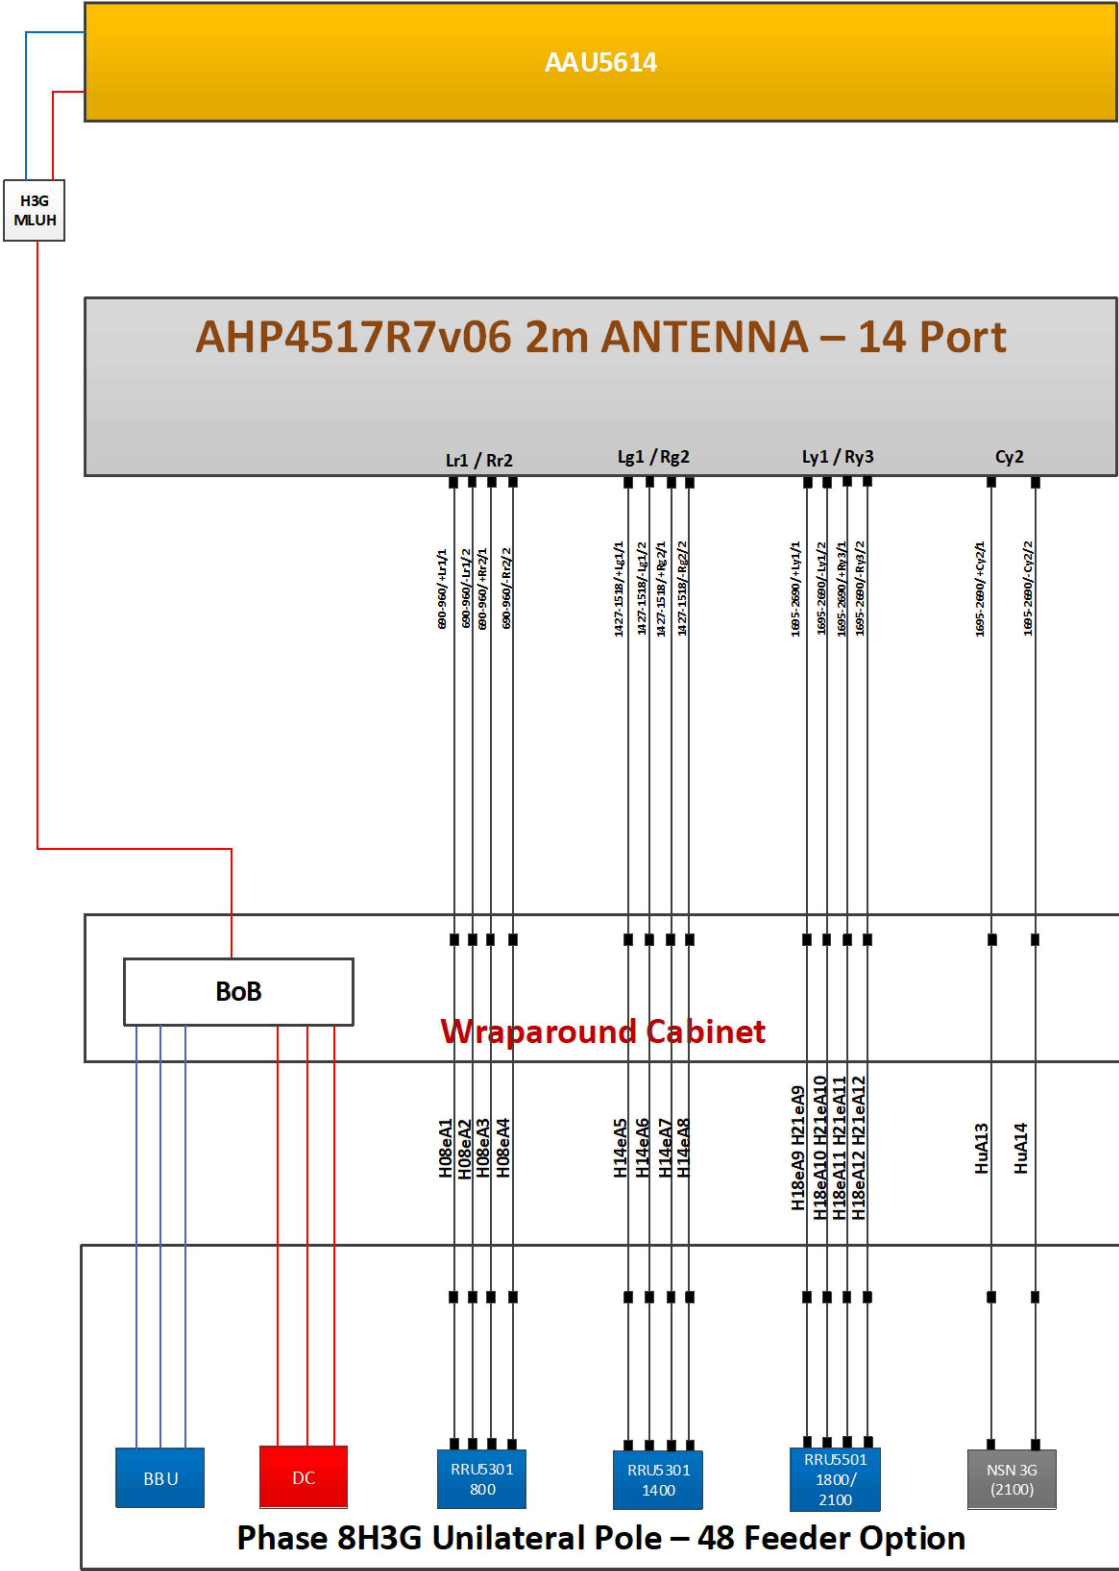

STATUS KEY:

Installed: Existing
Retain: Existing and to remain
Relocate: Existing and to be relocated
Remove: Existing to be removed from site
Proposed: New on site

Master:	MBNL / EE / H3G:	Project:	Purpose of Issue:	Issue:
M001	MBNL	H3G 5G UNILATERAL	Planning	A
Date:	30/06/2020	Revision / Upgrade Description:		
Drawn:	PS	First Issue - Site nomination dated:15/04/2020		
Checked:	DH			
Approved:	SD			



Hutchison 3G UK Limited
Star House, 20 Grenfell Road
Maidenhead, SL6 1EH
Tel: 01628 765 000
Fax: 01628 765 001

H3G Base Station Information line:
0845 6043000
Available 8am-8pm Monday to Friday

Design Consultant & Principal Contractor:



WHP Telecoms
Unit 1 Maple Park,
Low Fields Avenue, Leeds
LS12 6HH

Tel: 01133023550
e-mail: info@whptelecoms.com

Site Name: MOORCROFT ROAD SW

Site ID: TFD14537

Address: MOORCROFT ROAD,
NORTHERN MOOR,
MANCHESTER,
GREATER MANCHESTER,
M23 0WJ

Title: 302 PROPOSED H3G ANTENNA
SCHEDULE & LINE CONFIGURATION

Project: H3G 5G UNILATERAL

Purpose of Issue: PLANNING

EE Cell ID:	MBNL Cell ID:	3UK Cell ID:
N/A	N/A	N/A

Master Drawing No:	Issue:
TFD14537_M001	A

Support Structure Schedule													
Structure ID	Status	Equipment Description / Type	Structure Manufacturer	Height AGL (m)	Colour (RAL Colour)	Headframe Details	Foundation / Support Grillage / Host Structure Details	Support Bolt Details	MBNL Ref:	Comments			
ST1	Proposed	Phase 8	-	20.0m	Galvanised	-	Root Foundation	-	-				
Equipment Schedule													
Equipment ID	Quantity	Status	Equipment Description / Type	Equipment Manufacturer	Dimensions (W x D x H)	Weight (kg)	Colour (RAL Colour)	Material	Location	Power	Power cable length (m)	MBNL Ref:	Comments
CAB1	1	Proposed	Commscope - Bowler	-	1900x600x1750	-	Grey	Steel	Outdoor	-	-	-	
CAB2	1	Proposed	H3g - APM5930	-	640x480x1200	-	Grey	Steel	Outdoor	-	-	-	
CAB3	1	Proposed	Diplexer Cabinet	-	1800x750x1600	-	Grey	Steel	Outdoor	-	-	-	
CAB4	1	Proposed	Commscope Kevin Cabinet	-	600x520x1585	-	Grey	Steel	Outdoor	-	-	-	

STATUS KEY:

Installed:

Existing

Retain:

Existing and to remain

Relocate:

Existing and to be relocated

Remove:

Existing to be removed from site

Proposed:

New on site

LOCATION KEY:

Outdoor:

Located outside

Indoor:

Located within an equipment cabin or equipment room

Internal:

located inside a cabinet or item of equipment

Master:	MBNL / EE / H3G:	Project:	Purpose of Issue:	Issue:
M001	MBNL	H3G 5G UNILATERAL	Planning	A
Date:	30/06/2020	Revision / Upgrade Description:		
Drawn:	PS	First Issue - Site nomination dated: 15/04/2020		
Checked:	DH			
Approved:	SD			



Hutchison 3G UK Limited

Star House, 20 Grenfell Road

Maidenhead, SL6 1EH

Tel: 01628 765 000

Fax: 01628 765 001

H3G Base Station Information line:

0845 6043000

Available 8am-8pm Monday to Friday

Design Consultant & Principal Contractor:



WHP Telecoms

Unit 1 Maple Park,

Low Fields Avenue, Leeds

LS12 6HH

Tel: 01133023550

e-mail: info@whptelecoms.com

Site Name:

MOORCROFT ROAD SW

Site ID:

TFD14537

Address:

MOORCROFT ROAD,

NORTHERN MOOR,

MANCHESTER,

GREATER MANCHESTER,

M23 0WJ

Title:

305 EQUIPMENT SCHEDULE & SUPPORT STRUCTURE DETAILS

Project:

H3G 5G UNILATERAL

Purpose of Issue:

PLANNING

EE Cell ID:

MBNL Cell ID:

3UK Cell ID:

N/A

N/A

N/A

Master Drawing No:

TFD14537_M001

Issue:

A

100mm

50mm

10mm



10