



Notes

JDA Design Associates Ltd is not responsible for any alterations or modifications to this drawing made by anyone other than the Architect or by the client. The client is responsible for ensuring that the drawing is used in accordance with the terms of the contract. The client is responsible for ensuring that the drawing is used in accordance with the terms of the contract. The client is responsible for ensuring that the drawing is used in accordance with the terms of the contract.

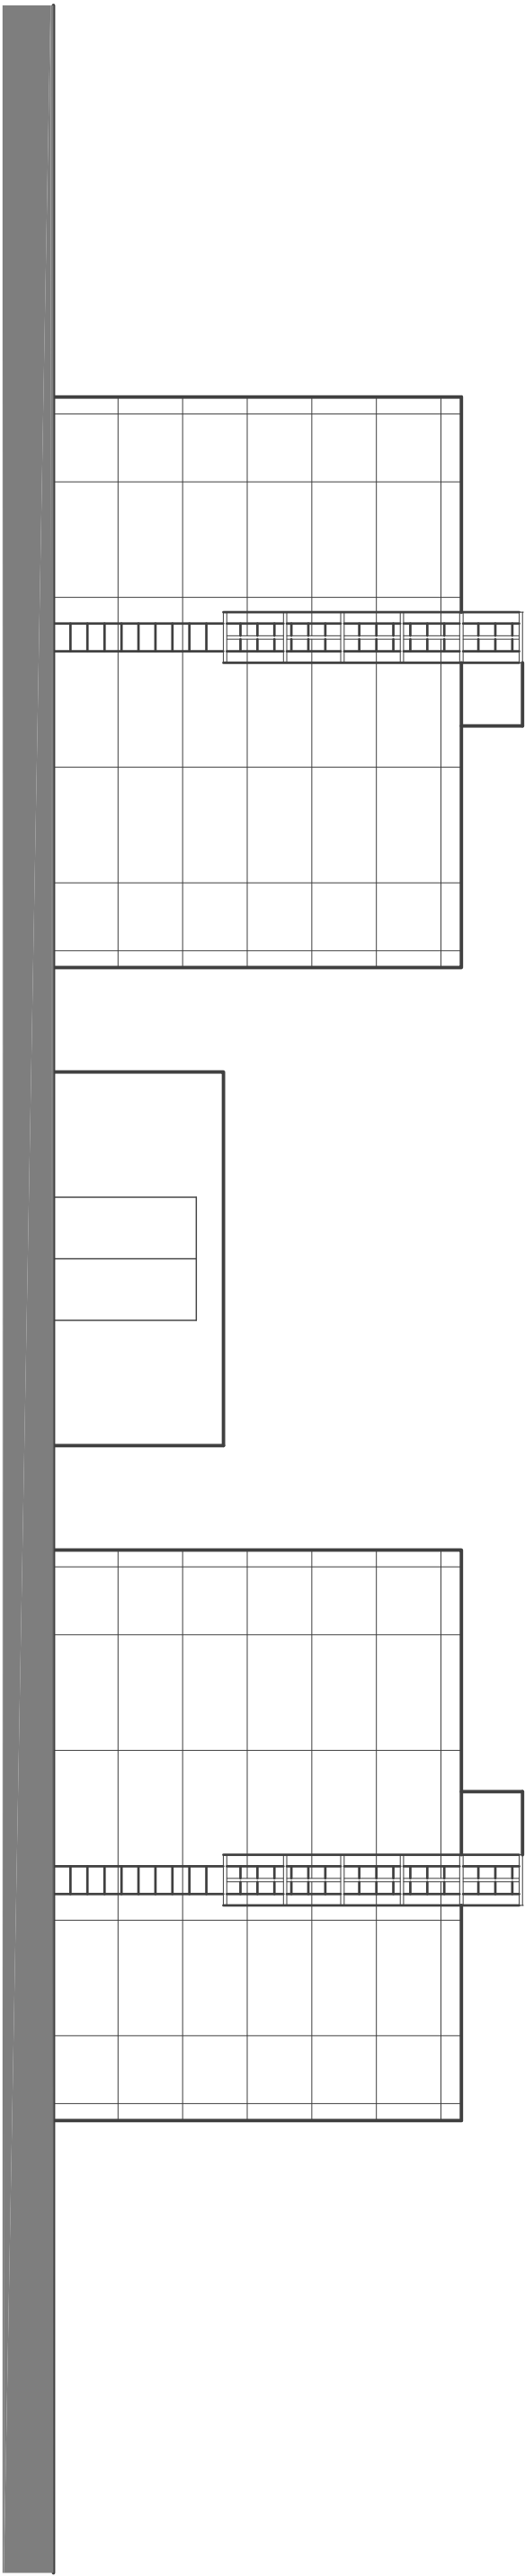

South Elevation 1:100
Fire Suppression Pump House and reservoir tanks

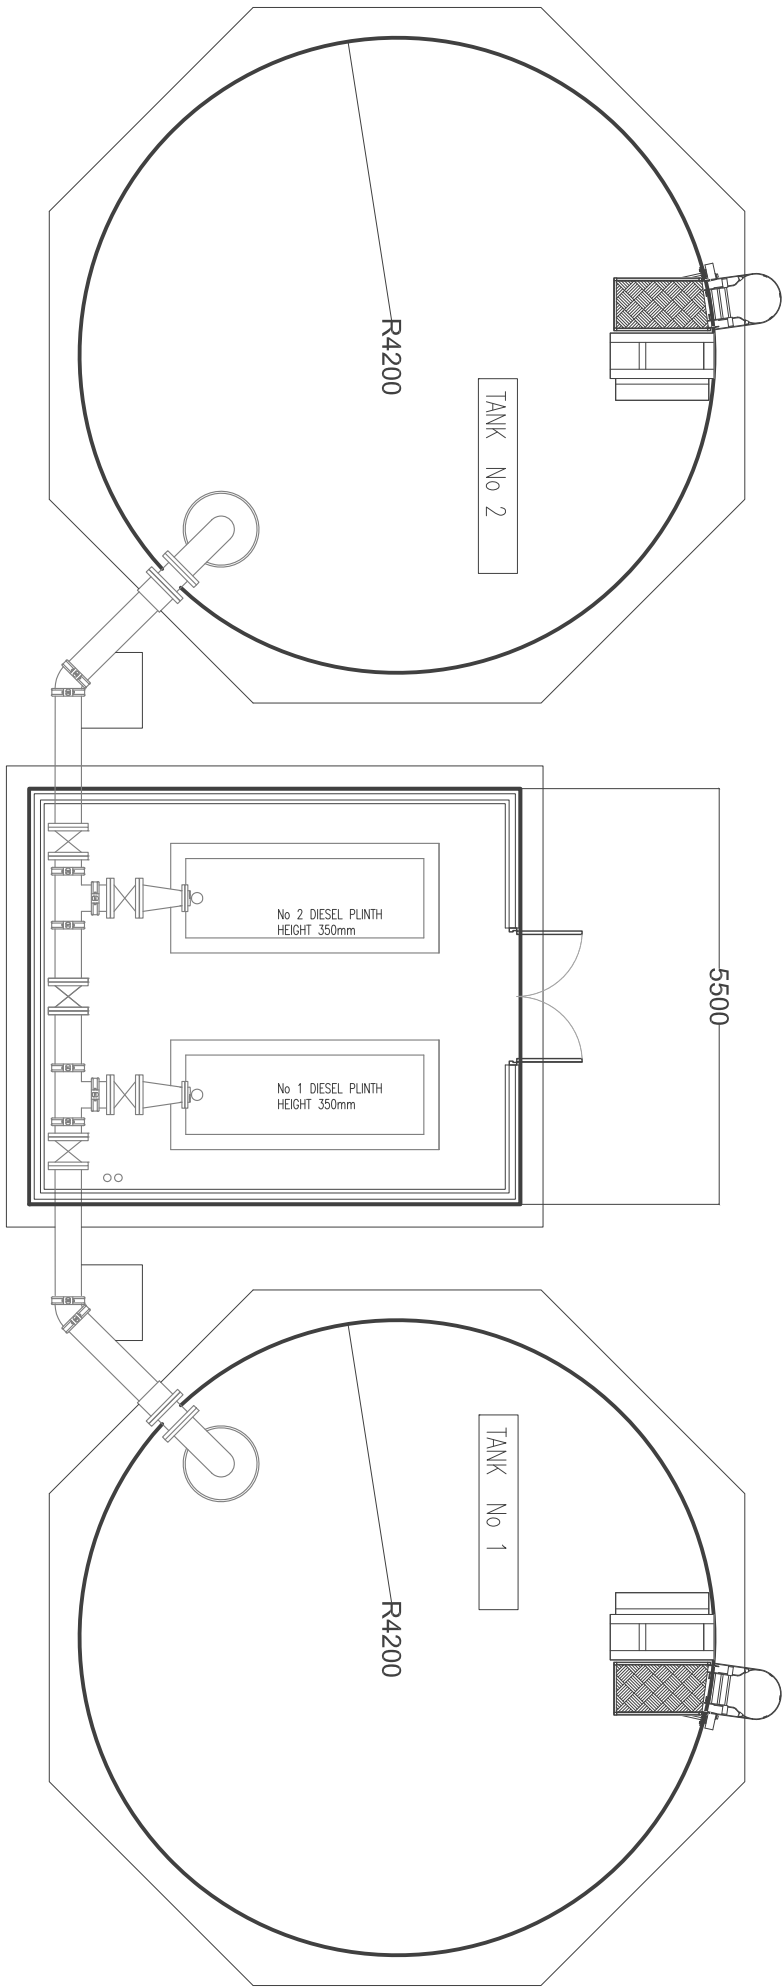


Waterside House building line

Fire Suppression Pump House and reservoir tanks Plan 1:100



Typical sprinkler water supply with two tanks.

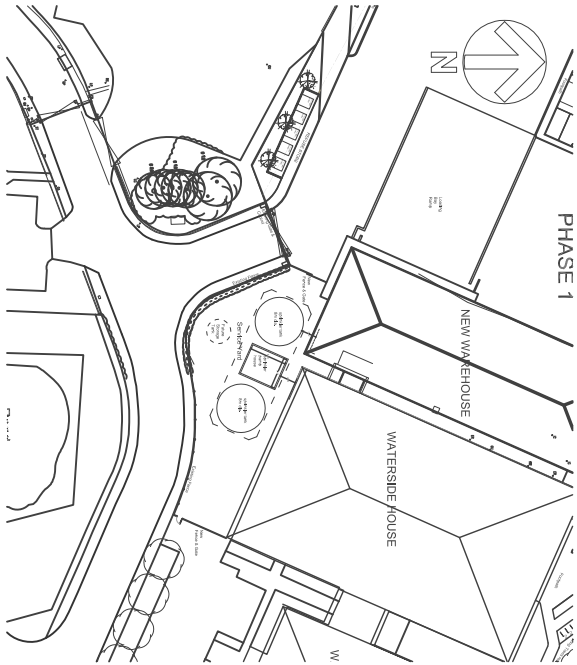

Fire Suppression Pump House
and reservoir tanks
Location Plan 1:1250

Rev	Description	Date	By
-	-	-	-

j d a architects
info@jda-architects.com
www.jda-architects.com
manchester 0161 336 5011
liverpool 0151 665 0112



Client:	Hologic
Project:	Proposed car park & associated works to Waterside House, Crewe Road, Wythenshaw
Project Status:	P - Preliminary
Scale:	@ original size
1:100	A2
Drawn by:	CM
Checked By:	BJ
Date:	09.06.2020

Project Number:	1108	Drawing Number:	A	DR	0106
Description:	Proposed Fire Suppression Pump house and reservoir tanks				



Scale: 1:100