


LEGEND:

- Ø125 SUPPLY DUCT
- Ø125 EXTRACT DUCT
- AC UNIT
- SMOKE DAMPER
- PLENUM BOX
- 300x300 SQUARE LOUVERED FACE DIFFUSER
- 125Ø EXTRACT VALVE
- MVHR UNIT AS VECTAIRE STUDIO
- SINGLE AIRBRICK

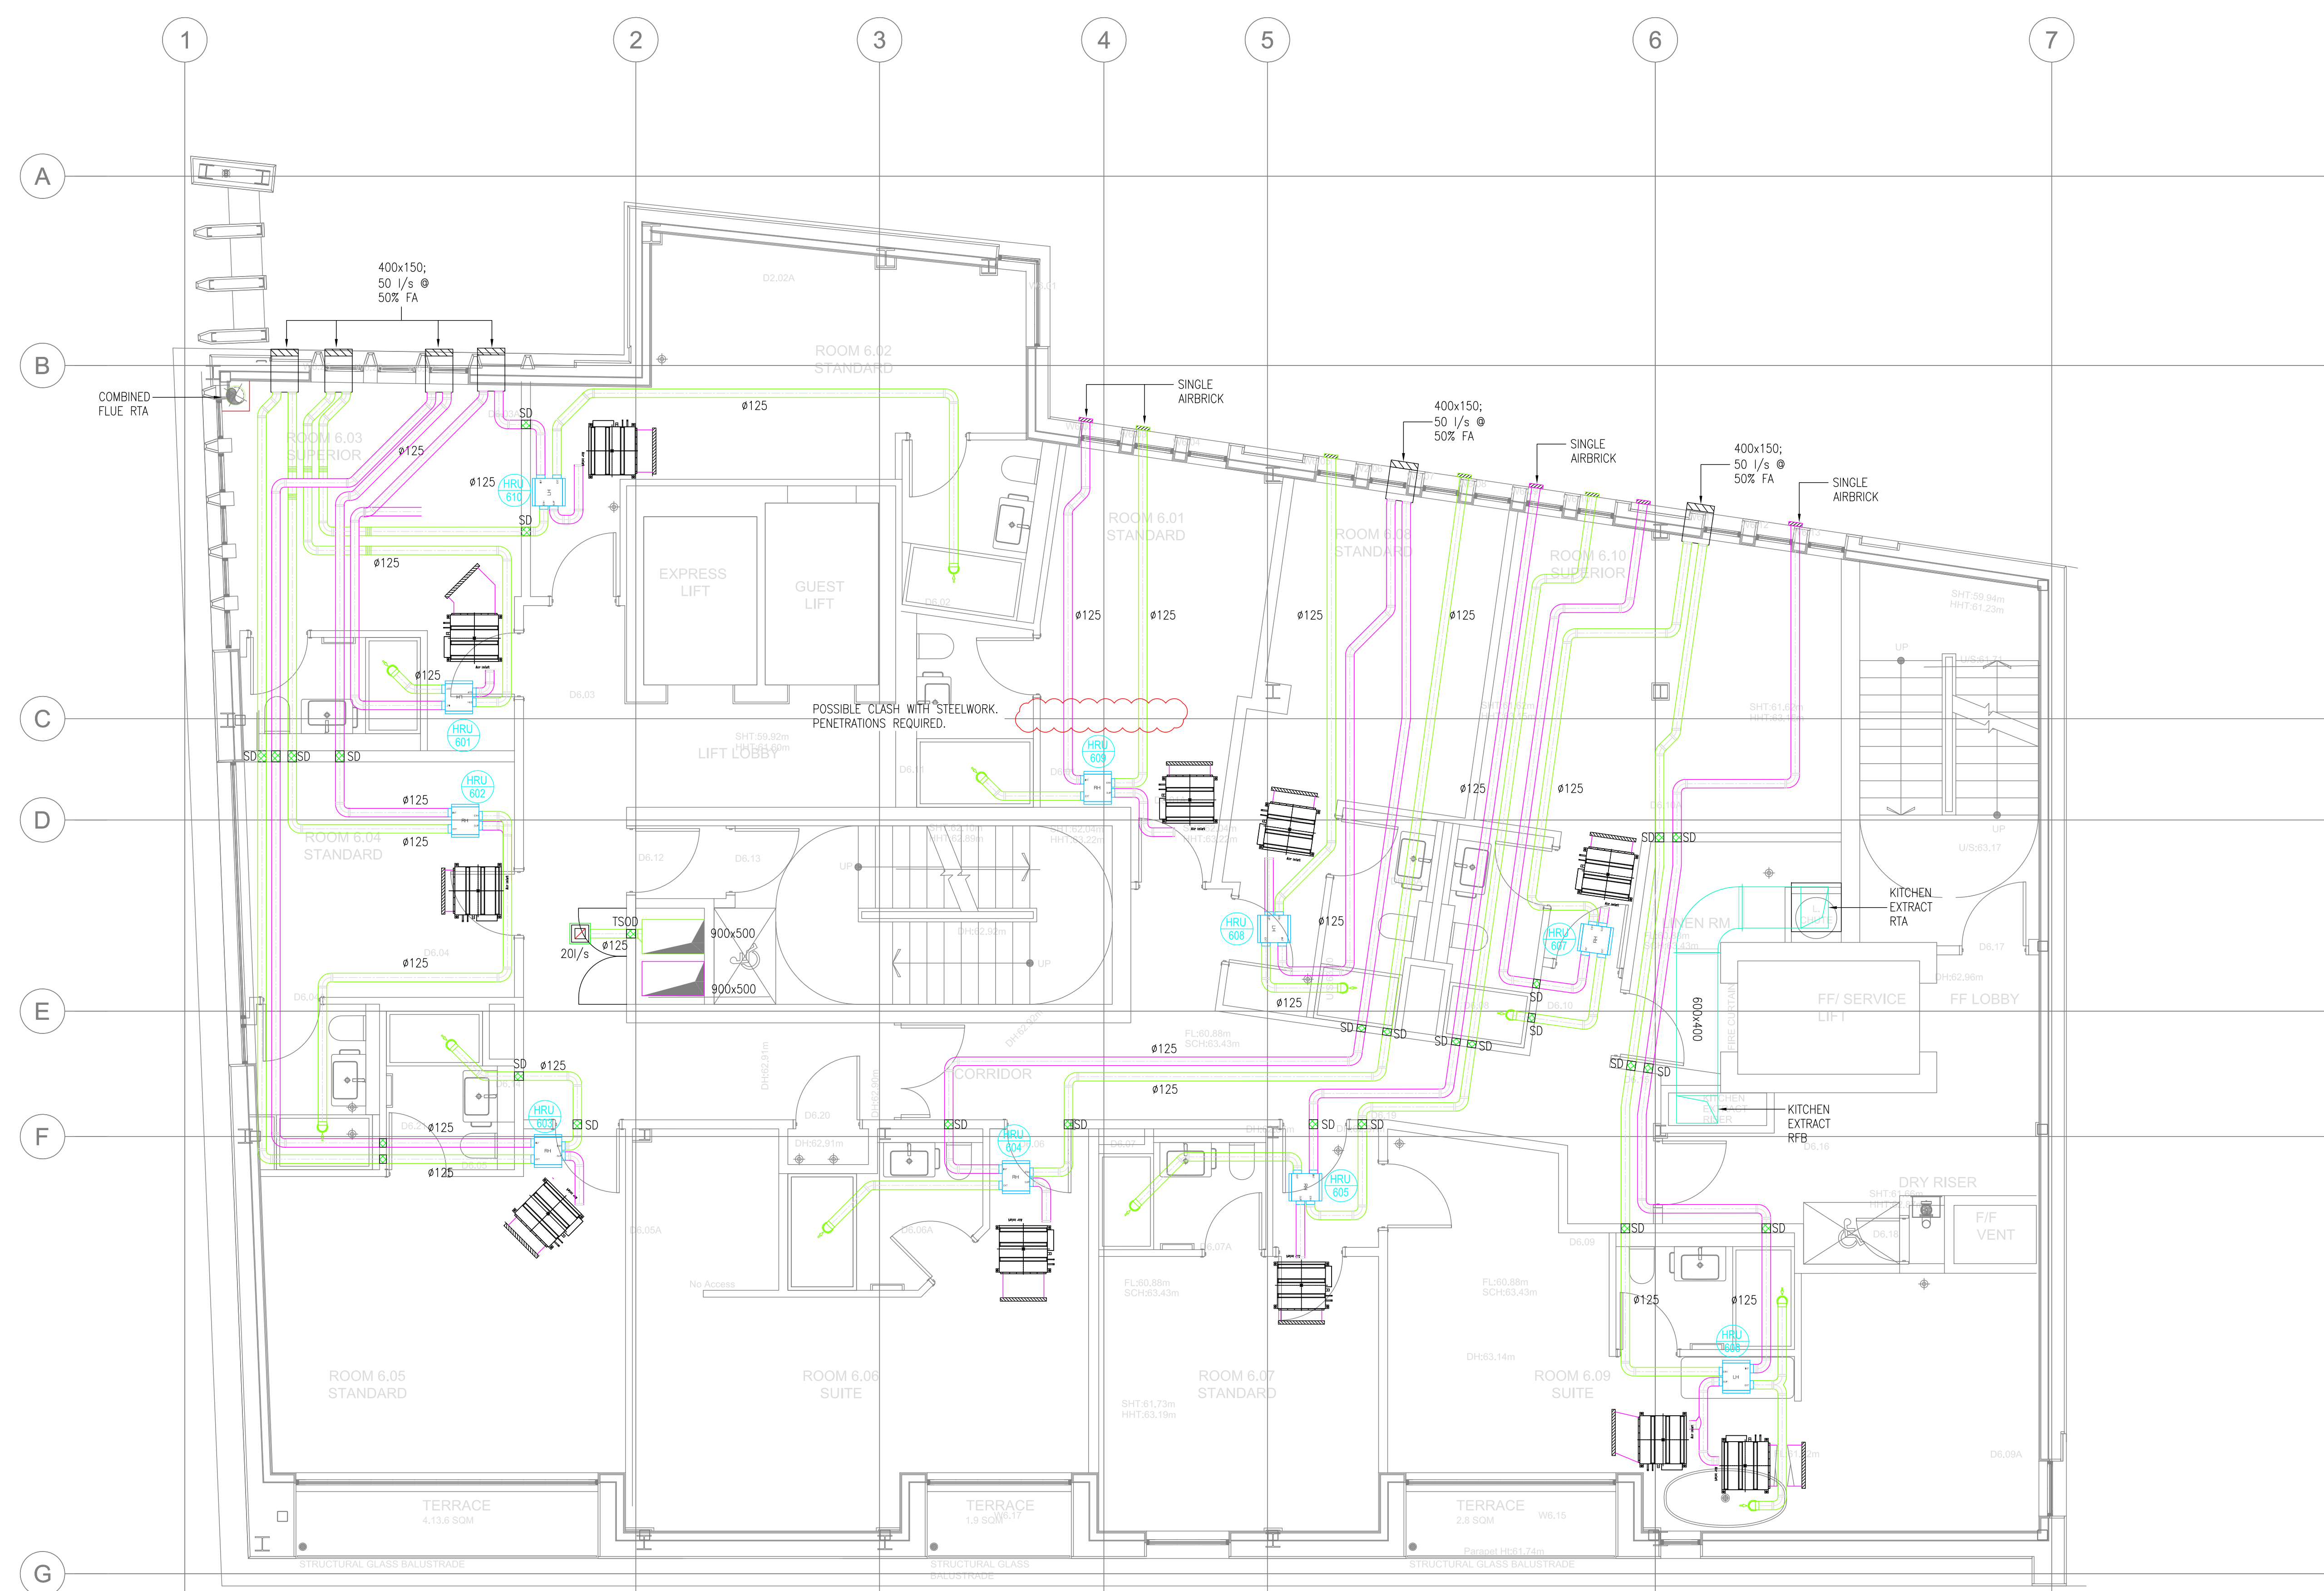

DESIGNED MC 21.01.20 DRAWN MC 21.01.20 APPROVED
REV T1 TENDER ISSUE

STATUS TENDER



MARTIN DESIGN

4 FOX OAK PARK, COMMON ROAD, DUNNINGTON, YORK, YO19 5RZ
01904 488486 info@martindesignassociates.com

CLIENT WHITAKER HORTON LIMITED

PROJECT MALMAISON MANCHESTER

TITLE MECHANICAL SERVICES VENTILATION LAYOUT SIXTH FLOOR

SCALE: 1:50 @ A1 DATE: JAN 2020
DRAWN: CG ENGINEER: CSM
CHECKED: APPROVED: