


SITE LOCATION

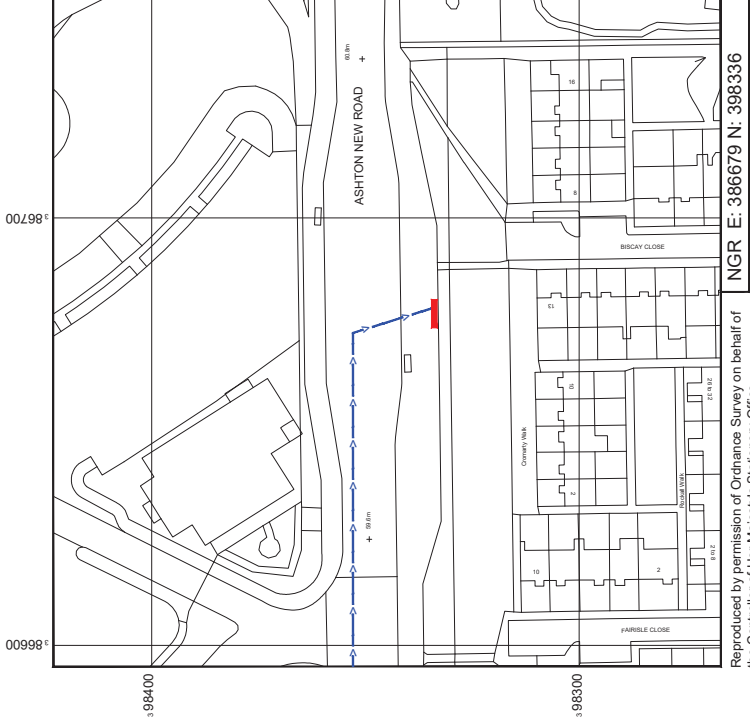

SITE PHOTOGRAPH



Reproduced by permission of Ordnance Survey on behalf of
the Controller of Her Majesty's Stationary Office
All rights reserved. © Crown Copyright licence no. 100022432



GOOGLE MAPS QR CODE

GOOGLE MAPS - <https://goo.gl/maps/FHdmsiGp36azThLV7>

GOOGLE STREETVIEW - <https://goo.gl/maps/vvm1k519K78XvGap7>

NOTES:

1. ALL DIMENSIONS IN MM UNLESS OTHERWISE NOTED.

DIRECTIONS TO SITE:
Head east on A57(M). Continue onto Ring Rd. Turn right onto Every St. Turn
right onto Ashton New Road. Follow Ashton New Road and site location is on
the right hand side.



Number	MBNL / EE / H3G	H3G 5G UNILATERAL	Planning	Issue
M001	MBNL	H3G 5G UNILATERAL	Planning	A
Date	28/03/2020	Revision / Log and Description	First Issue - Site nomination dated: TBC	
Drawn	CDJN			
Approved	CDJN			




Hutchison 3G UK Limited
Star House, 20 Greenfield Road
Maddenhead, SL6 1EH
Tel: 01628 765 000
Fax: 01628 765 001
H3G Base Station Information line:
0845 6043000
Available 8am-5pm Monday to Friday

Design Consultant & Principal Contractor:



WHP Telecoms
Unit 1 Maple Park,
Low Fields Avenue, Leeds
LS12 6HH
Tel: 01133023550
e-mail: info@whplecoms.com

Site Name:	ASHTON NEW ROAD				
Site ID:	MAN10199				
Address:	ASHTON NEW ROAD, BESWICK, MANCHESTER, M11 3DL				
Title:	002 SITE LOCATION PLAN				
Project:	H3G 5G UNILATERAL				
Purpose of Issue:	PLANNING				
EE Call ID:	N/A	MBNL Call ID:	N/A	3UK Call ID:	N/A
Master Drawing No:	MAN10199_M001				Issue:
					A

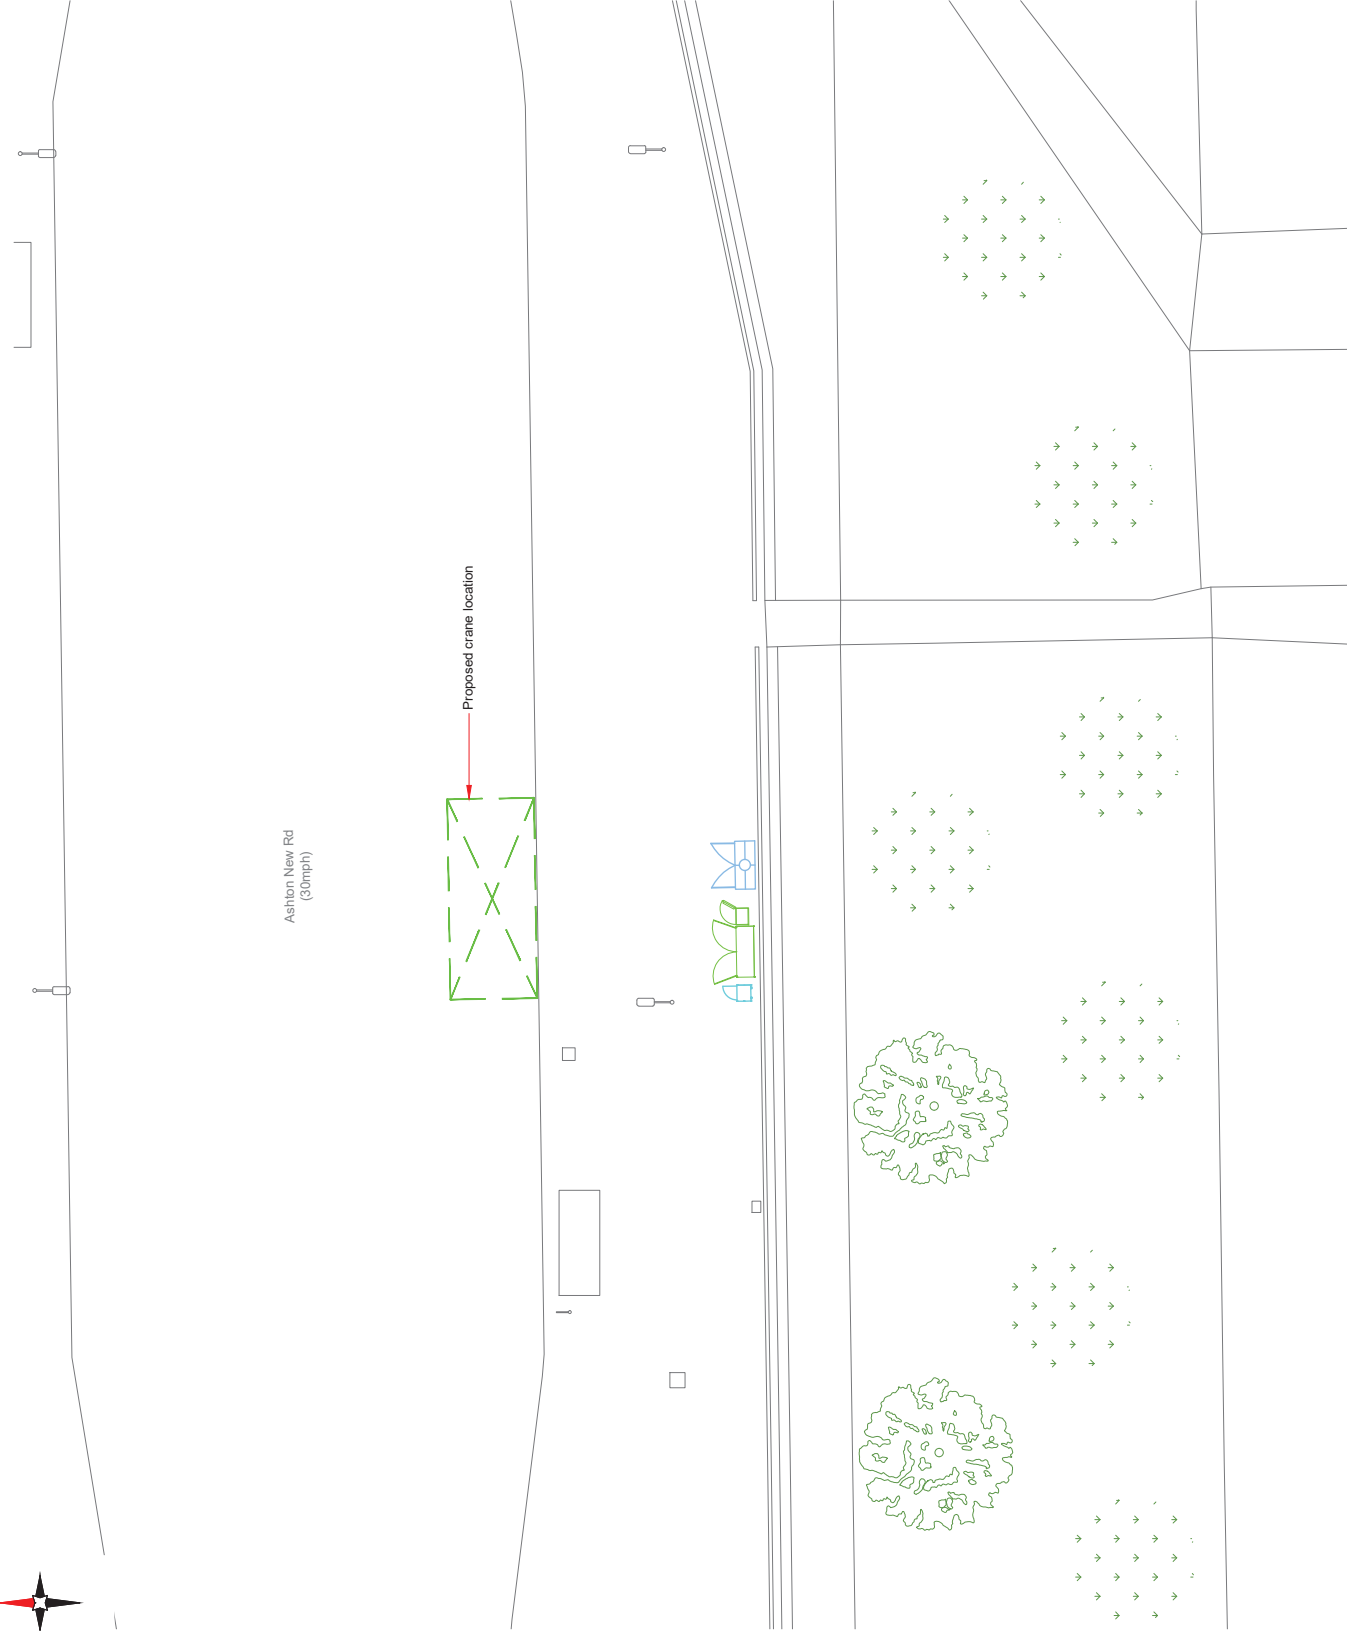

NOTES:

1. ALL DIMENSIONS IN MM UNLESS OTHERWISE NOTED.

PROPOSED CRANE OR CHERRY PICKER LOCATION:



Master	MBNL / EE / H3G	Project	Purpose of Issue	Issue
M001	MBNL	H3G 5G UNILATERAL	Planning	A
Date:	28/03/2020	Revision / Log and Description:		
Drawn:	GDJN	First Issue - Site nomination dated: TBC		
Checked:	GDJN			
Approved:	GDJN			

Hutchison 3G UK Limited
Star House, 20 Greenfield Road
Maddenhead, SL6 1EH
Tel: 01628 765 000
Fax: 01628 765 001

H3G Base Station Information line:
0945 6043000
Available 8am-8pm Monday to Friday



Design Consultant & Principal Contractor:

WHP Telecoms
Unit 1 Maple Park,
Low Fields Avenue, Leeds
LS12 6HH
Tel: 01133023550
e-mail: info@whplecoms.com

Site Name: ASHTON NEW ROAD

Site ID: MAN101199

Address: ASHTON NEW ROAD,
BESWICK,
MANCHESTER,
M11 3DL

Title: 005 CHERRY PICKER & CRANE LOCATION
Project: H3G 5G UNILATERAL

Purpose of Issue: PLANNING

EE Call ID:	MBNL Call ID:	3UK Call ID:
N/A	N/A	N/A
Master Drawing No:		Issue
MAN101199_M001		A



ELEVATION A

Ashton New Rd
(30mph)





Existing approx. 10.3m
high streetlight



Footpath

Existing trafficlight control pillar

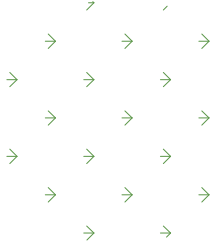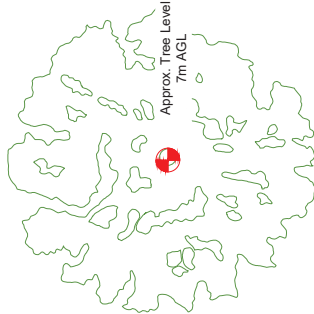

EXISTING SITE PLAN



NOTES:

1. ALL DIMENSIONS IN MM UNLESS OTHERWISE NOTED.

Master	MBNL / EE / H3G	Project	Purpose of Issue	Issue
M001	MBNL	H3G 5G UNILATERAL	Planning	A
Date	28.03.2020			
Drawn	GDJN			
Checked	DH			
Approved	SD			
Revision / Upgrade Description: First Issue - Site nomination dated: TBC				



Hutchison 3G UK Limited
Star House, 20 Grenfell Road
Maddenhead, SL6 1EH
Tel: 01628 765 000
Fax: 01628 765 001
H3G Base Station Information line:
0845 6043000
Available 8am-5pm Monday to Friday

Design Consultant & Principal Contractor:



WHP Telecoms
Unit 1 Maple Park,
Low Fields Avenue, Leeds
LS12 6HH
Tel: 01133023550
e-mail: info@whptelecoms.com

Site Name:

ASHTON NEW ROAD

Site ID:

MAN10199

Address:

ASHTON NEW ROAD,
BESWICK,
MANCHESTER,
M11 3DL

Title:

100 EXISTING SITE PLAN

Project:

H3G 5G UNILATERAL

Purpose of Issue:

PLANNING

EE Call ID:

N/A

MBNL Call ID:

N/A

3UK Call ID:

N/A

Master Drawing No:

MAN10199_M001

Issue:

A

NOTES:
1. ALL DIMENSIONS IN MM UNLESS OTHERWISE NOTED.

Master	MBNL / EE / H3G	Project	Purpose of Issue	Issue
M001	MBNL	H3G 5G UNILATERAL	Planning	A
Date:	28/03/2020	Revision / Upgrade Description:		
Drawn:	CJN	First Issue - Site nomination dated: TBC		
Checked:	CT			
Approved:	SD			



Hutchison 3G UK Limited

Star House, 20 Grenfell Road

Mordenhead, SL6 1EH

Tel: 01628 765 000

Fax: 01628 765 001

H3G Base Station Information line:

0645 6043000

Available 8am-8pm Monday to Friday

WHP Telecoms

Unit 1 Maple Park,

Low Fields Avenue, Leeds

LS12 6HH

Tel: 01133023550

e-mail: info@whplecoms.com

Design Consultant & Principal Contractor:



WHP Telecoms

Unit 1 Maple Park,

Low Fields Avenue, Leeds

LS12 6HH

Tel: 01133023550

e-mail: info@whplecoms.com

Site Name:

ASHTON NEW ROAD

Site ID:

MAN10199

Address:

ASHTON NEW ROAD,
BESWICK,
MANCHESTER,
M11 3DL

Title:

150 EXISTING ELEVATION A


Project:

H3G 5G UNILATERAL

Purpose of Issue:

PLANNING

EE Call ID:	N/A	MBNL Cell ID:	N/A	3UK Cell ID:	N/A
Master Drawing No:					MAN10199_M001
					Issue:
					A

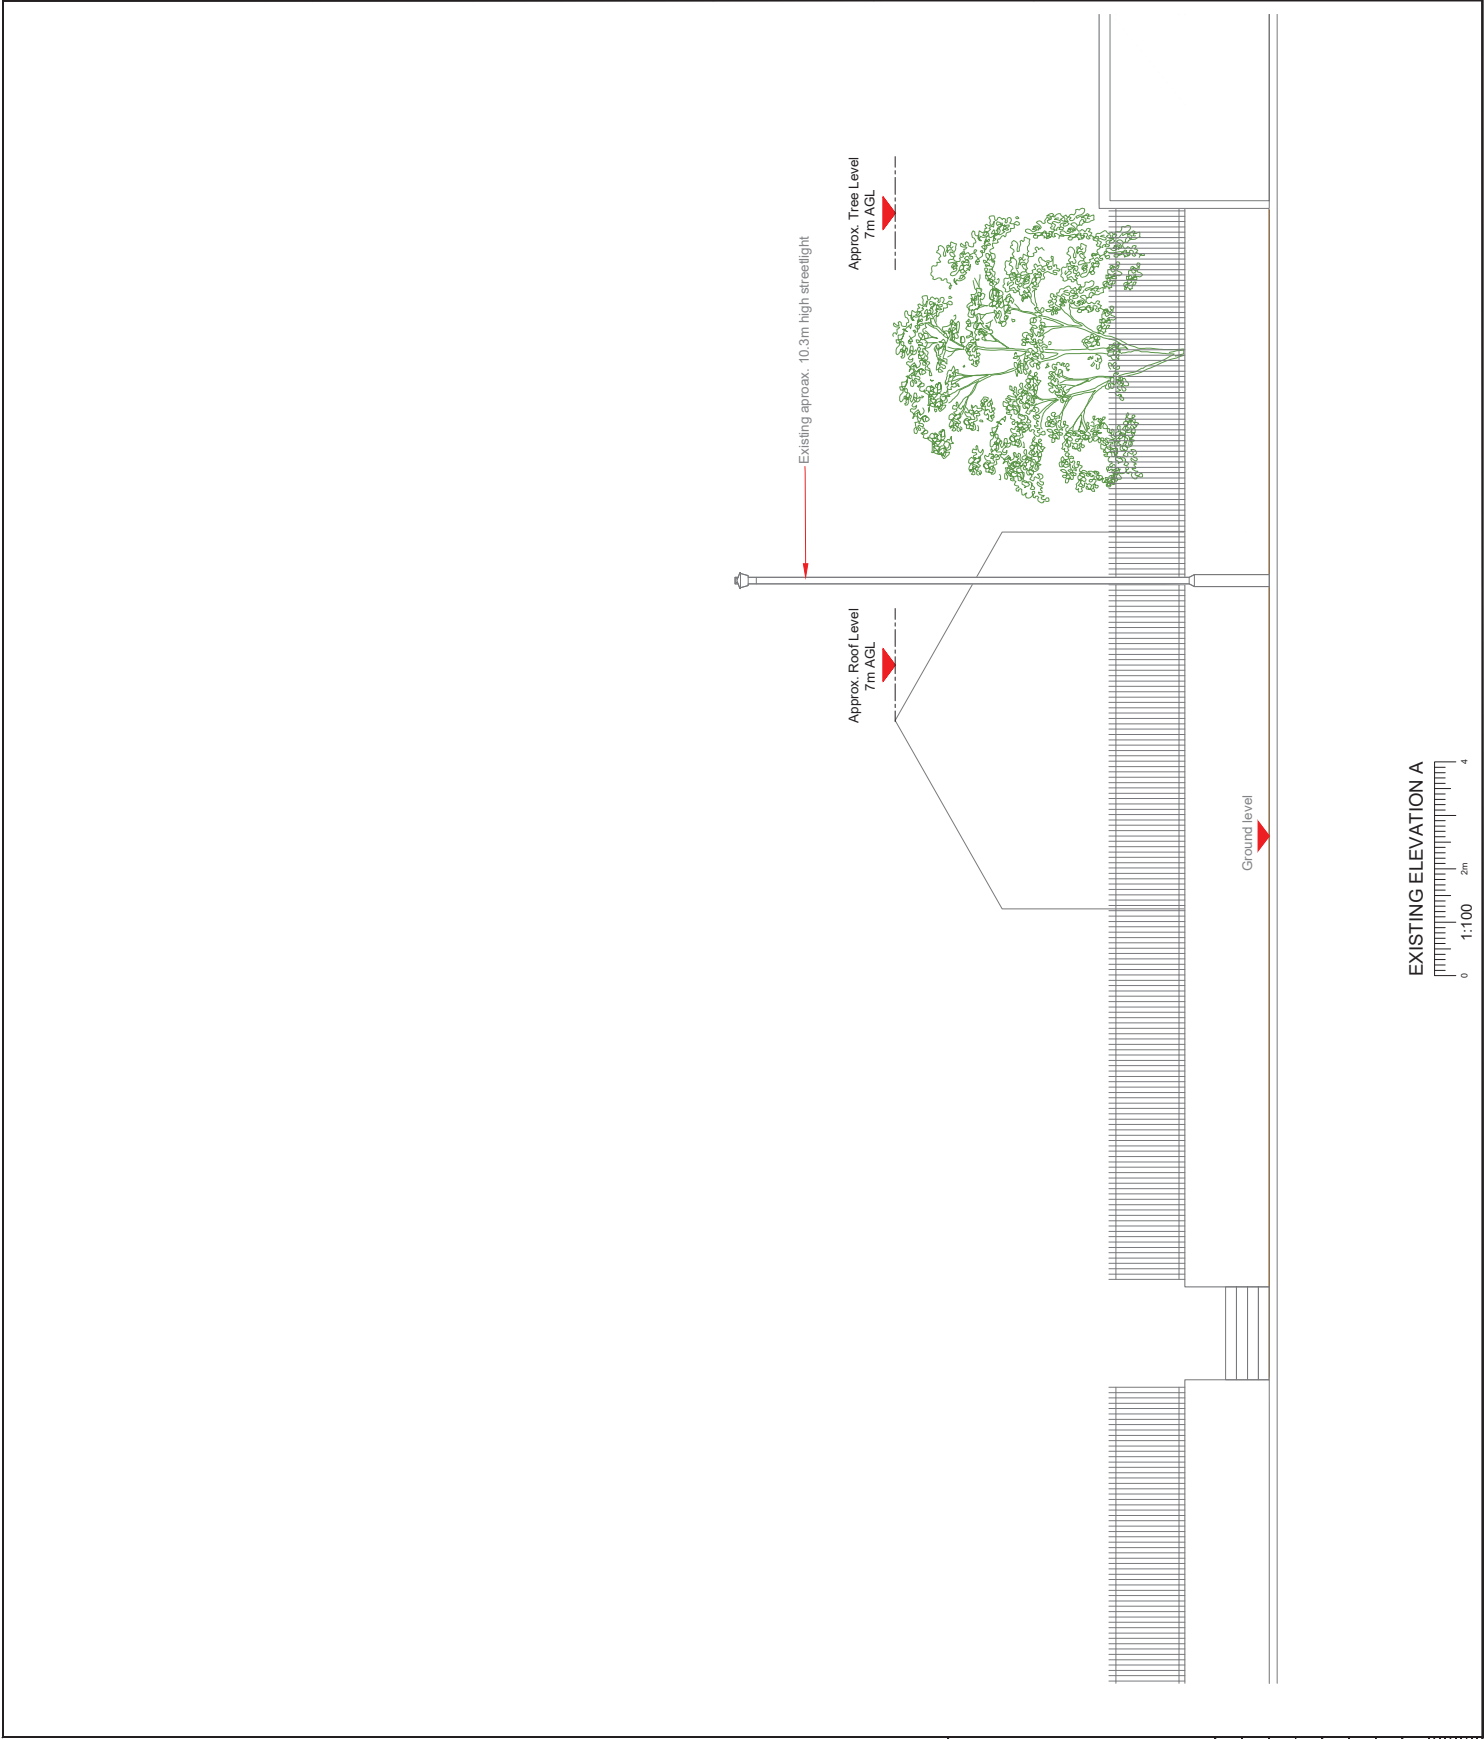




Antenna Aperture ID	Proposed Aperture Bearing	Quarter Shared EIRP(dB)
A1	0°	H3G
A2	0°	H3G
B1	120°	H3G
B2	120°	H3G
C1	240°	H3G
C2	240°	H3G

ELEVATION A

Ashton New Rd
(30mph)

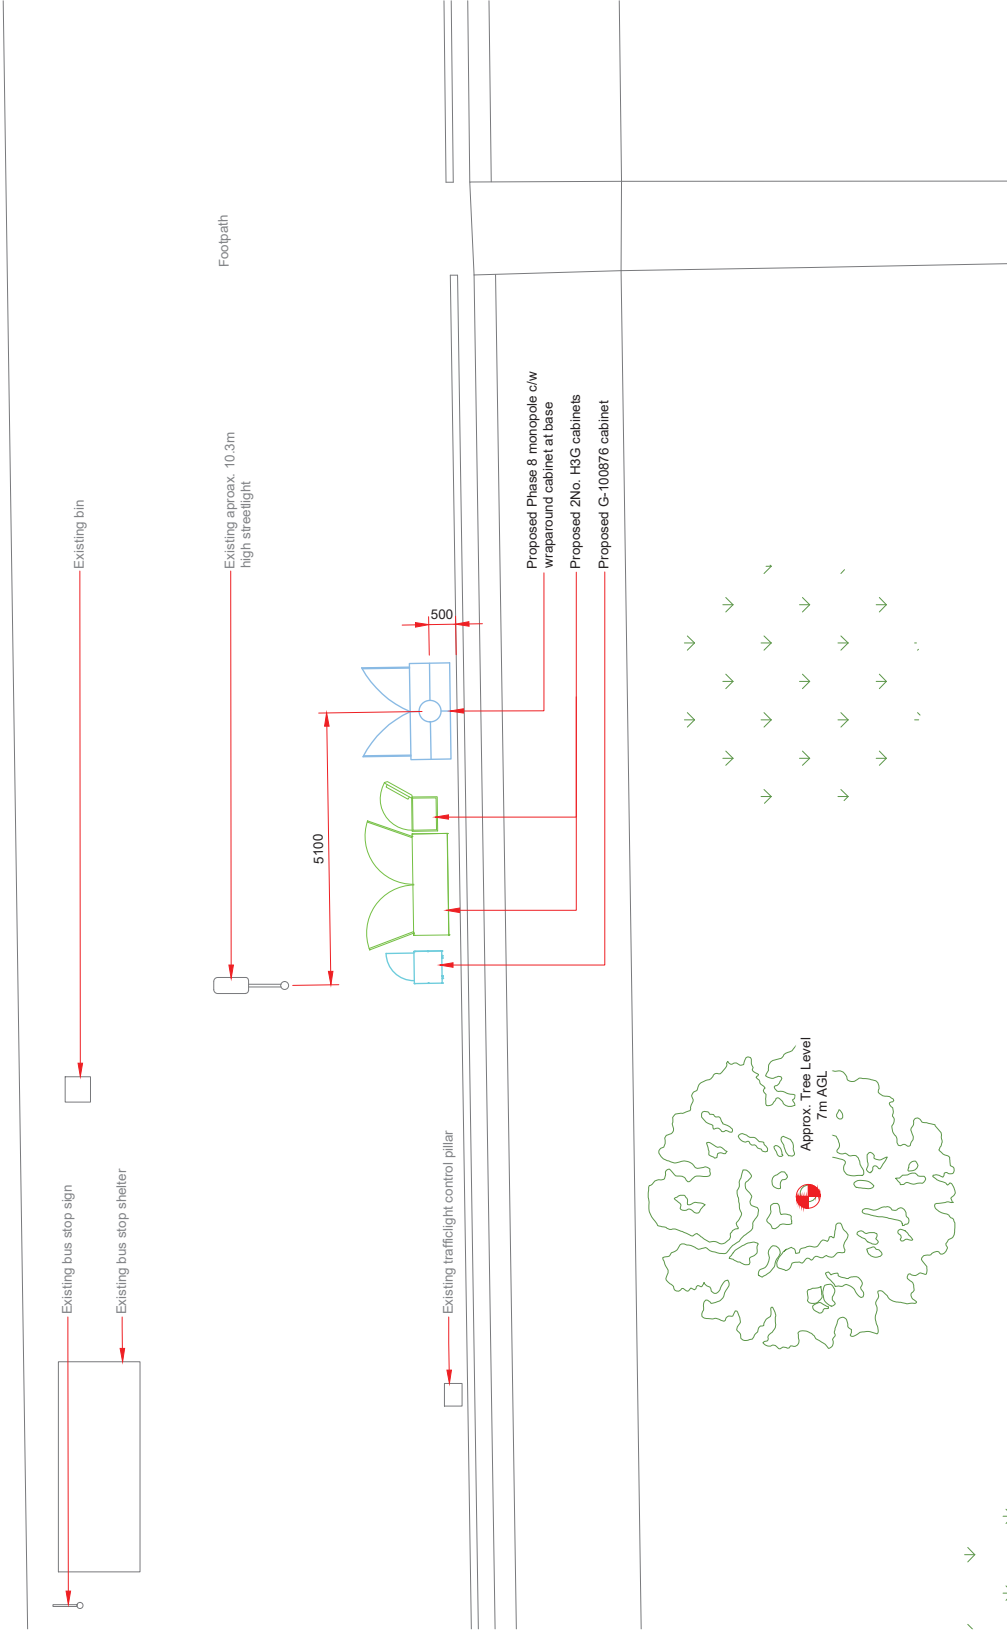

NOTES:
1. ALL DIMENSIONS IN MM UNLESS OTHERWISE NOTED.

Master	MBNL / EE / H3G	Project	Purpose of Issue	Issue
M001	MBNL	H3G 5G UNILATERAL	Planning	A
Date:	28.03.2020	Revision / Upgrade Description:	First Issue - Site nomination dated TBC	
Drawn:	GDJN	Checked:	By:	
Approved:	GDJN	Approved:	By:	

Hutchison 3G UK Limited
Star House, 20 Gentfield Road
Maddenhead, SL6 1EH
Tel: 01628 765 000
Fax: 01628 765 001
H3G Base Station Information line:
0845 6043000
Available 8am-5pm Monday to Friday



Design Consultant & Principal Contractor:

WHP Telecoms
Unit 1 Maple Park,
Low Fields Avenue, Leeds
LS12 6HH
Tel: 01133023550
e-mail: info@whplecoms.com

Site Name: ASHTON NEW ROAD

Site ID: MAN10199

Address: ASHTON NEW ROAD,
BESWICK,
MANCHESTER,
M11 3DL

Title: 210 PROPOSED H3G SITE PLAN

Project: H3G 5G UNILATERAL

Purpose of Issue: PLANNING

EE Call ID: N/A MBNL Call ID: N/A 3UK Call ID: N/A


Master Drawing No: MAN10199_M001 Issue: A

Antenna Aperture ID	Proposed Aperture ID	Quarter Shared Bearing	EEH3G
A1	0°	0°	H3G
A2	0°	0°	H3G
B1	120°	120°	H3G
B2	120°	120°	H3G
C1	240°	240°	H3G
C2	240°	240°	H3G


Top of Tower +20.0m AGL

C/L of AAU +19.60m AGL

C/L of Apertures +17.70m AGL

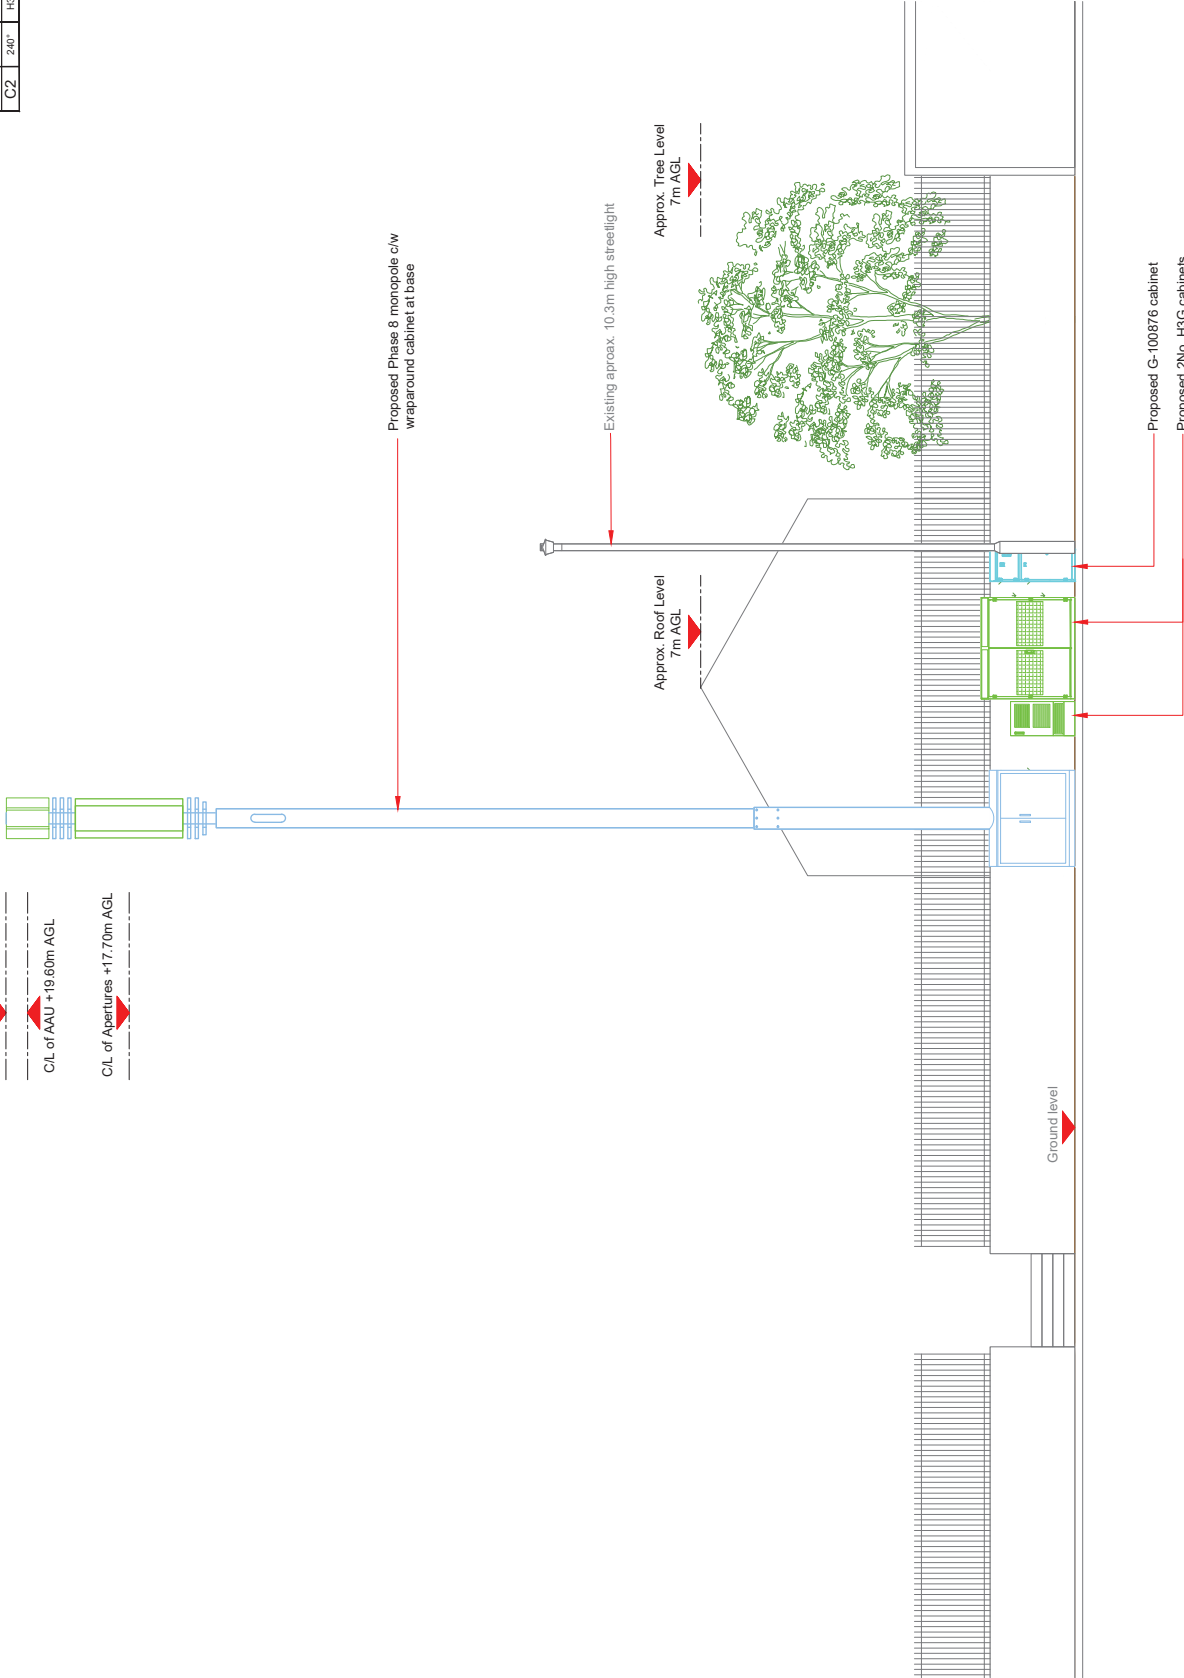

PROPOSED H3G ELEVATION

 

NOTES:

1. ALL DIMENSIONS IN MM UNLESS OTHERWISE NOTED.

Master	MBNL / EE / H3G	Project	Purpose of Issue	Issue
M001	MBNL	H3G 5G UNILATERAL	Planning	A
Date	28.03.2020	Revision / Upgrade Description: First Issue - Site nomination dated: TBC		
Drawn	GDJN			
Checked	DH			
Approved	SD			

Hutchison 3G UK Limited
Star House, 20 Gentrel Road
Maddenhead, SL6 1EH
Tel: 01628 765 000
Fax: 01628 765 001

H3G Base Station Information line:
0945 6043000
Available 8am-8pm Monday to Friday



Design Consultant & Principal Contractor:

WHP Telecoms
Unit 1 Maple Park,
Low Fields Avenue, Leeds
LS12 6HH

Tel: 01133023550
e-mail: info@whplecoms.com



Site Name:	ASHTON NEW ROAD				
Site ID:	MAN10199				
Address:	ASHTON NEW ROAD, BESWICK, MANCHESTER, M11 3DL				
Title:	260 PROPOSED H3G ELEVATION				
Project:	H3G 5G UNILATERAL				
Purpose of Issue:	PLANNING				
EE Call ID:	N/A	MBNL Call ID:	N/A	3UK Call ID:	N/A
Master Drawing No:	MAN10199_M001				Issue:
					A