

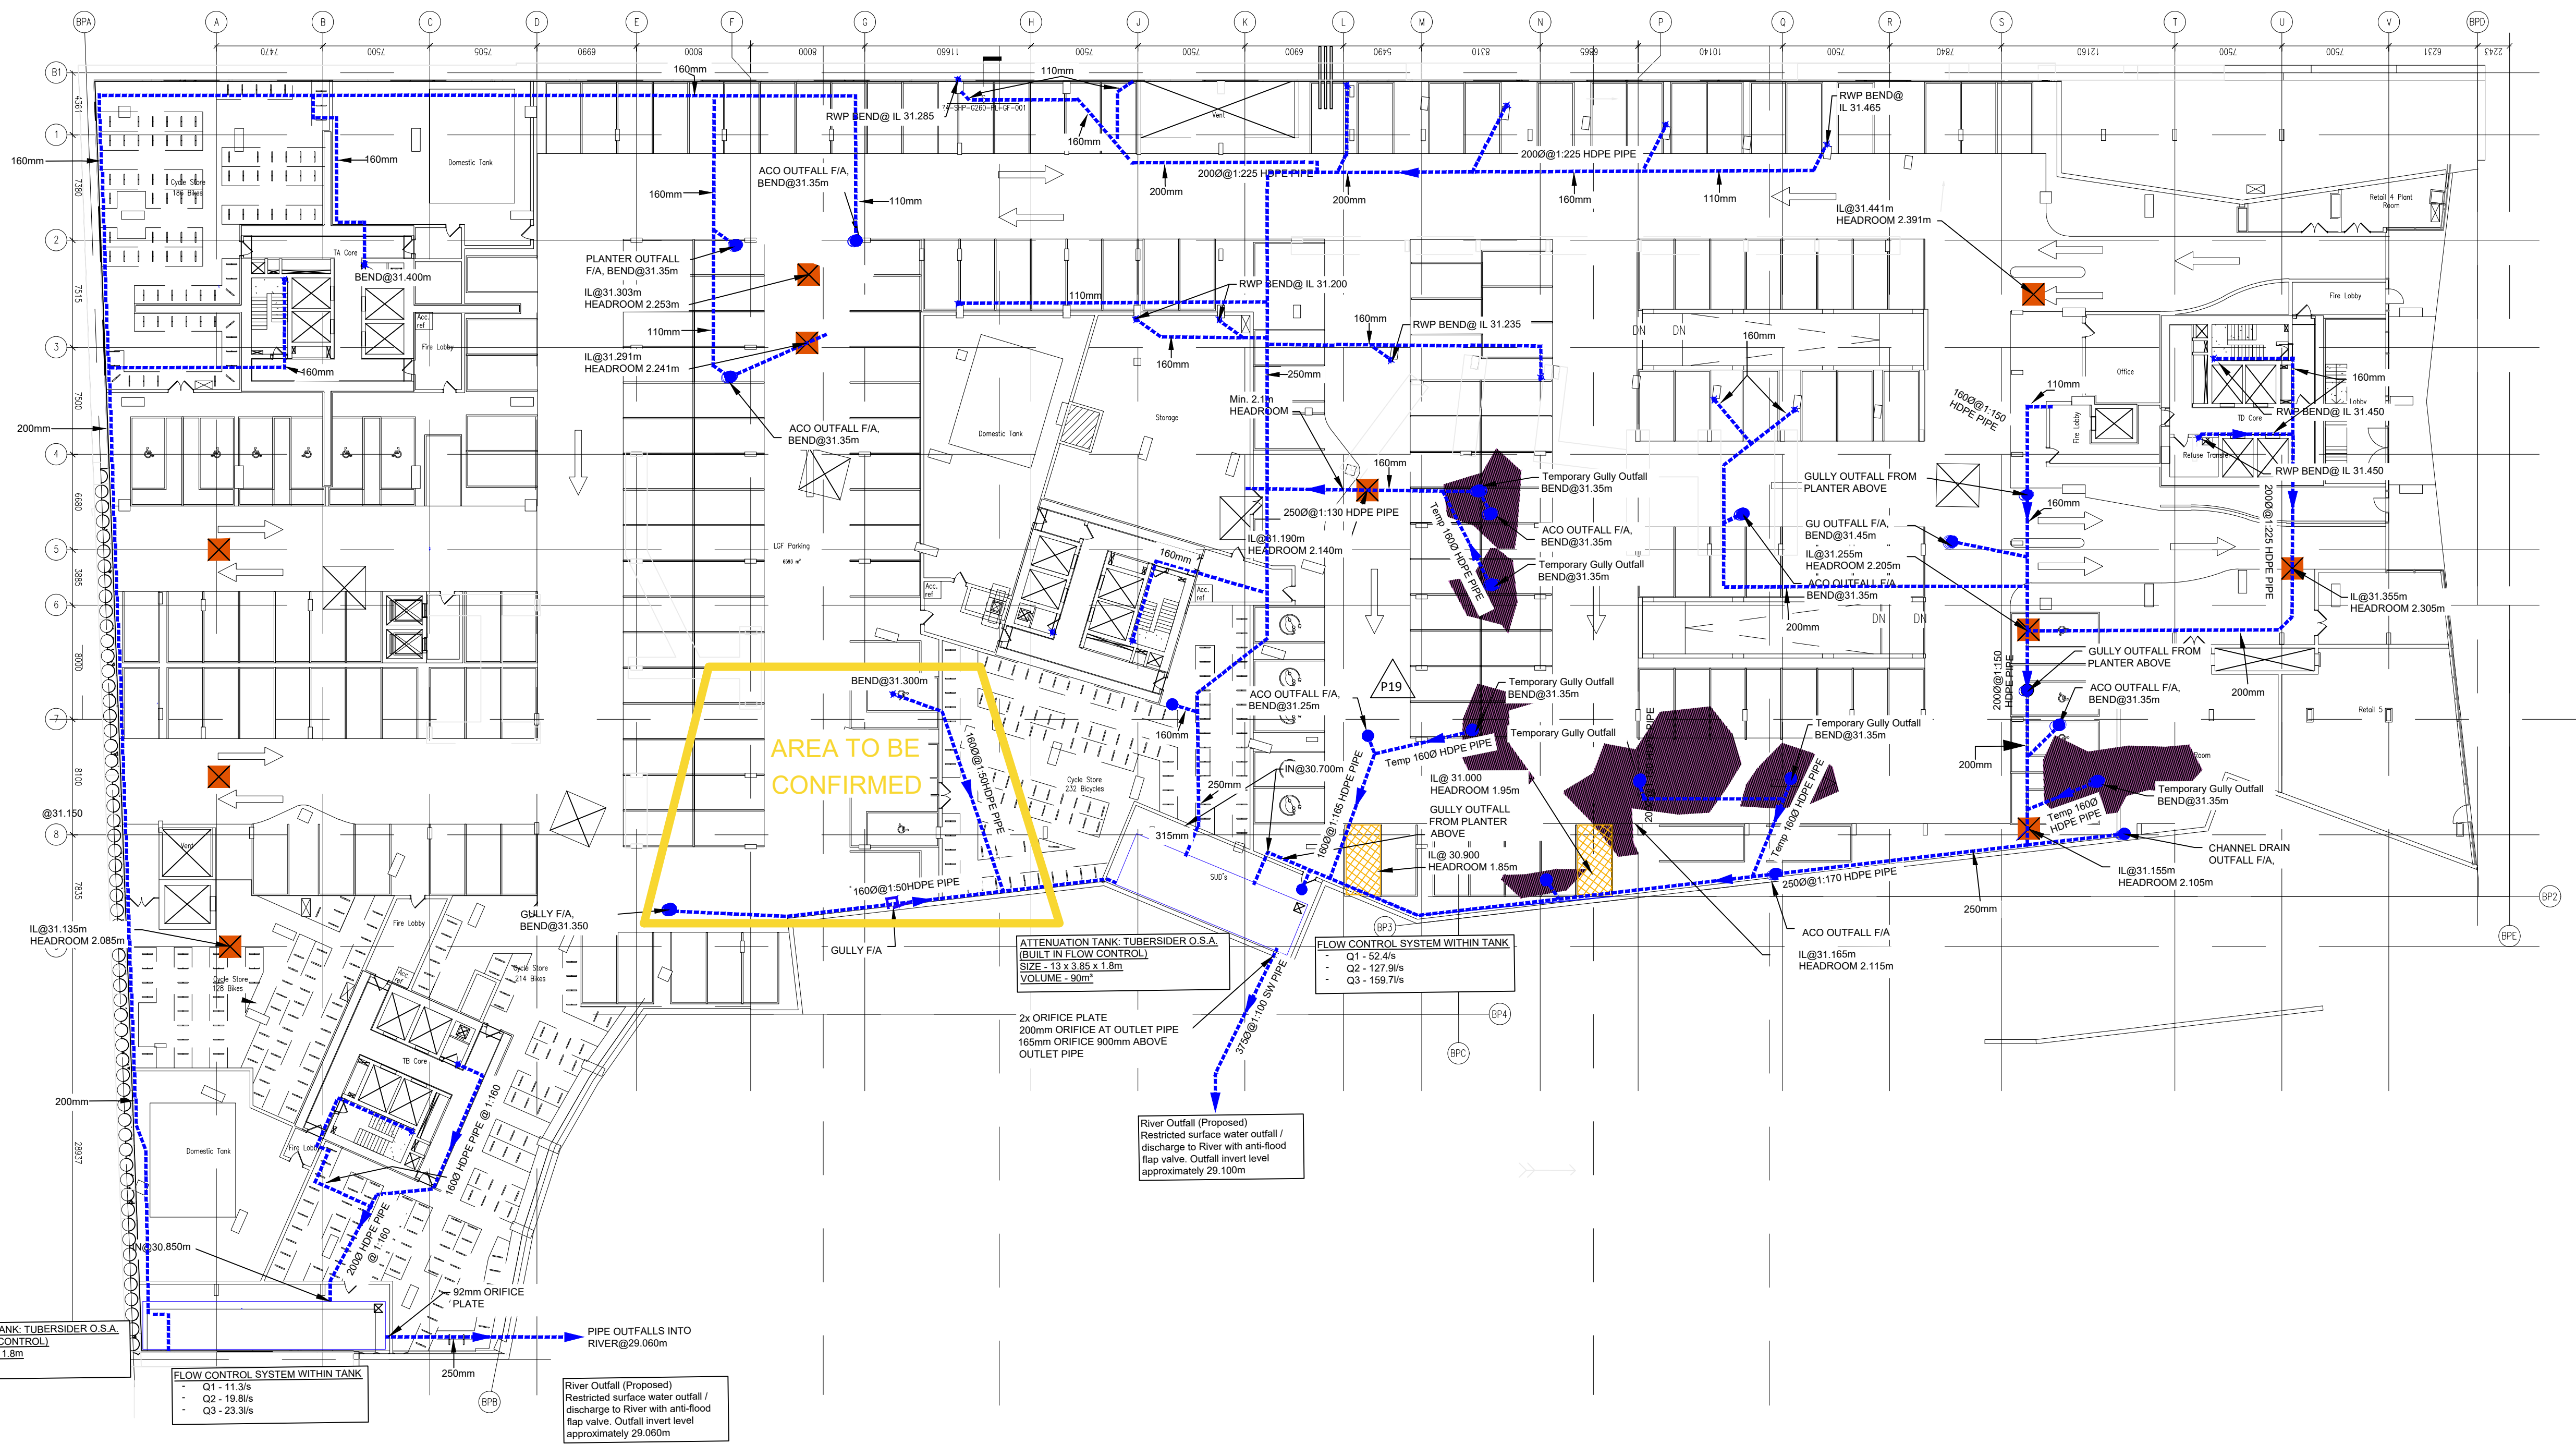
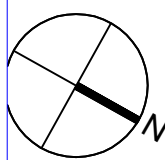


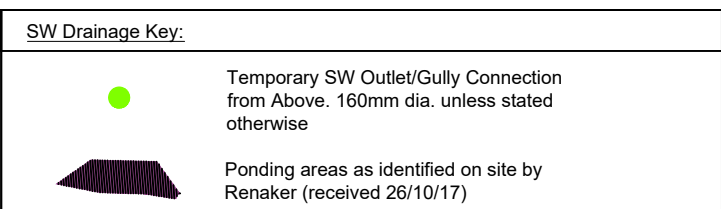

es:
RFACE WATER PIPEWORK INFORMATION:
OWER A: INVERT LEVEL @ BENDS: 31.400 UNLESS OTHERWISE STATED
OWER B: INVERT LEVEL @ BENDS: 31.400 UNLESS OTHERWISE STATED
OWER C: INVERT LEVEL @ BENDS: 31.400 UNLESS OTHERWISE STATED
OWER D: INVERT LEVEL @ BENDS: 31.400 UNLESS OTHERWISE STATED

Notes Continued:
1. NO DRAINAGE DEEPER THAN 28.740m AOD (1:100 YEAR + CLIMATE CHANGE).
2. DRAWING TO BE USED IN CONJUNCTION WITH CIVIC ENGINEERS' FRA & SURFACE WATER MANAGEMENT STRATEGY, JANUARY 2016.

Notes Continued:

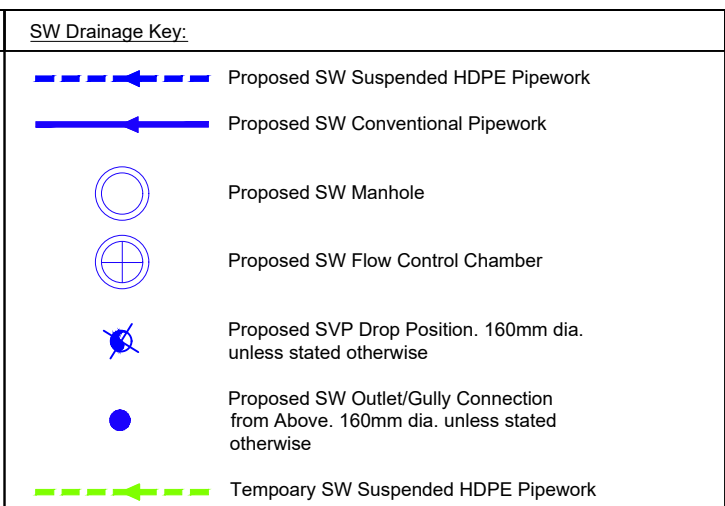

31.10.19	AB	ASBUILT MARKUP	Date:	Rev:	Description:	Drawn:	Chkd:
----------	----	----------------	-------	------	--------------	--------	-------

Project: OWEN STREET MANCHESTER			
Title: SURFACE WATER DRAINAGE LAYOUT LOWER GROUND FLOOR - PLAN			
Scale:	Date:	Drawn:	Checked:
1:250@A1			

Drawing Number: Z1-MWA-G580-PL-LGF-001	Status: ASBUILT
Job Number: -	Revision: AB