

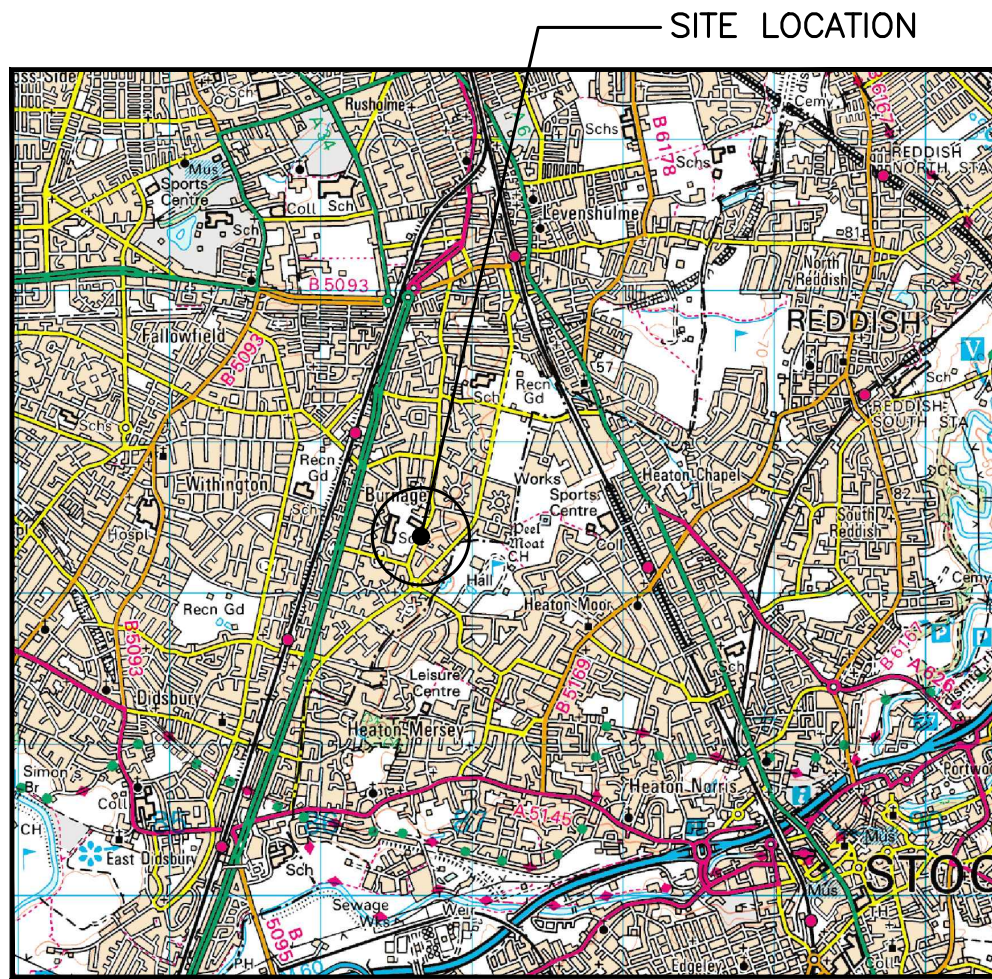


SITE LOCATION
(Scale 1:50000)

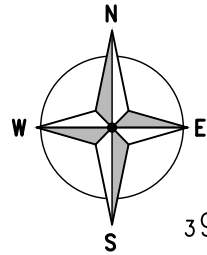

3924 00

3923 00

 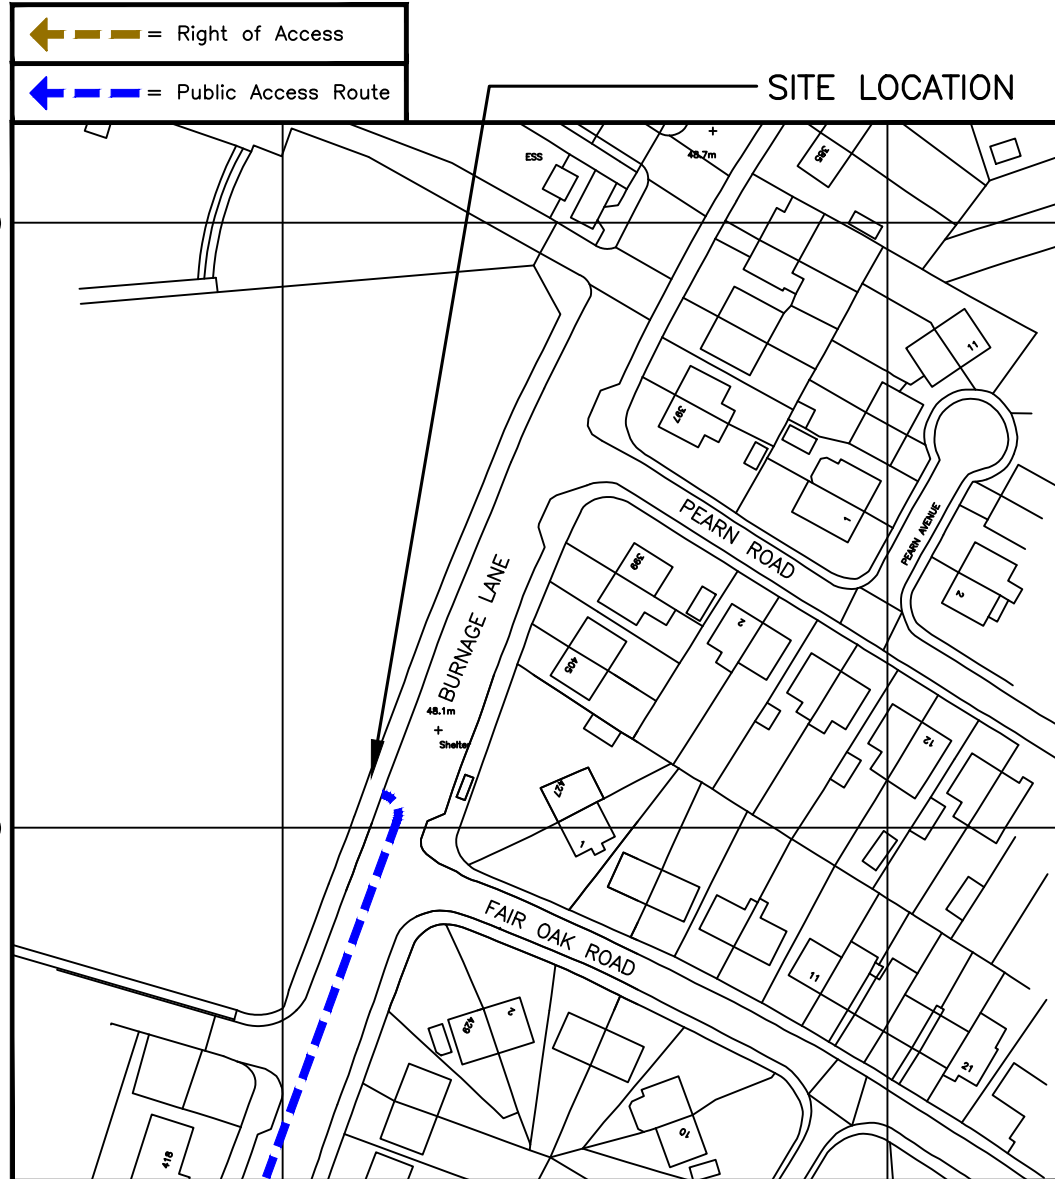


3866 00

3867 00

DETAILED SITE LOCATION
(Scale 1:1250)

Based upon Ordnance Survey map extract
with the permission of the Controller of
Her Majesty's Stationery Office.
Crown copyright.
Licence No. 100060010



SITE PHOTOGRAPH

The drawings comply with TEF & Vodafone Standard ICNIRP guidelines.
Designed in accordance with CORNERSTONE document: SDN0008

ALL DIMENSIONS ARE IN mm UNLESS NOTED OTHERWISE

N.G.R | E: 386615 N: 392309

DIRECTIONS TO SITE:
TRAVELLING NORTH ON THE M60, EXIT AT
JCT. 5 TO A5103/PRINCESS ROAD.
FOLLOW THE ROAD THEN TURN RIGHT TO
MAULDETH ROAD W. CONTINUE ON THE ROAD
THEN TURN RIGHT TO BURNAGE LANE. SITE IS
LOCATED ON THE RIGHT HAND SIDE OF THE
ROAD NEXT TO BURNAGE ACADEMY'S FIELD.

NOTES:

A	Issued for Construction	ABJ	UP	12.02.20	
REV	MODIFICATION	BY	CH	DATE	

CLARKE
telecom
Unit E, Madison Place, Northampton Road,
Manchester, M40 5AG
Tel: 0161 785 4500
Fax: 0161 785 4501
Web: www.clarke-telecom.com


O₂
BEACON 3

Cell Name		Opt.
SW OPPOSITE FAIR OAK ROAD		A
Cell ID No		
CORNERSTONE	TEF	VF
302925	088921	N/A

Site Address / Contact Details

BURNAGE LANE
BURNAGE
GREATER MANCHESTER
M19 1FG

Drawing Title: SITE LOCATION MAPS				
Purpose of issue: CONSTRUCTION				Dwg Rev:
Drawing Number: 100				A
Surveyed By: MS		Original Sheet Size: A3		Pack Issue:
Drawn: ABJ	Date: 12.02.20	Checked: UP	Date: 12.02.20	A

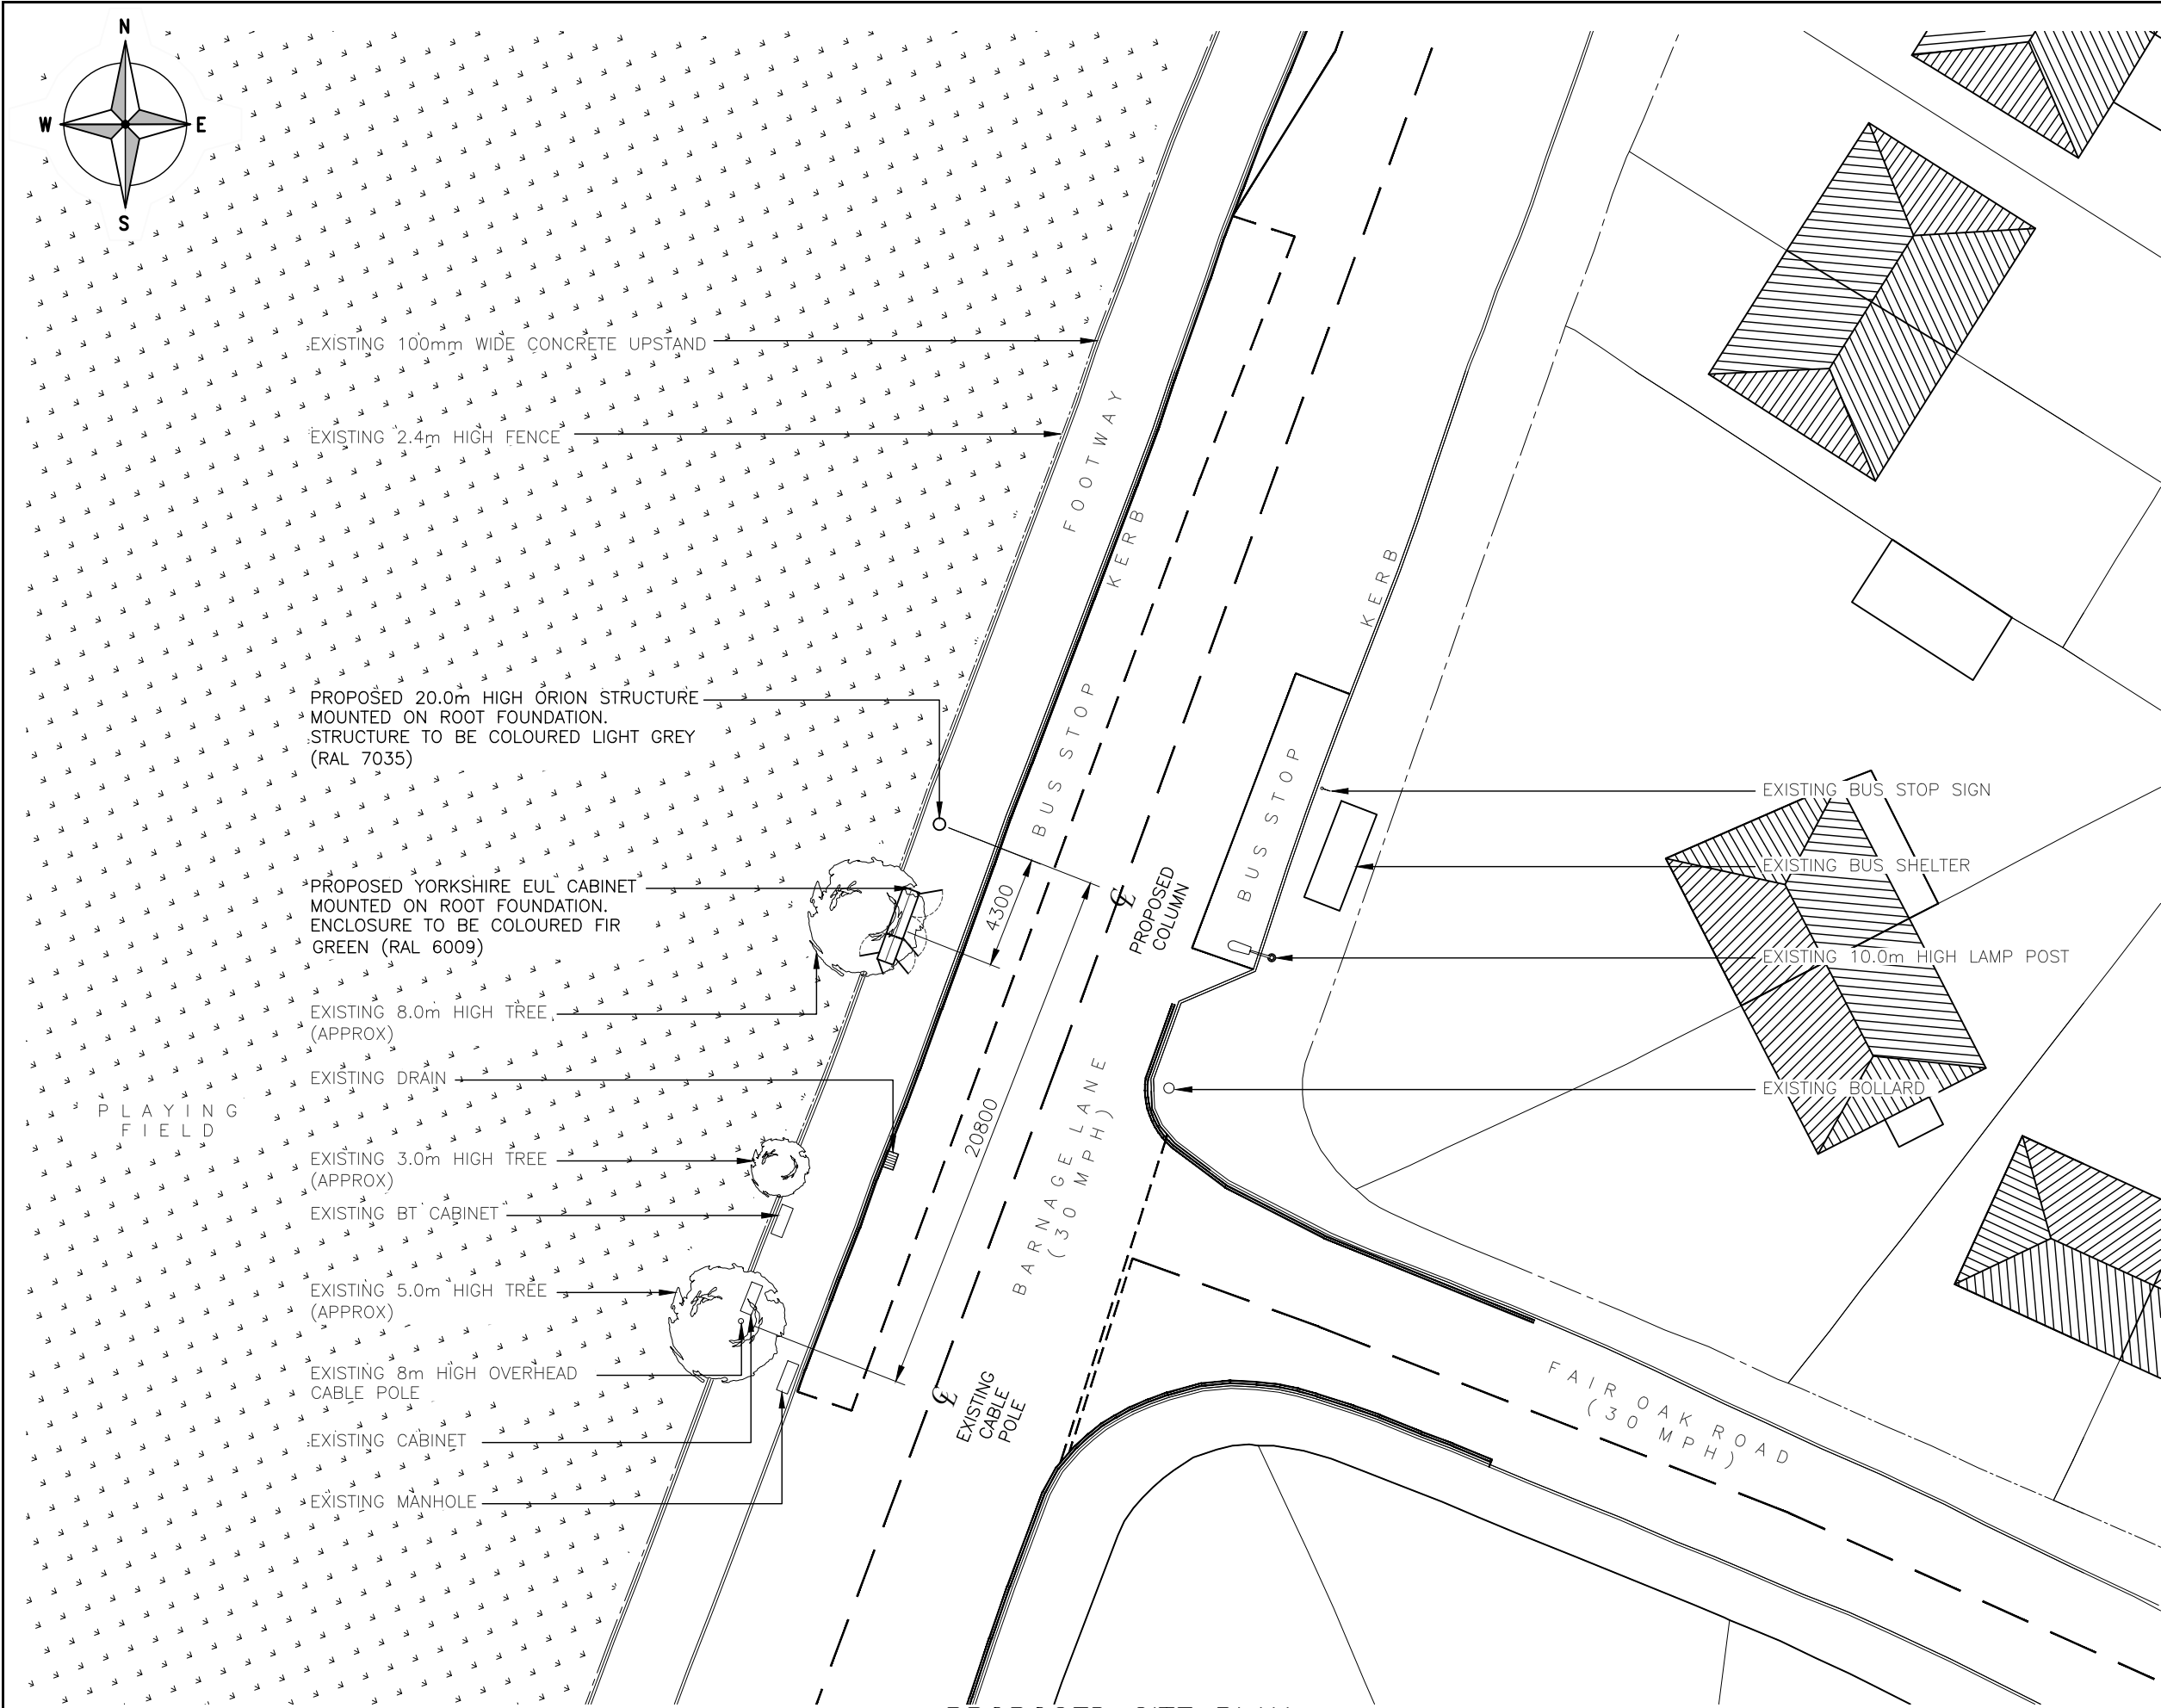

PROPOSED SITE PLAN
(1:250)

The drawings comply with TEF & Vodafone Standard ICNIRP guidelines.
Designed in accordance with CORNERSTONE document: SDN0008

ALL DIMENSIONS ARE IN mm UNLESS NOTED OTHERWISE

N.G.R E: 386615 N: 392309

NOTES:

A	Issued for Construction	ABJ	UP	12.02.20
REV	MODIFICATION	BY	CH	DATE



Unit E, Madison Place, Northampton Road,
Manchester, M40 5AG
Tel: 0161 785 4500
Fax: 0161 785 4501
Web: www.clarke-telecom.com




BEACON 3

Cell Name	Opt.
SW OPPOSITE FAIR OAK ROAD	A

Cell ID No		
CORNERSTONE	TEF	VF
302925	088921	N/A

Site Address / Contact Details		
BURNAGE LANE BURNAGE GREATER MANCHESTER M19 1FG		

Drawing Title: PROPOSED SITE PLAN				
Purpose of issue: CONSTRUCTION				Dwg Rev:
Drawing Number: 201				A
Surveyed By: AG		Original Sheet Size: A3		Pack Issue:
Drawn: ABJ	Date: 12.02.20	Checked: UP	Date: 12.02.20	A

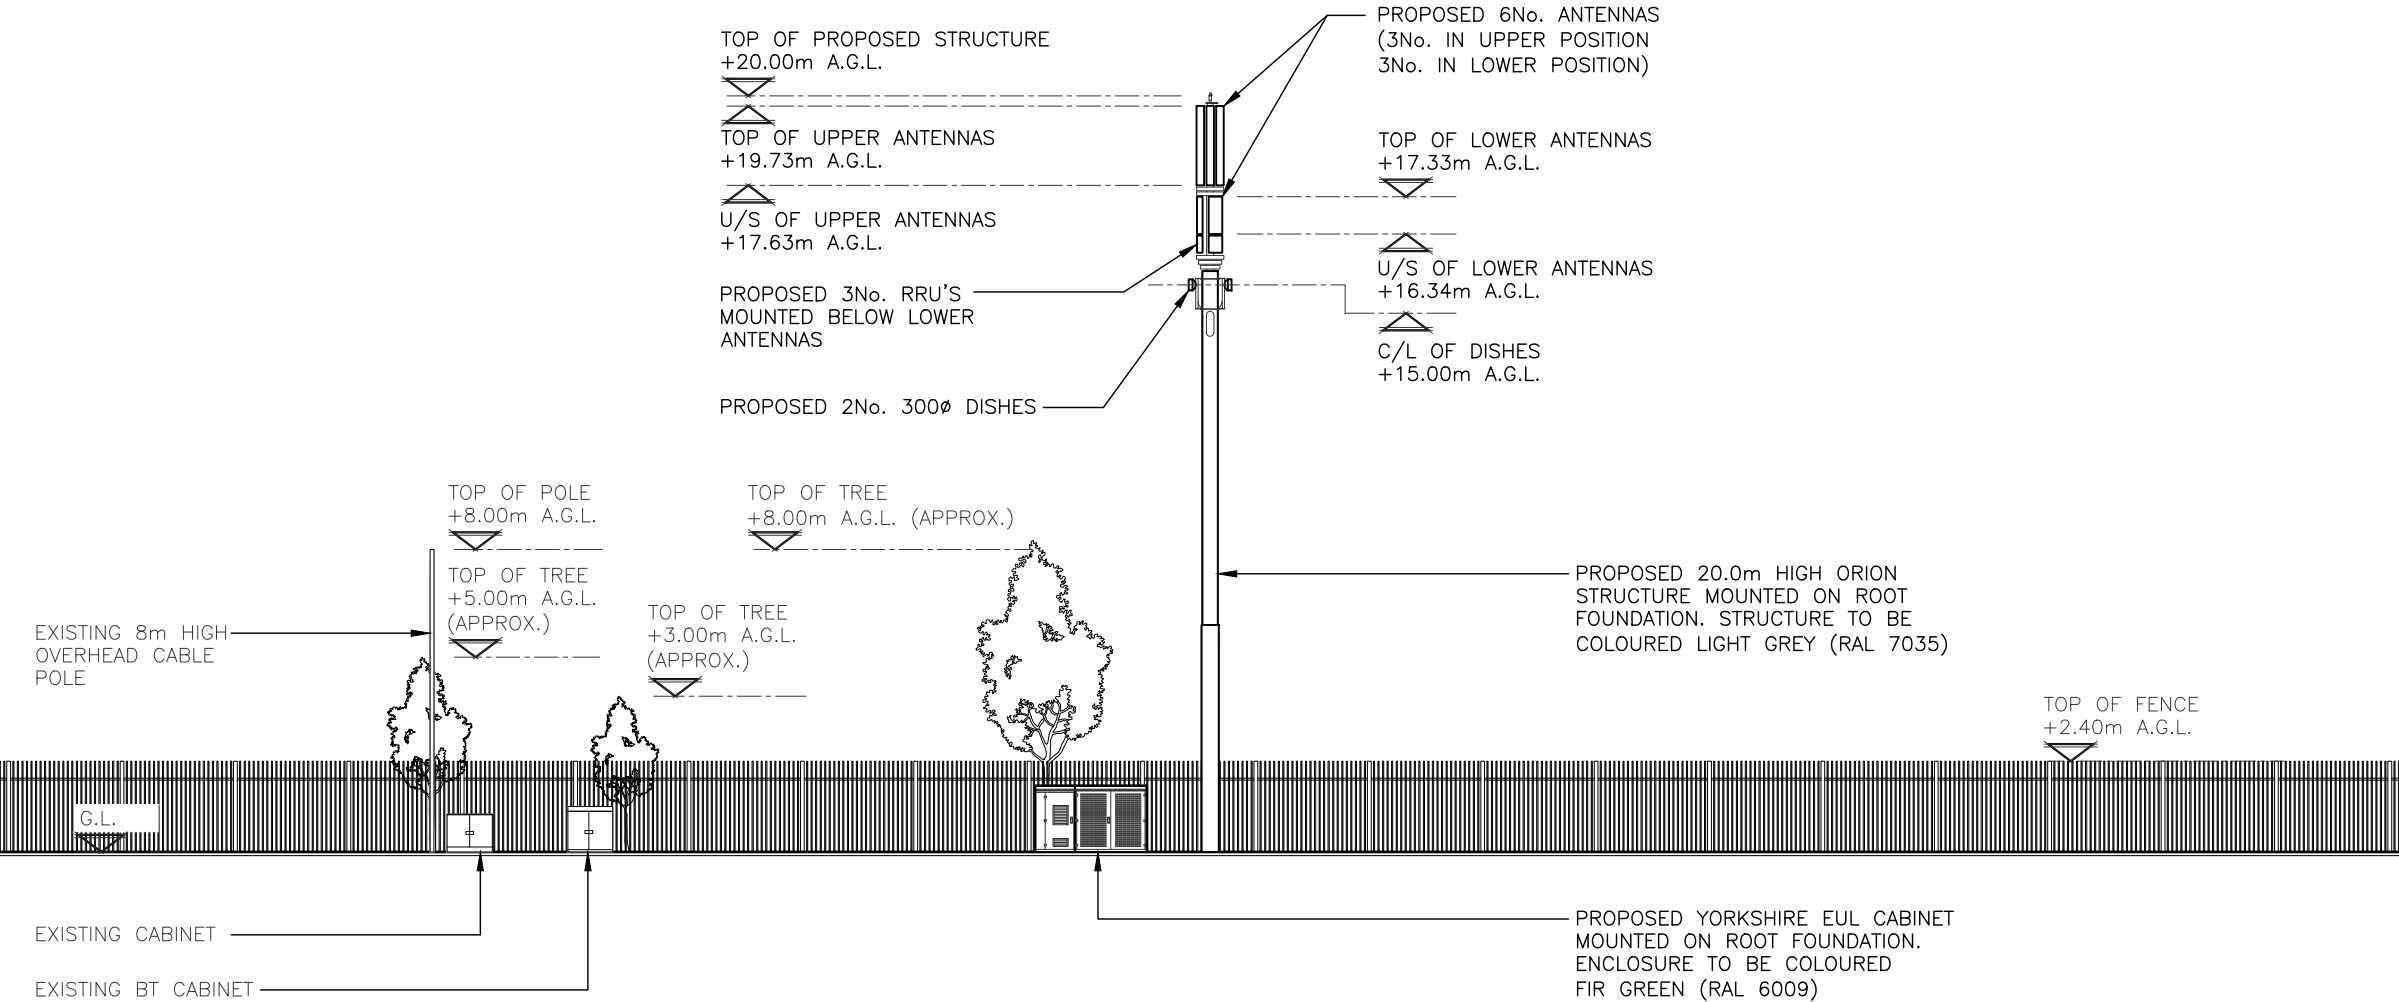

PROPOSED SOUTH EAST ELEVATION
(1:200)

The drawings comply with TEF & Vodafone Standard ICNIRP guidelines.
Designed in accordance with CORNERSTONE document: SDN0008

ALL DIMENSIONS ARE IN mm UNLESS NOTED OTHERWISE

N.G.R | E: 386615 N: 392309

NOTES:

A	Issued for Construction	ABJ	UP	12.02.20
REV	MODIFICATION	BY	CH	DATE

Unit E, Madison Place, Northampton Road,
Manchester, M40 5AG
Tel: 0161 785 4500
Fax: 0161 785 4501
Web: www.clarke-telecom.com

BEACON 3

Cell Name	Opt.
SW OPPOSITE FAIR OAK ROAD	A

Cell ID No		
CORNERSTONE	TEF	VF
302925	088921	N/A

Site Address / Contact Details		
BURNAGE LANE BURNAGE GREATER MANCHESTER M19 1FG		

Drawing Title: PROPOSED SITE ELEVATION				
Purpose of issue: CONSTRUCTION				Dwg Rev:
Drawing Number: 301				A
Surveyed By: AG		Original Sheet Size: A3		Pack Issue:
Drawn: ABJ	Date: 12.02.20	Checked: UP	Date: 12.02.20	A