


- LEGEND
- SUPPLY DIFFUSER
  - EXTRACT GRILLE
  - EXTRACT VALVE
  - MECHANICAL VENTILATION WITH HEAT RECOVERY UNIT
  - EXTRACT FAN
  - CEILING ACCESS HATCH
  - VOLUME CONTROL DAMPER
  - SMOKE DAMPER

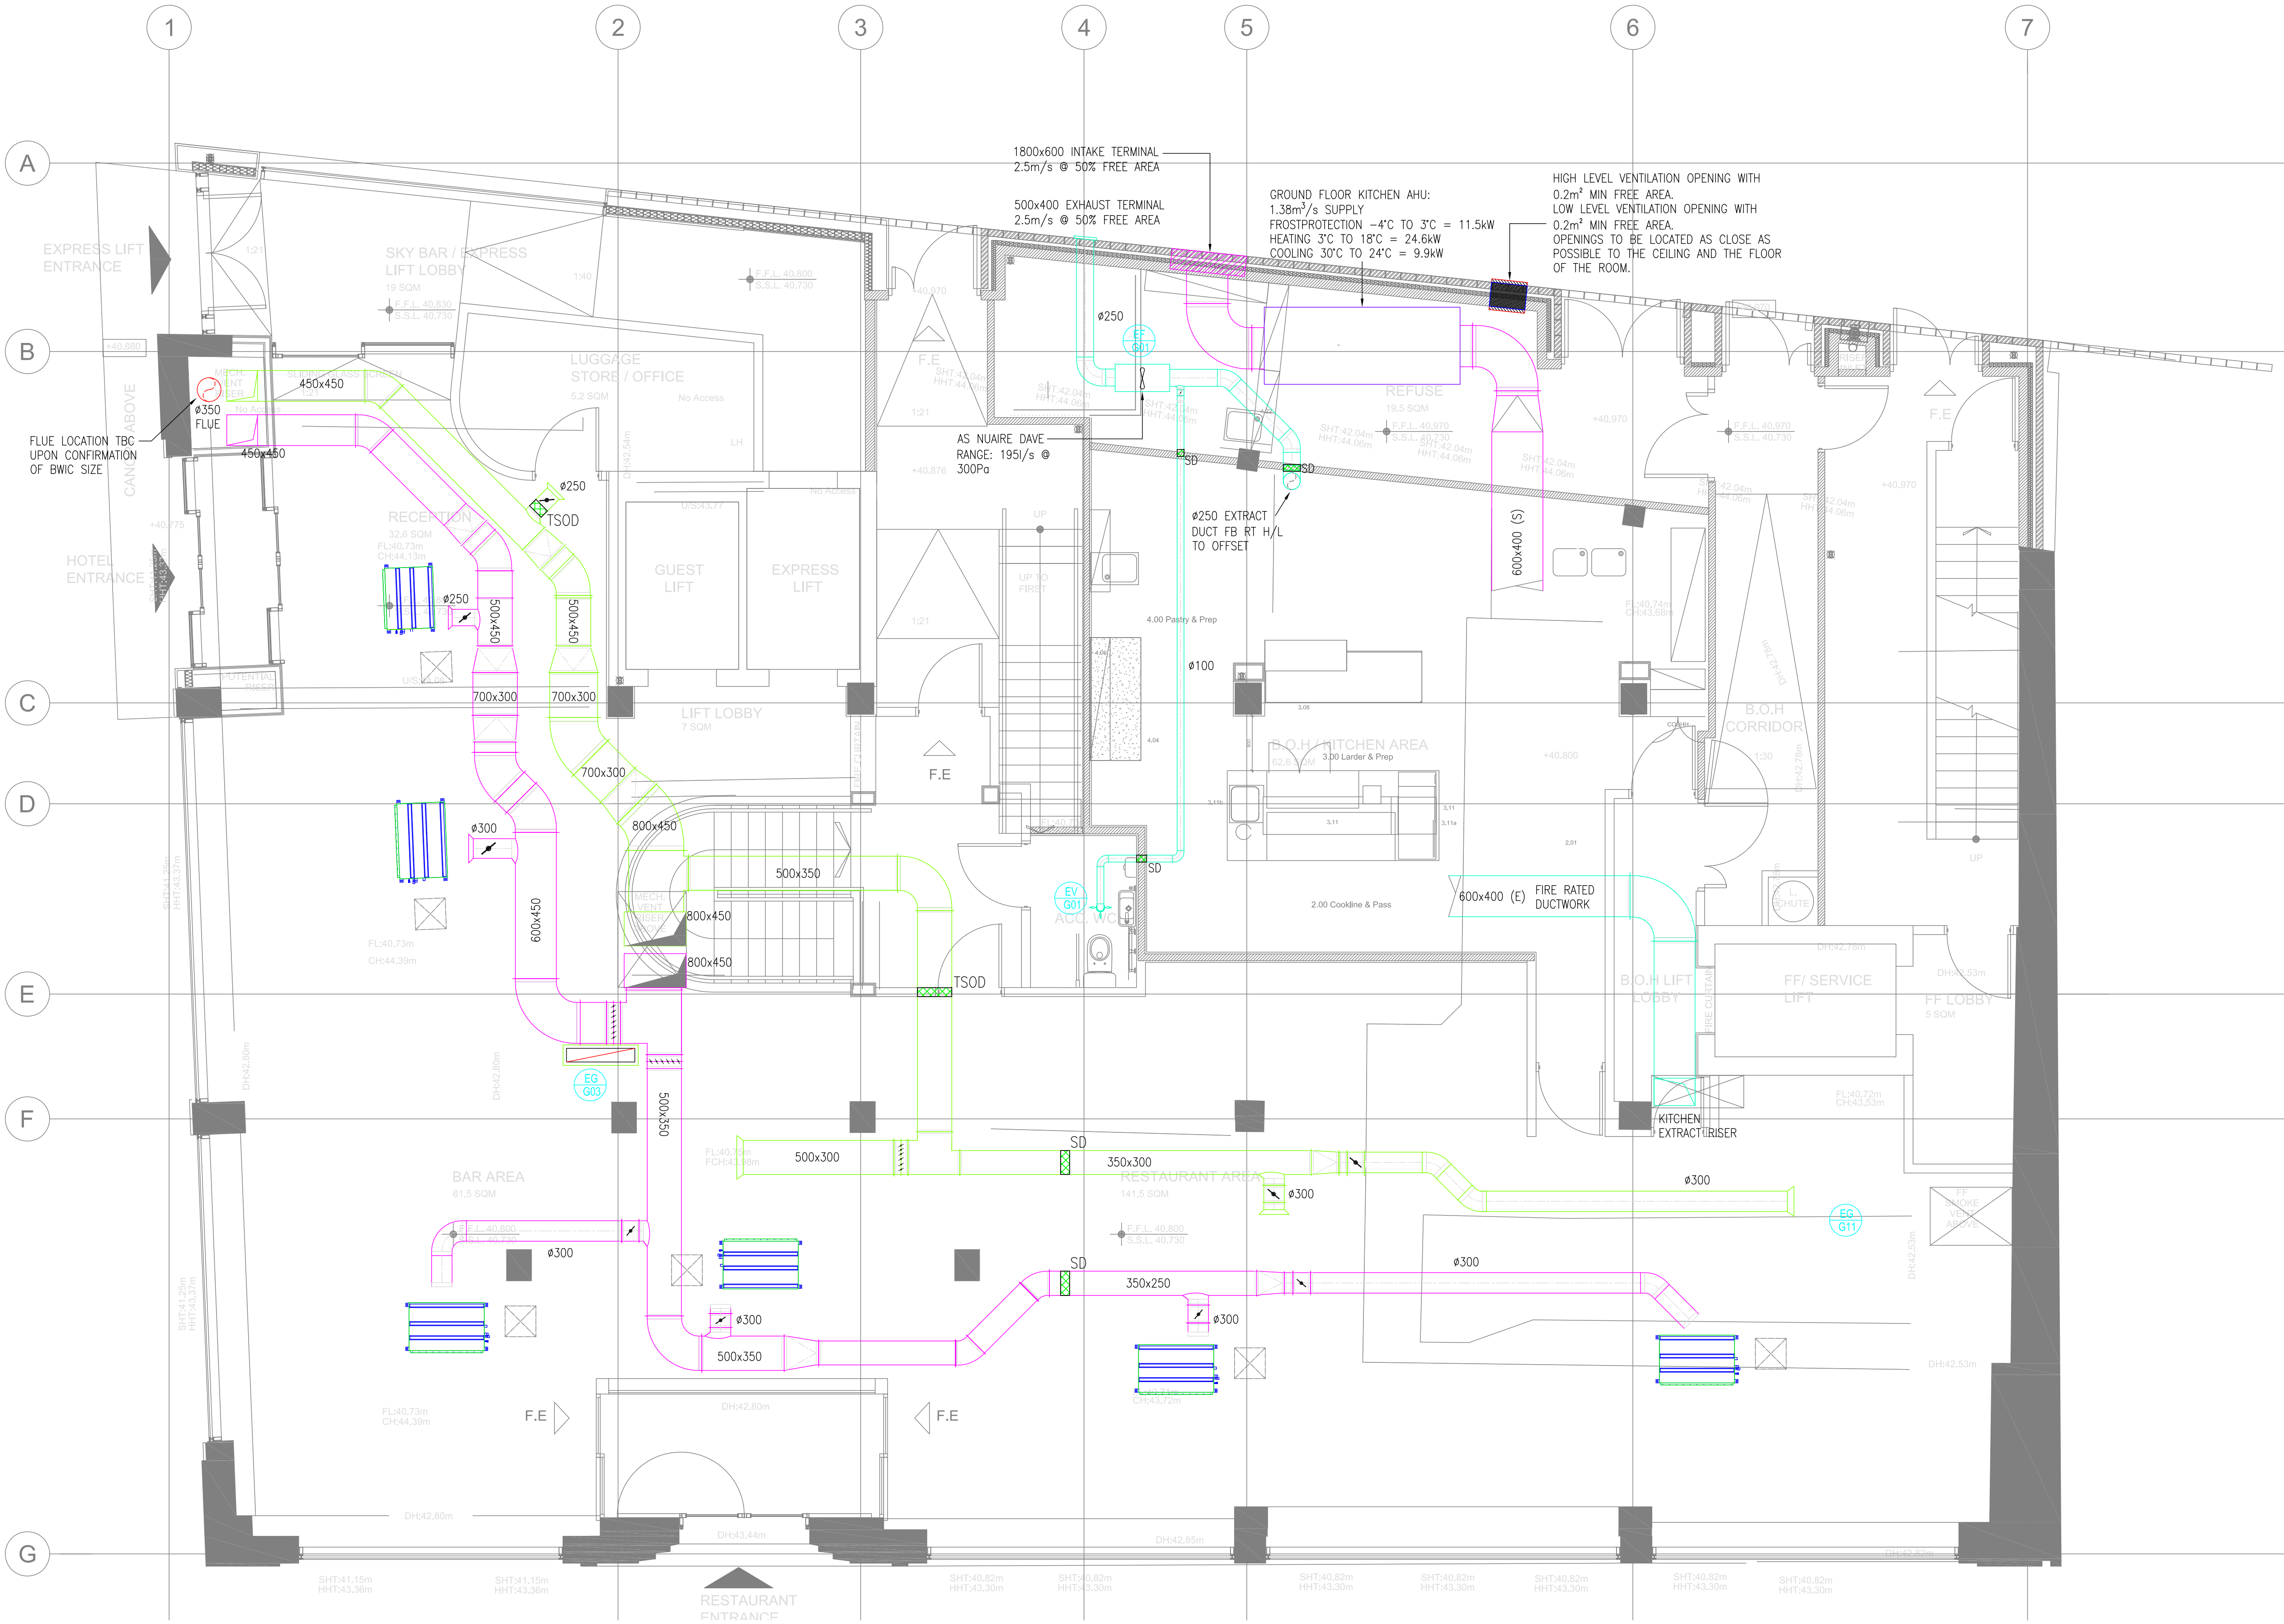

Exhaust Valve Schedule

| Ref     | Type          | System | Duty   | Plenum | Spigot size | Damper |
|---------|---------------|--------|--------|--------|-------------|--------|
| EV/G/01 | Exhaust Valve | ACC WC | 20 l/s | No     | 1250        | Yes    |

DESIGNED MC 21.01.20 DRAWN CG 21.01.20 APPROVED  
REV T1 TENDER ISSUE

STATUS TENDER



CLIENT WHITAKER HORTON LIMITED

PROJECT MALMAISON MANCHESTER

TITLE MECHANICAL SERVICES VENTILATION LAYOUT GROUND FLOOR

SCALE: 1:50 @ A1 DATE: JAN 2020  
DRAWN: CG ENGINEER: CSM  
CHECKED: APPROVED:

18112

M

57-02

T1