


GROUND FLOOR LIGHTING LAYOUT

SEE SEPARATE LIGHTING DOCUMENT FOR SPECIFICATIONS

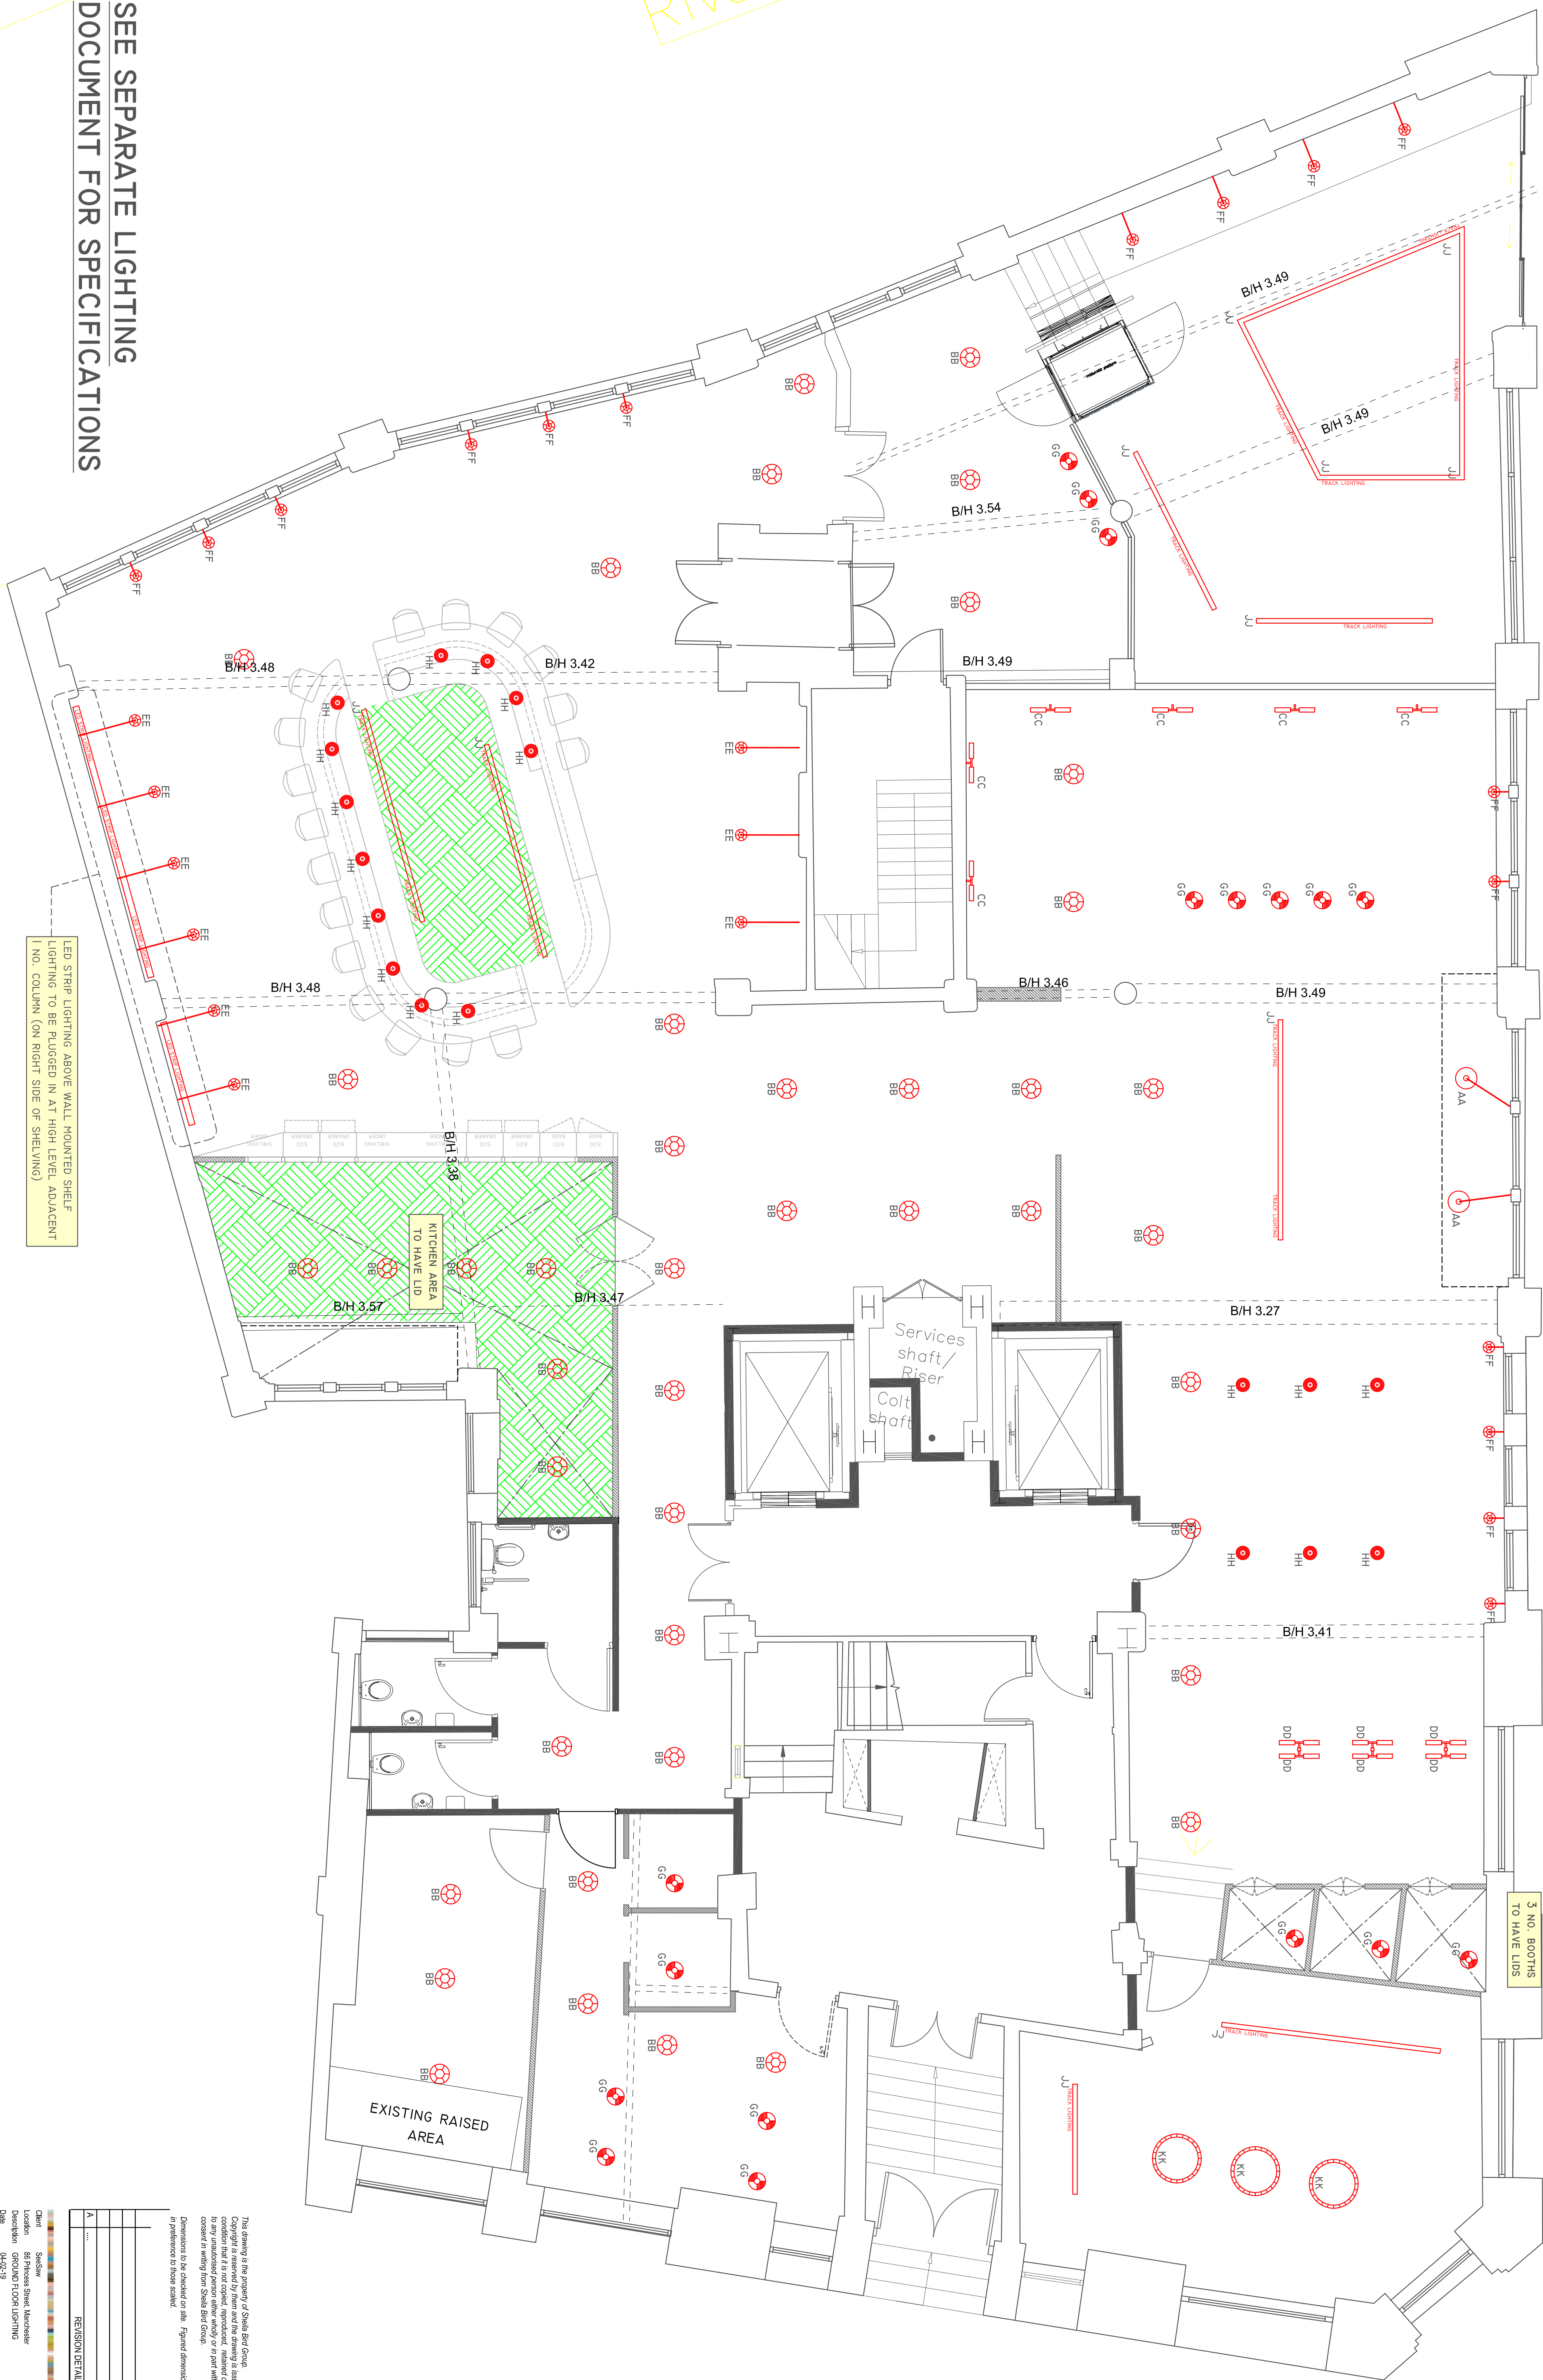

This drawing is the property of Sheila Bird Group. Copyright is reserved by them and this drawing is issued on the condition that it is not copied, reproduced, retained or disclosed to any unauthorised person either wholly or in part without the consent in writing from Sheila Bird Group.

Dimensions to be checked on site. Figured dimensions to be taken in preference to those called.

REVISION DETAILS

A	DATE
...	...

Client Sheila Bird Group
Location 86 Phoenix Street, Manchester
Description GROUND FLOOR LIGHTING
Date 04-02-19

Scale 1:50 @ A1
Dwg No. 3795-F01-002 ...
Rev

13 BUILDING CONSULTING
13 Shirley Street
Manchester
M6 6SH
(0161) 632 0632
(0161) 632 2632
info@sheilabird.com
www.sheilabird.com

River

Drin