


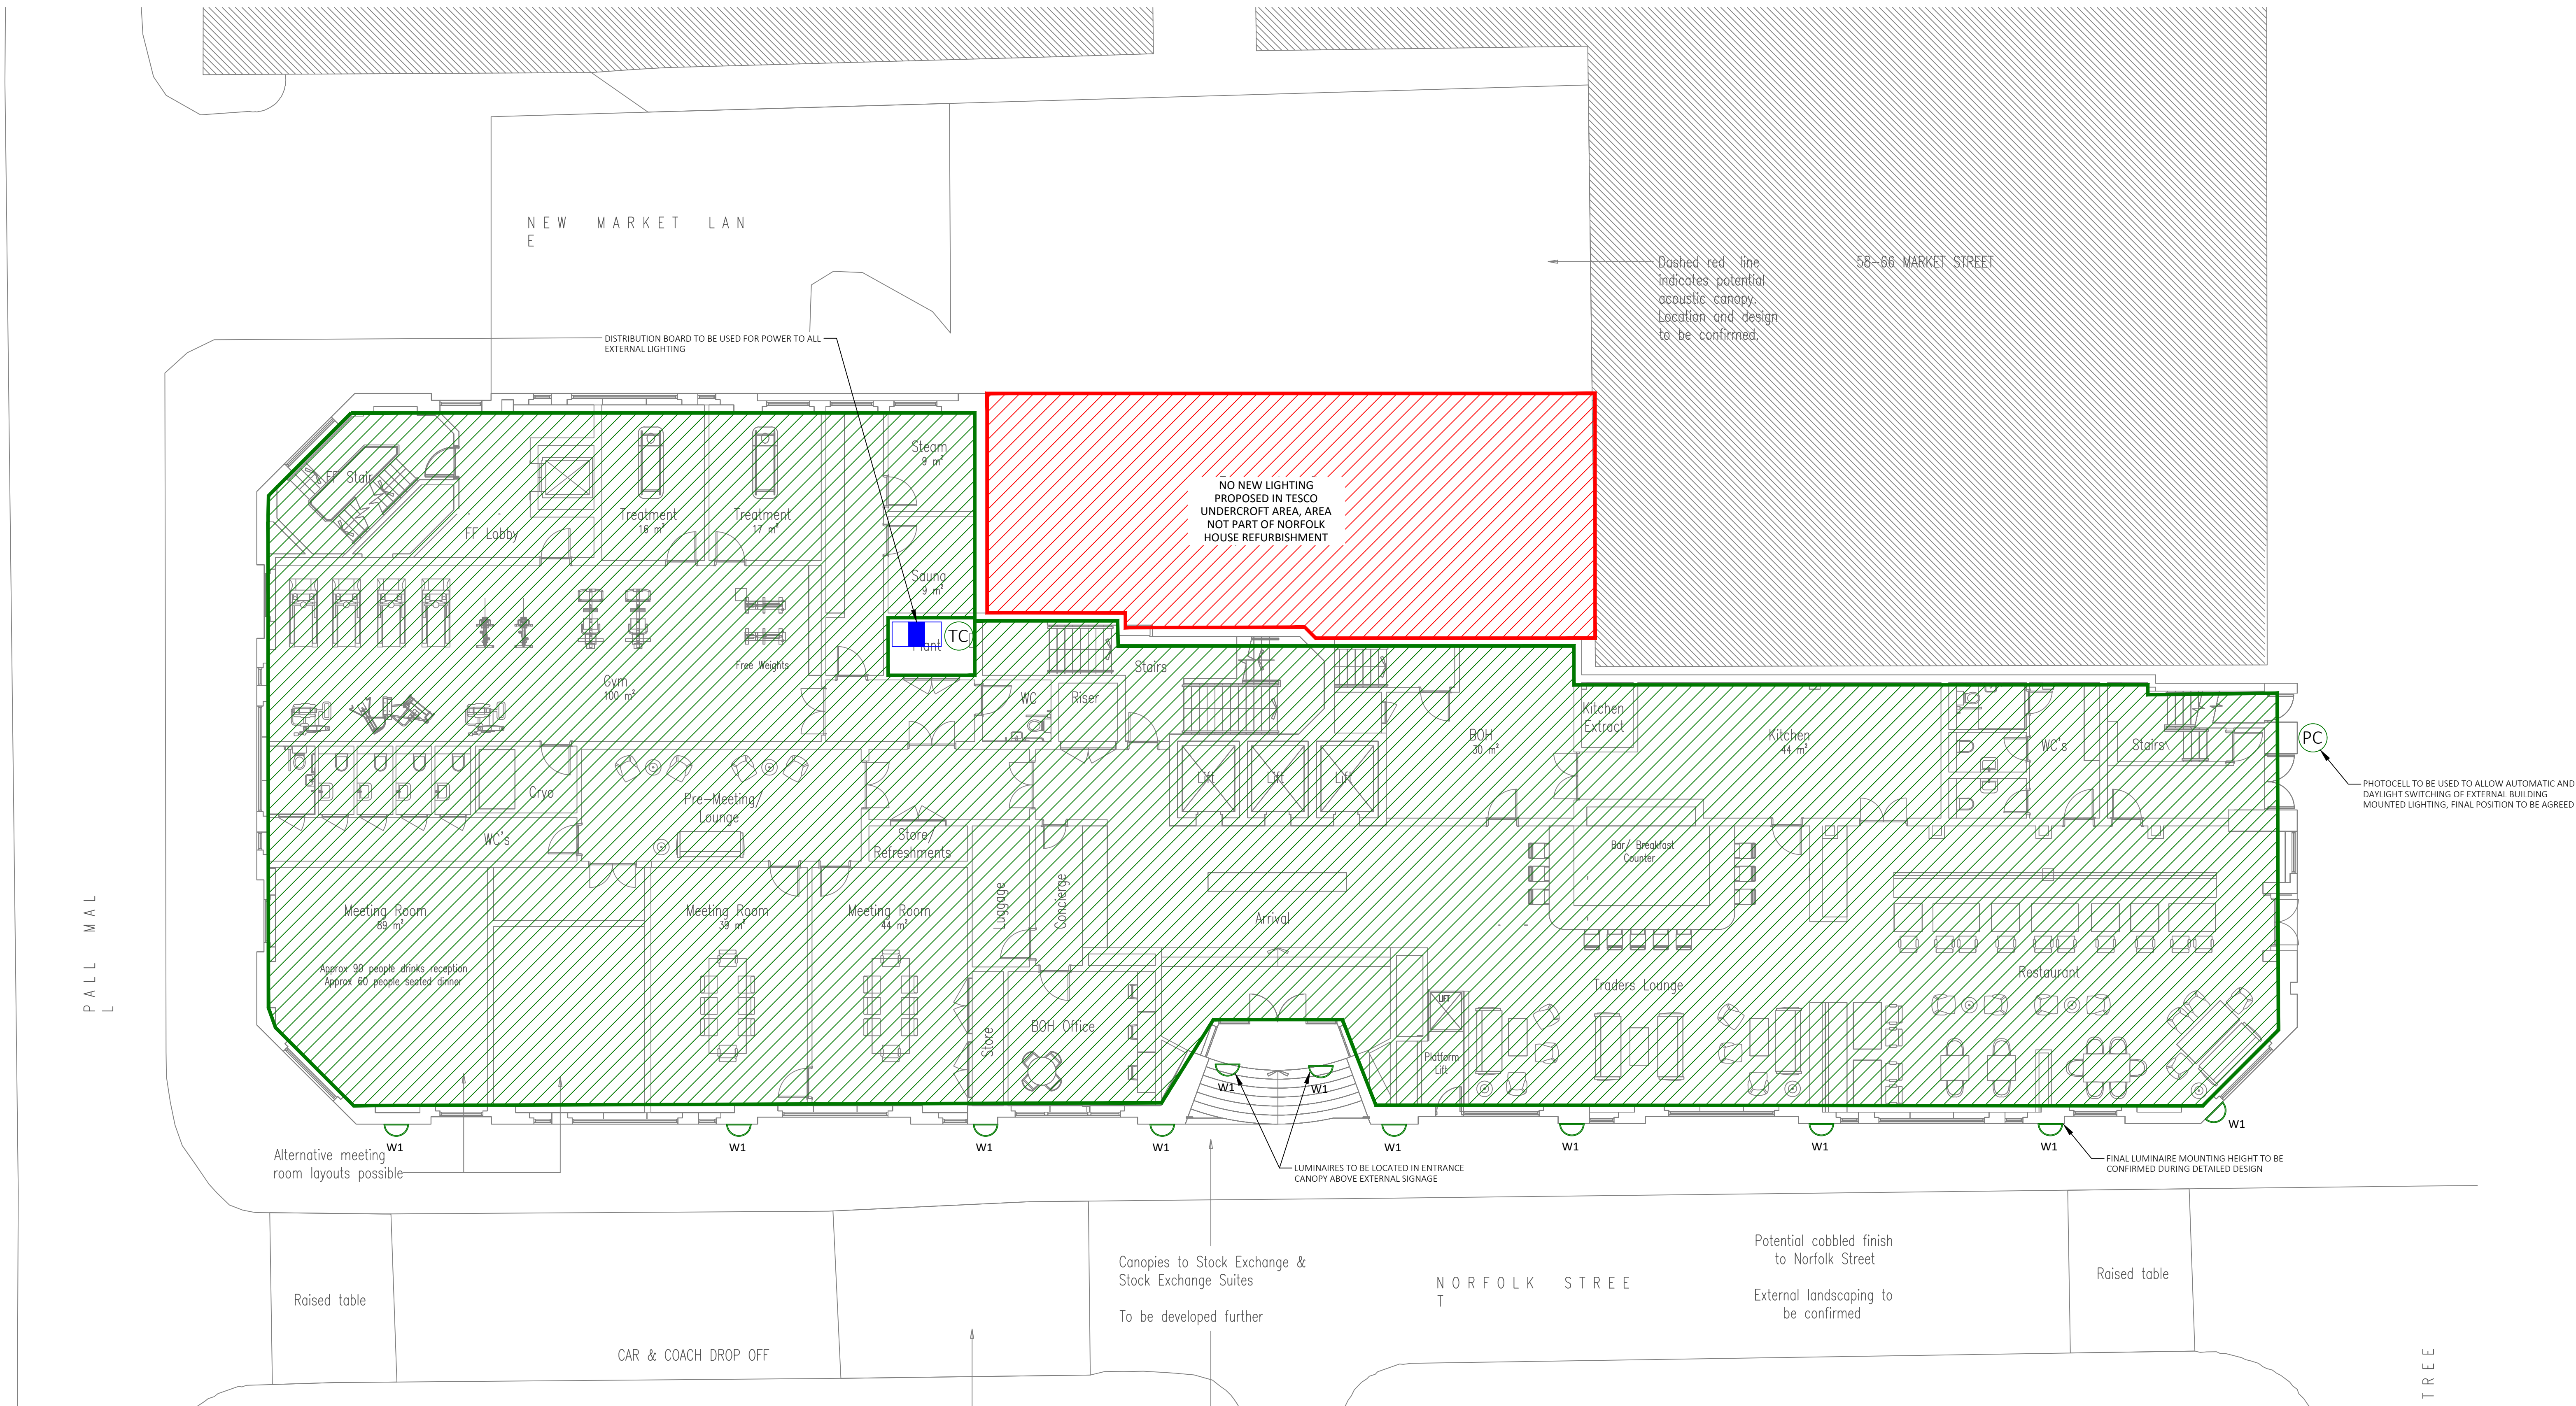

GENERAL NOTES

- DO NOT SCALE FROM THIS DRAWING.
- POSITIONS OF ALL FITTINGS ARE INDICATIVE ONLY.
- THIS DRAWING IS INTENDED TO BE SUBMITTED TO THE RELEVANT PLANNING AUTHORITIES FOR THE REFURBISHMENT OF NORFOLK HOUSE IN MANCHESTER.

SPECIFIC NOTES

- THIS DRAWING SHALL BE READ IN CONJUNCTION WITH ALL OTHER DOCUMENTATION RELEVANT TO THIS PROJECT.
- ALL LUMINAIRES DETAILED ARE SHOWN FOR INDICATIVE PURPOSES ONLY AND ARE TO BE VERIFIED AT SITE LEVEL. DO NOT SCALE FROM THIS DRAWING.
- FINAL LOCATION OF PHOTOCELL TO BE AGREED ON SITE.

LEGEND:

- W1** WALL MOUNTED UPLIGHTING LUMINAIRE, TO COME WITH RISEM AUTOMATIC LIGHTING CONTROLS, SEE IMAGE A & B FOR EXAMPLES.
- DISTRIBUTION BOARD
- TC** TIMECLOCK
- PC** PHOTOCELL (POSITION TO BE AGREED ON SITE), SEE IMAGE C FOR EXAMPLE

IMAGE A:



IMAGE B:



IMAGE C:



PHOTOCELL TO BE USED TO ALLOW AUTOMATIC AND DAYLIGHT SWITCHING OF EXTERNAL BUILDING MOUNTED LIGHTING, FINAL POSITION TO BE AGREED

P01	PRELIMINARY ISSUE	RT	CJ	10.25
Rev	Description	DRN	CHK	Date
Architect				

EPF ARCHITECTS

Client



S2 - FOR INFORMATION



West Tower - Brook Street - Liverpool - L3 9PJ
☎ +44 (0)151 363 7627 ✉ enquiries@futureserv.co.uk 🌐 www.futureserv.co.uk

Project Title

NORFOLK HOUSE

Drawing Title

PROPOSED EXTERNAL LIGHTING LAYOUT

Project No L6614 Suitability S2

Drawn & Checked by RT

Reviewed by CJ

Date OCT 2025

Scale 1:100 @ A0

Drawing No L6614-FUT-XX-ZZ-DR-E-63-001 Rev. P01