


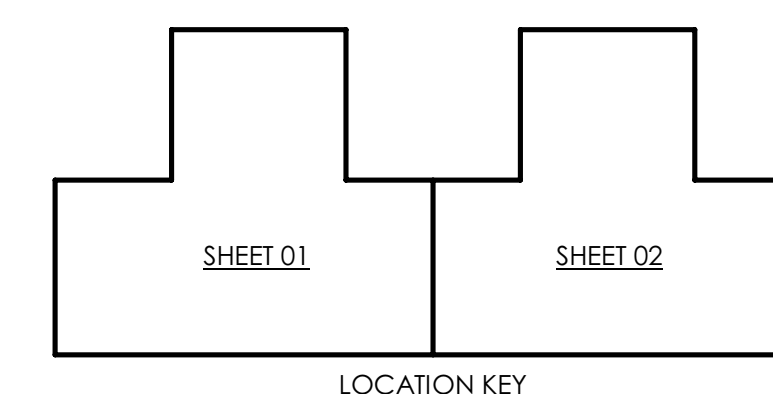

C01	13/02/25	CONSTRUCTION ISSUE - KIER	LB	NH	PC
C02	22/08/24	VENTILATION UPDATED TO SUIT LATEST MODEL	LB	NH	PC
P02	08/07/24	PRELIMINARY ISSUE	LB	NH	PC
P01	01/07/24	PRELIMINARY ISSUE	LB	NH	PC
Rev	Date	Description	Dm	Chk	App
Drawing Status: CONSTRUCTION					
					
Drawn: L. BRIFFA Chkd: A. AMES App'd: P. CHAMBERS A0					
Date: MAY 2024 Scale: As indicated Revit Version:					
Client: MANCHESTER CITY COUNCIL					
Project: VARLEY STREET, STAN SCHOOL, MANCHESTER UPRN: 0000077240467					
Drawing Title: VENTILATION LAYOUT ROOM: SHEET 1 OF 2					
Drawing No: VAR-VES-ZZ-RF-DR-M-5701					
Project No: _____ Date: _____ (mm) (dd) (yy) Rev: _____					