


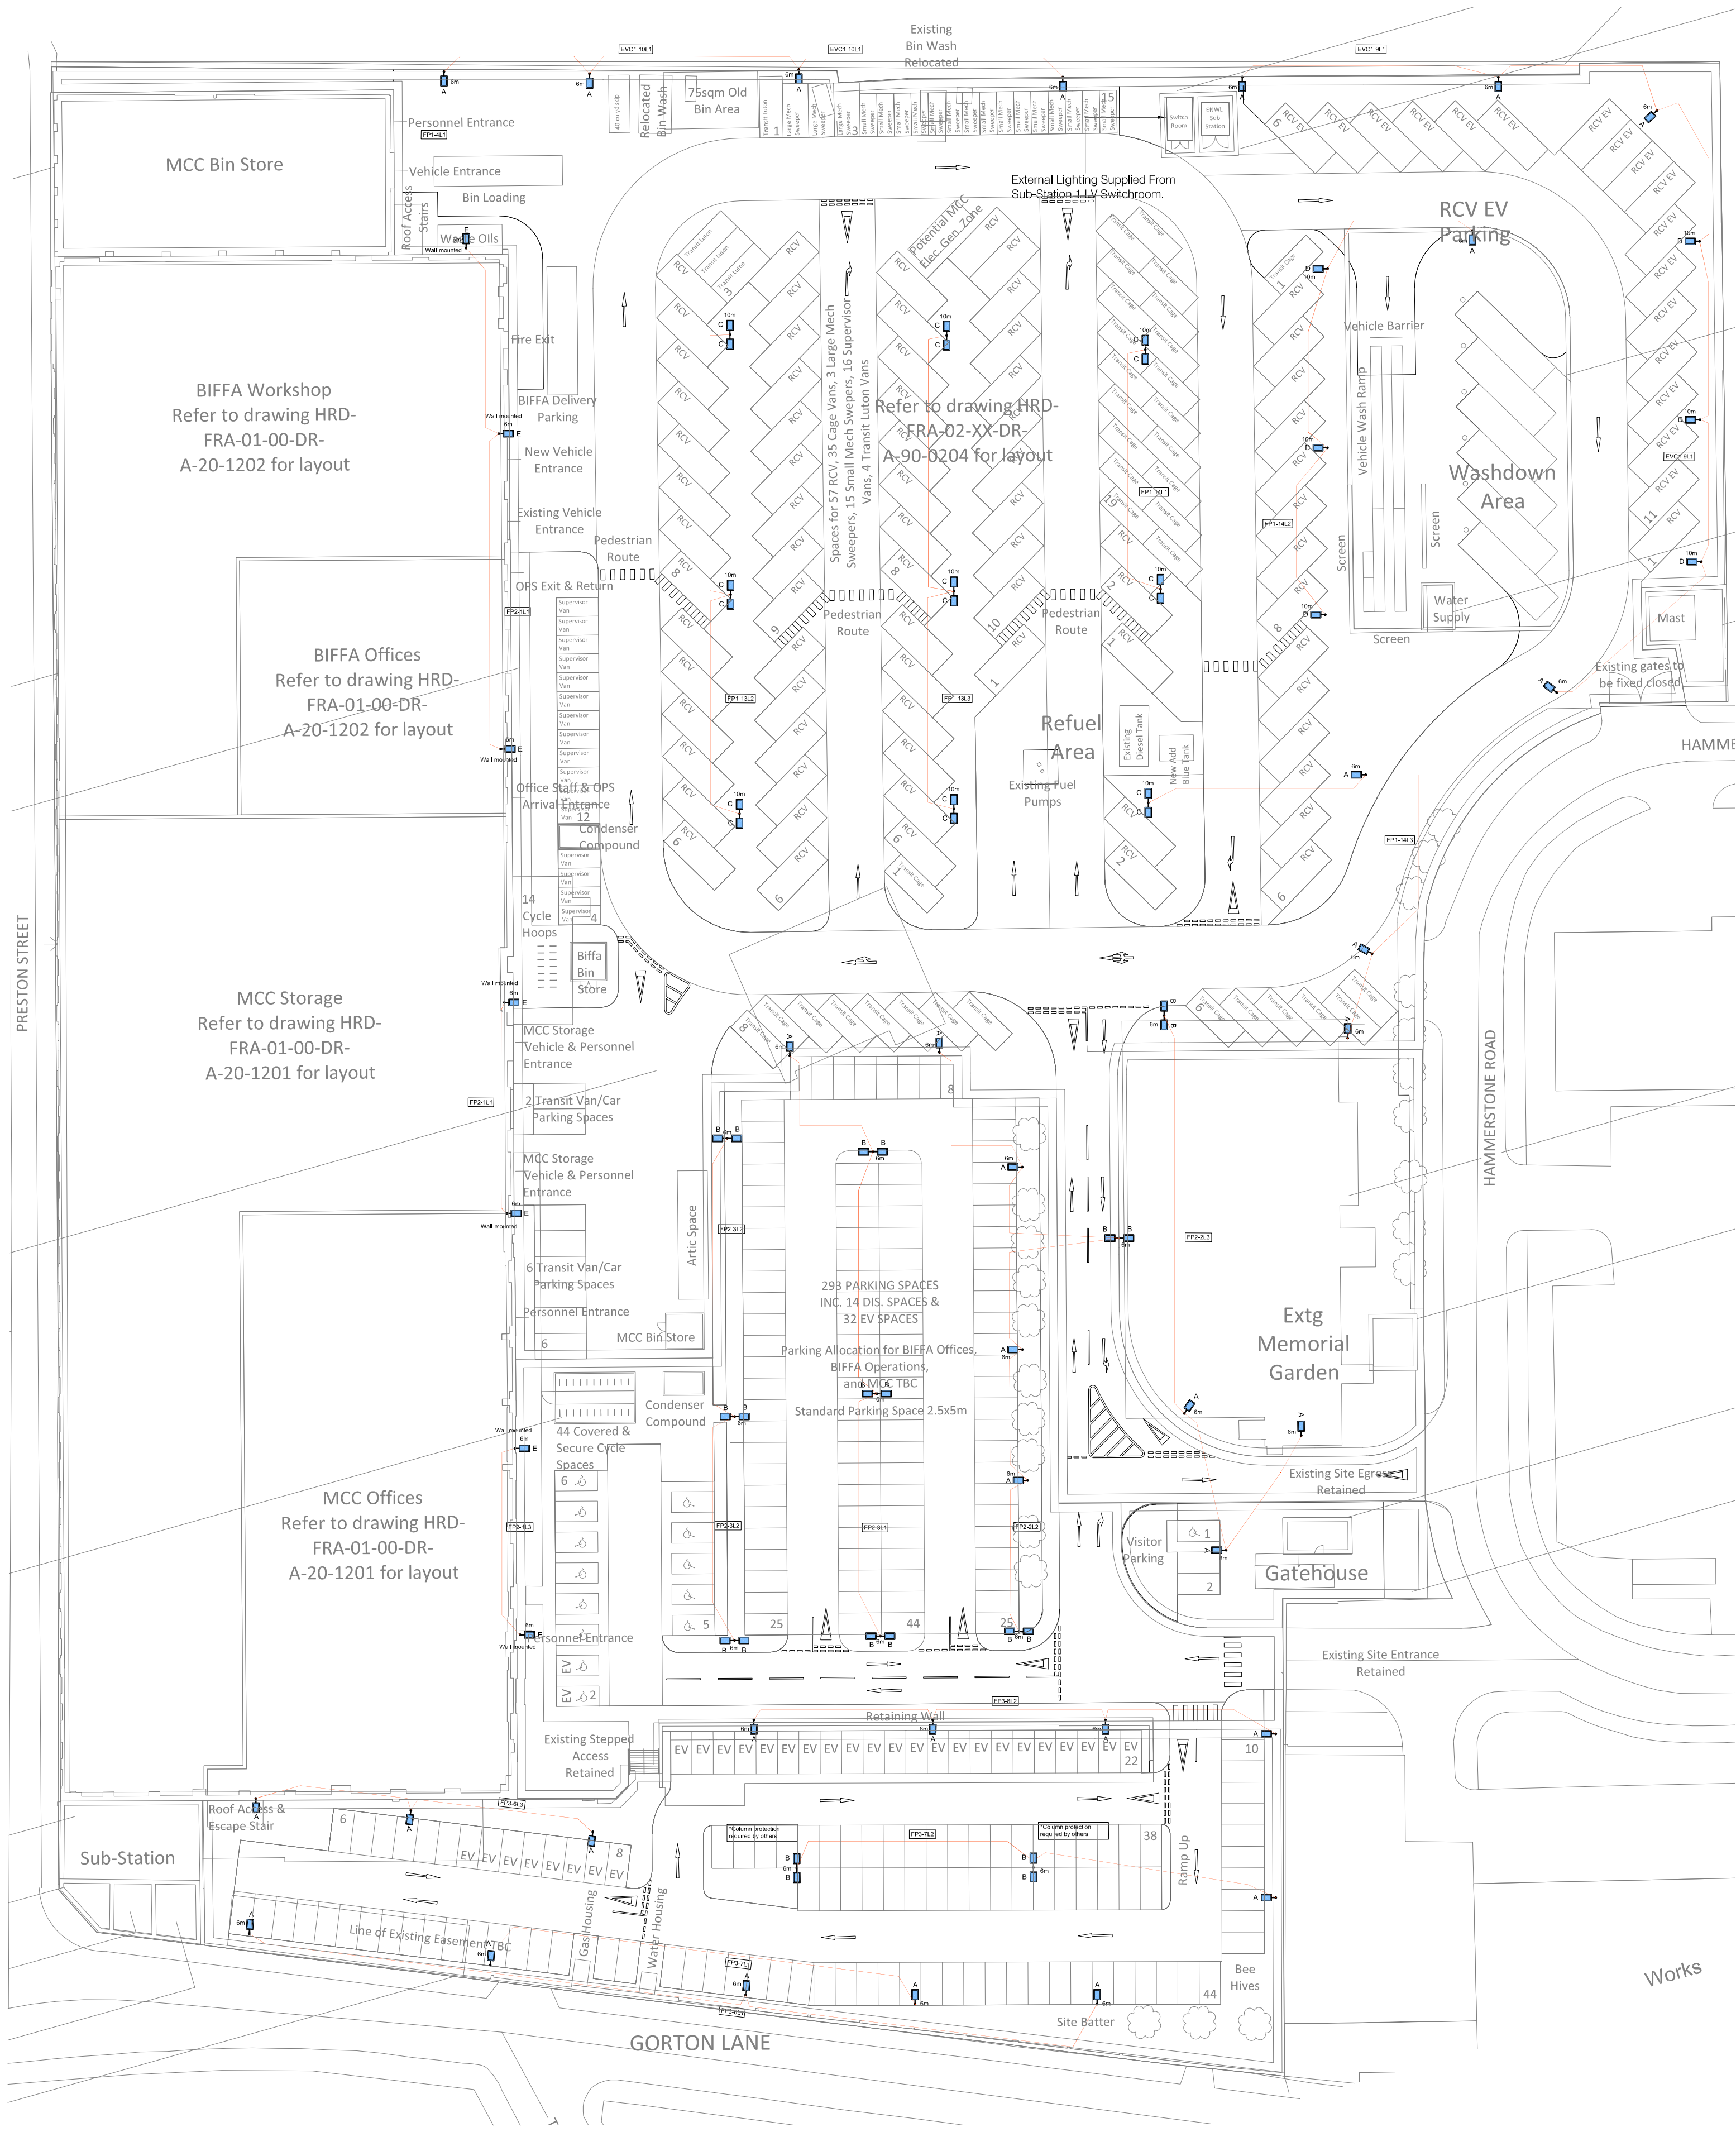

External Lighting Layout
Scale 1:500

- Legend
- A 1x100W LED post top lantern (IP66)
Single Head 6m column. (Sirocco Midi)
 - B 1x100W LED side entry luminaire (IP66)
Double head 6m column. (Sirocco Midi)
 - C 1x100W LED side entry luminaire (IP66)
Double head 10m column. (Sirocco Midi)
 - D 1x128W LED post top lantern (IP66)
Single Head 10m column. (Sirocco Midi)
 - E 1x100W LED side entry lantern (IP66)
Single Head 6m wall mount. (Sirocco Midi)
- The external lighting installation shall be controlled by a photocell and time clock arrangement. Photocell control shall ensure external lighting switched off during daylight hours - located in feeder pillars.
 - A manual override switch shall be provided to allow the lighting to be turned on/off. - located in feeder pillars.



SIROCCO MIDI



BUILDING SERVICES ENGINEERS
LIVERPOOL

ALL RIGHTS RESERVED © COPYRIGHT A&B ENGINEERING (M.S.D) LTD
& A&B ENGINEERING (E.S.D) LTD.

REVISION	ITEM REVISED	DATE
P01	Preliminary Issue	03/09/2021
P02	Revised Infile with comments	08/10/2021
P03	Revised Infile with comments	31/05/2022
P04	Revised Infile with landscape change	18/08/2022
C01	Construction Issue	23/06/2023
C02	Northern Carpark Updated Infile with site workshop	02/10/2023
C03	Updated Infile with landscape plan and ongoing client instructions	02/12/2024
C04	Construction Record	15/09/2025

NOTES:

CONSTRUCTION RECORD

CLIENT		
Manchester City Council		
ARCHITECT		
Fletcher Rae		
PROJECT		
Hammerstone Road Depot Refurbishment		
TITLE		
Electrical Service - External Lighting Layout		
STATUS		PURPOSE OF ISSUE
PD		Construction
DRAWN BY	CHECKED	DATE
J.H	M.B	17/05/2021
SCALE @A1		A&B PROJECT No
1 : 500		8834
FILE DRAWING NUMBER		REV
HRD-ABE-00-00-DR-E-7004		C04



Holly Terrace • 9-17 Derby Lane
Old Swan • Liverpool • L13 6QA
tel: 0151 228 4661 • fax: 0151 220 4206
email: info@abeng.co.uk • website:
www.abeng.co.uk