


SYMBOL	DESCRIPTION
P1	CP ELECTRONICS EBDSPR-PRM LIGHTING DETECTOR
P2	CP ELECTRONICS EBDSPR-AT-PRM LIGHTING DETECTOR
P3	CP ELECTRONICS EBR-CPR-DALI LIGHTING DETECTOR
M3	CP ELECTRONICS MM3SA-PRM LIGHTING MICROWAVE DETECTOR
AC	CP ELECTRONICS HM-AC AREA CONTROLLER
44	CP ELECTRONICS EBR-HB-DAU564
SP1	CP ELECTRONICS SCENE SETTING PANEL
SC1	CP ELECTRONICS SCENE TOUCH SCREEN PANEL
SW1	CP ELECTRONICS 2 BUTTON SWITCH PANEL
DM1	CP ELECTRONICS DMX CONTROL PANEL
S	CP ELECTRONICS LIGHTING PIR DETECTOR

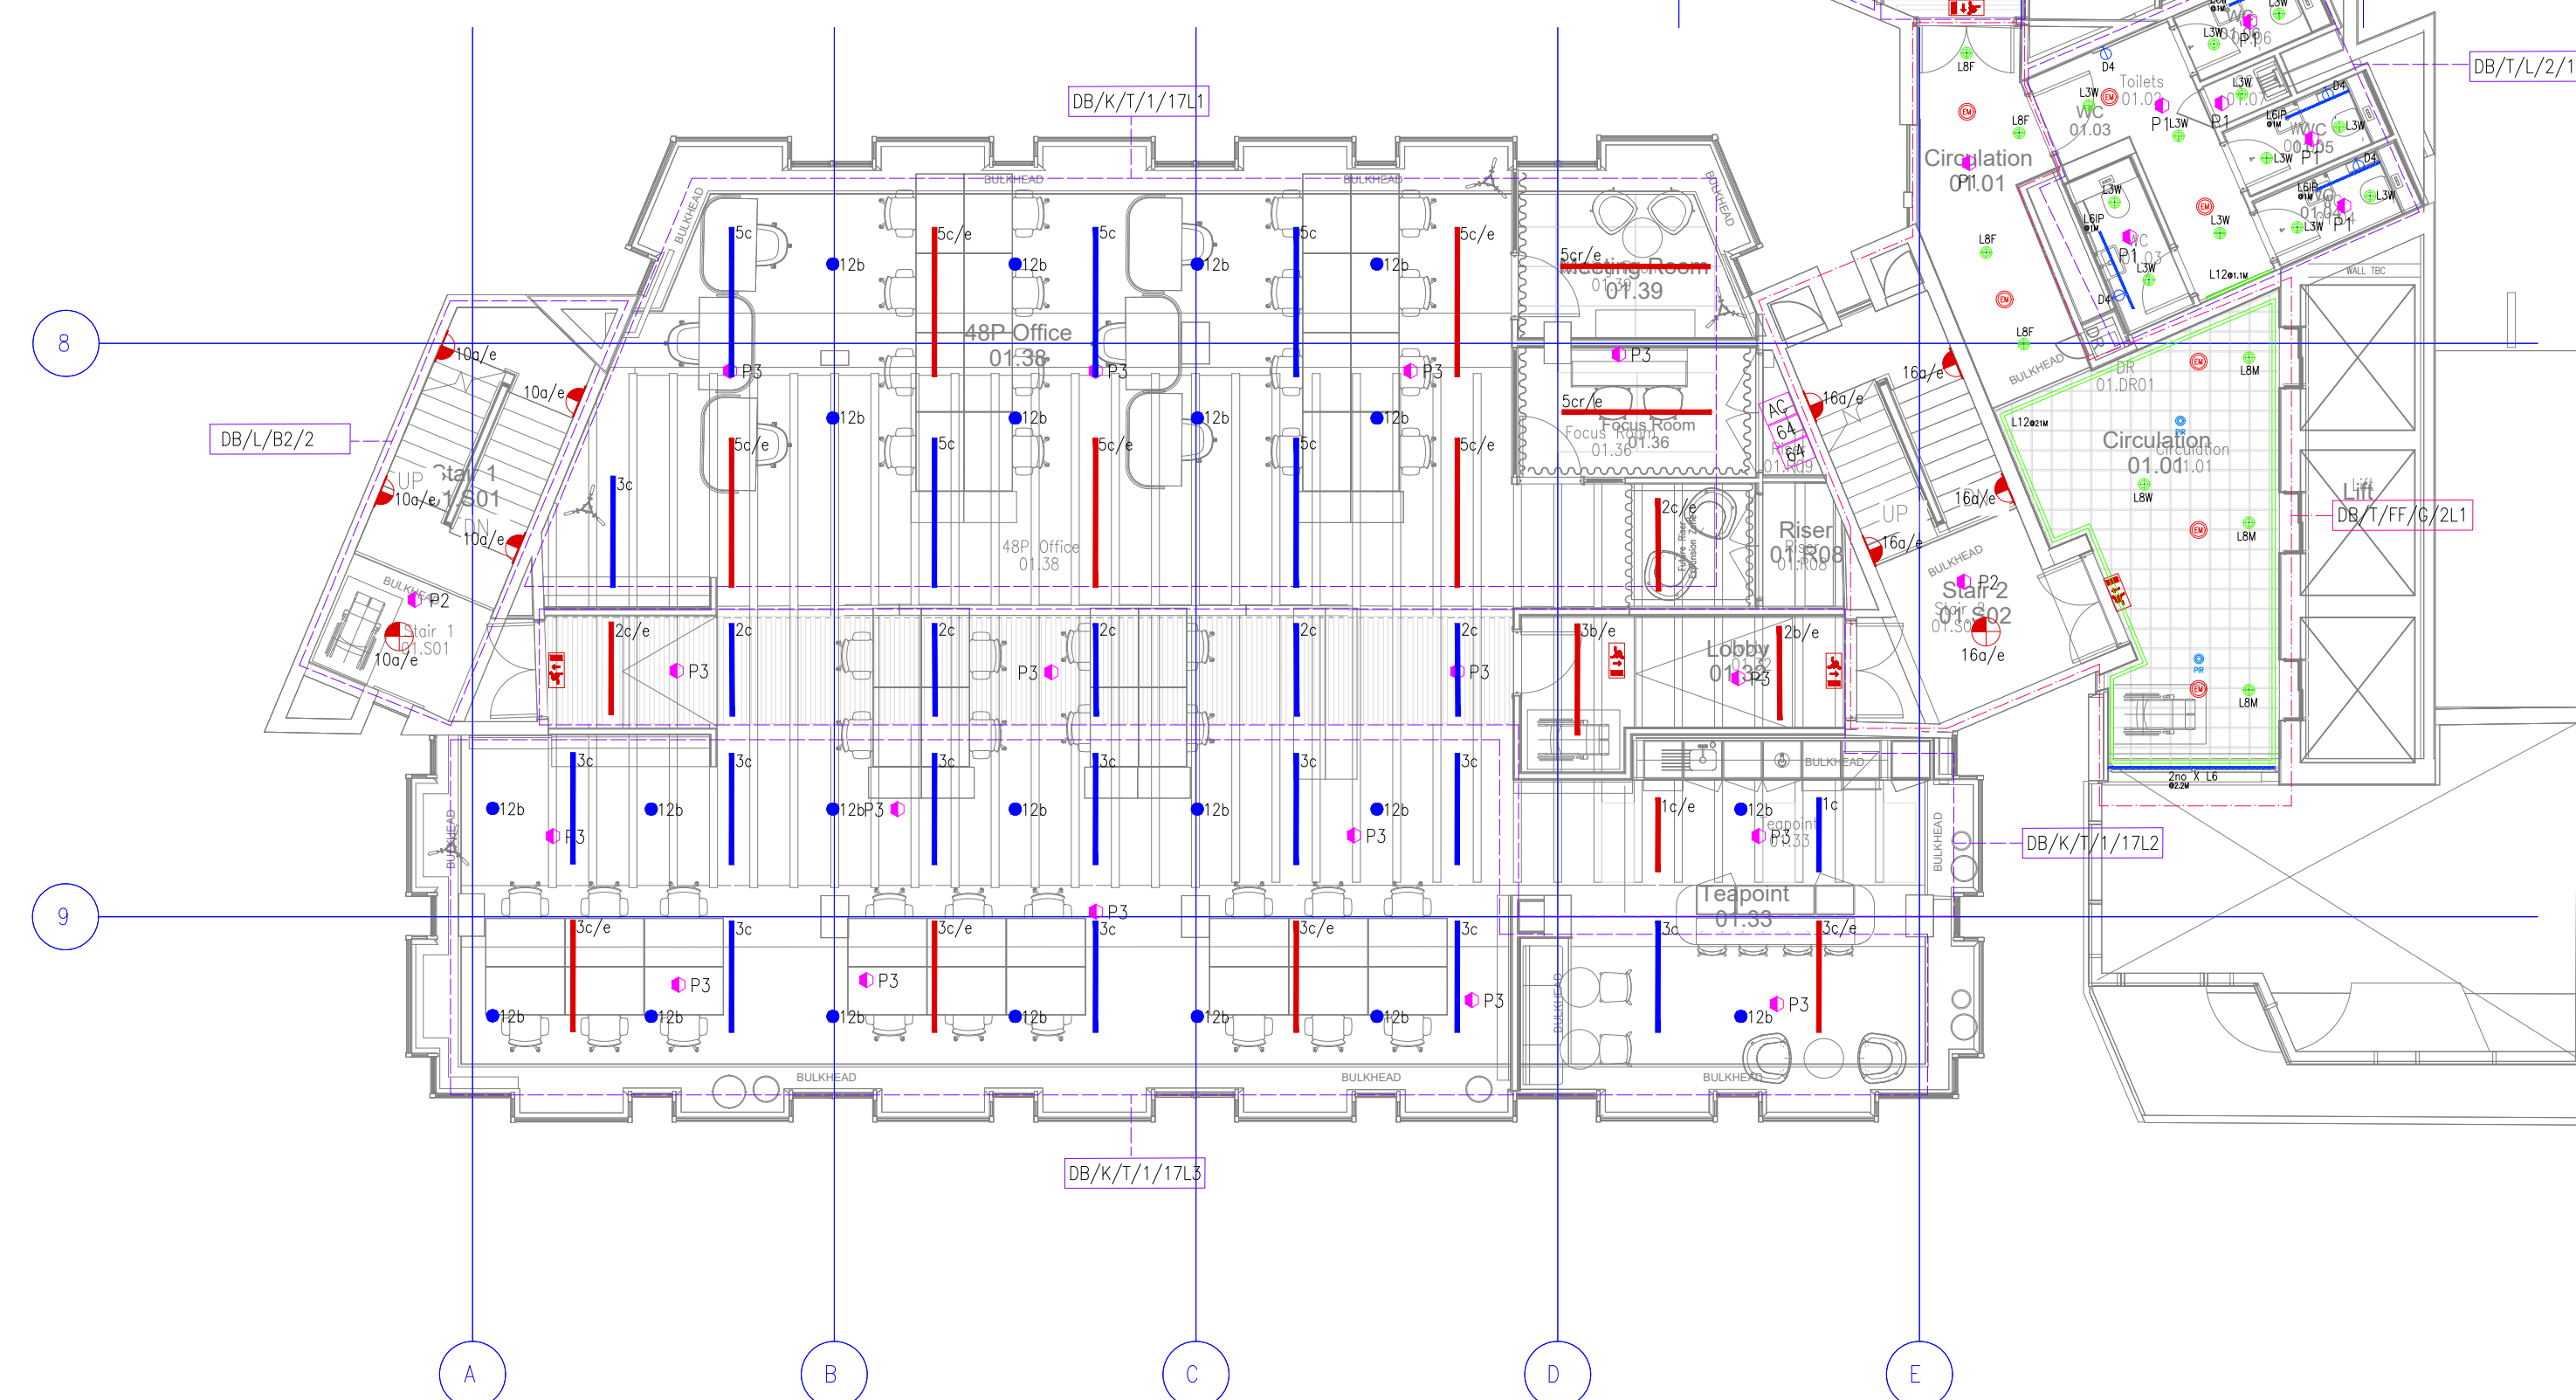

	Light fitting description	Reference	manufacturer
1	D1 - A - Decorative pendant	1510	Vibra LSE lighting
2	D1 - B - Decorative pendant	1530	Vibra LSE lighting
3	D1 - C - Decorative pendant	1560	Vibra LSE lighting
4	D1 - D - Decorative pendant	1570	Vibra LSE lighting
5	D2 - Decorative pendant	5940	Vibra LSE lighting
6	D3 - Decorative pendant	Pendant Aluminium	Photic
7	D4A - Decorative wall light	MILES 9.0	XAL
8	D4B - Decorative wall light	MILES 9.0	XAL
9	D5 - Decorative pendant	Suspended Bespoke pendant with 4no glass opal globe lamps	Northern Lights
10	D6 - Decorative pendant	Model 2065 Black shade opal	Astep LSE lighting
11	D7 - Decorative wall light	Karl Johan wall lamp white opal glass	New Works LSE lighting
12	D8 - Decorative Picture light	Bespoke decorative picture light	Northern lights
13	D9 - Desk Mounted task light	VP9 mini portable table lamp	Nest lighting
14	D10 - free standing Floor Lamp	Theira Floor lamp	Manet LSE lighting
15	D12 A D12 B - Changing room ceiling mounted feature light	Bespoke 1200mm and 1500mm	Northern lights
16	D13 - Meeting room chandeliers 1200mm	BOUGHTFP	Northern lights
17	D14 - desk mounted task light	AI Tripod table lamp	Nest lighting
18	D15 - free standing Floor Lamp	TMD	Santa and Cole LSE lighting
19	X2 - external recessed canopy downlighter with anti glare louvre	Juna	LDL
20	X3 - Flexible LSD profile with Homogenous lighting effect	Continuity T - made to measure	Trykla
21	X5 - Ground fixed LED bollard	Shelby	LDL
22	X7 - Column mounted down lighter	LD10235	Light Graphix
23	X8 - Surface mounted external projector	Maci	LDL
24	X9 - Surface mounted LED downlighter	LD95	Light Graphix
25	X10 - surface mounted downlighter	LD10235	Light Graphix
26	X11 - Surface mounted down lighter	LD10235	Light Graphix
27	X12 - Ground fixed LED bollard	Rein Pro	FLOS
28	EM1 - Non Maintained emergency LED downlighter	LED3/AIT	LDL
29	EM1 - Emergency Bulkhead Surface	LED3 Surface	LDL
30	EM2 - Final Exit non maintained LED downlighter	EX2-OP13	Aricco
31	EM3 - Non Maintained emergency LED downlighter	LED3 recessed	LDL

	Reference	Light fitting description	Product Code	Manufacturer
1	1A	Linear LED	MIL/S/11/OP/1279/100/4	LDL
2	1C	Linear LED	MIL/S/11/OP/1890/150/4	LDL
3	1g	Linear LED	MIL/S/11/OP/3100/250/4	LDL
4	2a	Linear LED	MIL/S/14/OP/1800/100/4	LDL
5	2c	Linear LED	MIL/S/14/OP/2600/150/4	LDL
6	3a	Linear LED	MIL/S/16/OP/2020/100/4	LDL
7	3c	Linear LED	MIL/S/16/OP/3010/150/4	LDL
8	3d	Linear LED	MIL/S/16/OP/3600/175/4	LDL
9	4a	Linear LED	MIL/S/19/OP/2450/100/4	LDL
10	4b	Linear LED	MIL/S/19/OP/3560/150/4	LDL
11	5a	Linear LED	MIL/S/22/OP/2540/100/4	LDL
12	5c	Linear LED	MIL/S/22/OP/3780/150/4	LDL
13	5d	Linear LED	MIL/S/22/OP/4400/175/4	LDL
14	8a	Linear LED	MIL/S/30/OP/3820/100/4	LDL
15	9a	Linear LED	MIL/S/33/OP/4040/100/4	LDL
16	9c	Linear LED	MIL/S/33/OP/6020/150/4	LDL
17	10a	Surface Circular Wall Light	22MP/3060/4	LDL
18	12a	Surface LED Can	DOM/W/1260/4	LDL
19	12b	Surface LED Can	DOM/W/945/4	LDL
20	13a	Recessed LED Downlight	DAR/800/4	LDL
21	13b	Recessed LED Downlight	DAR/625/4	LDL
22	14a	Recessed LED EM Downlight	LED/CIR/BLK/OA	LDL
23	16a	Surface LED Circular Wall Light	NOMA/4/3820/4	LDL

P06	AMENDED TO ARCHITECT COMMENTS	JA	CM	20/04/2016
P05	LIGHTING SCHEDULES AMENDED	GJ	PC	17/04/2016
P04	LIGHTING SCHEDULES ADDED	KJ	PC	17/04/2016
P03	LUMINAIRE REFERENCES AMENDED	KJ	PC	16/04/2016
P02	PRELIMINARY CIRCUIT DETAILS ADDED	KJ	PC	16/04/2016
P01	FIRST ISSUE	KJ	PC	16/04/2016
Rev.	Description			By
01	AS2021 Level 01 Ceiling Plan XREF CLEANED - P12			01/04/2016

Drawing Status: PRELIMINARY



Unit 6, North Starlets Business Park,
Innovation Way, Salford, S7 5SE
Email : info@carterelectrical.co.uk
Telephone: 01753 822200
www.carterelectrical.co.uk






Project

PALL MALL MANCHESTER

Phase 1

FIRST FLOOR LIGHTING & EMERGENCY LIGHTING LAYOUT

Client: SHEPPARD ROBSON

Contract: RAMBOLL

Designer: PC

Date: 02.12.2012

Project Manager: CB

Project Number: CES561

Iss: PG

Scale: 1:100

Drawn: MD

Rev: 0/0

Copyright, Carter Electrical Services LTD
Contractors are to check all dimensions on site and refer any discrepancies to Carter Electrical immediately