

Notes

Do not scale from this drawing.

All dimensions are to be checked prior to construction and any discrepancies are to be identified to the Architect.


Copyright reserved.

Small Power Legend

PC	Fused Spur - Hand Dryer/Hairdryer
	Single power socket (13A)
	Single power socket (13A) - With USB
	Double power socket (13A)
	Double power socket (13A) - With USB
PC	Computer Point: 4 Data, 6 Power sockets
PP	Printer Point: 2 Data, 2 Power sockets
CFE	Coffee Point
	Access control
	Door release
	Info Screen

Notes / Disclaimers:

Drawings to be coordinated and reviewed by M&E specialist.

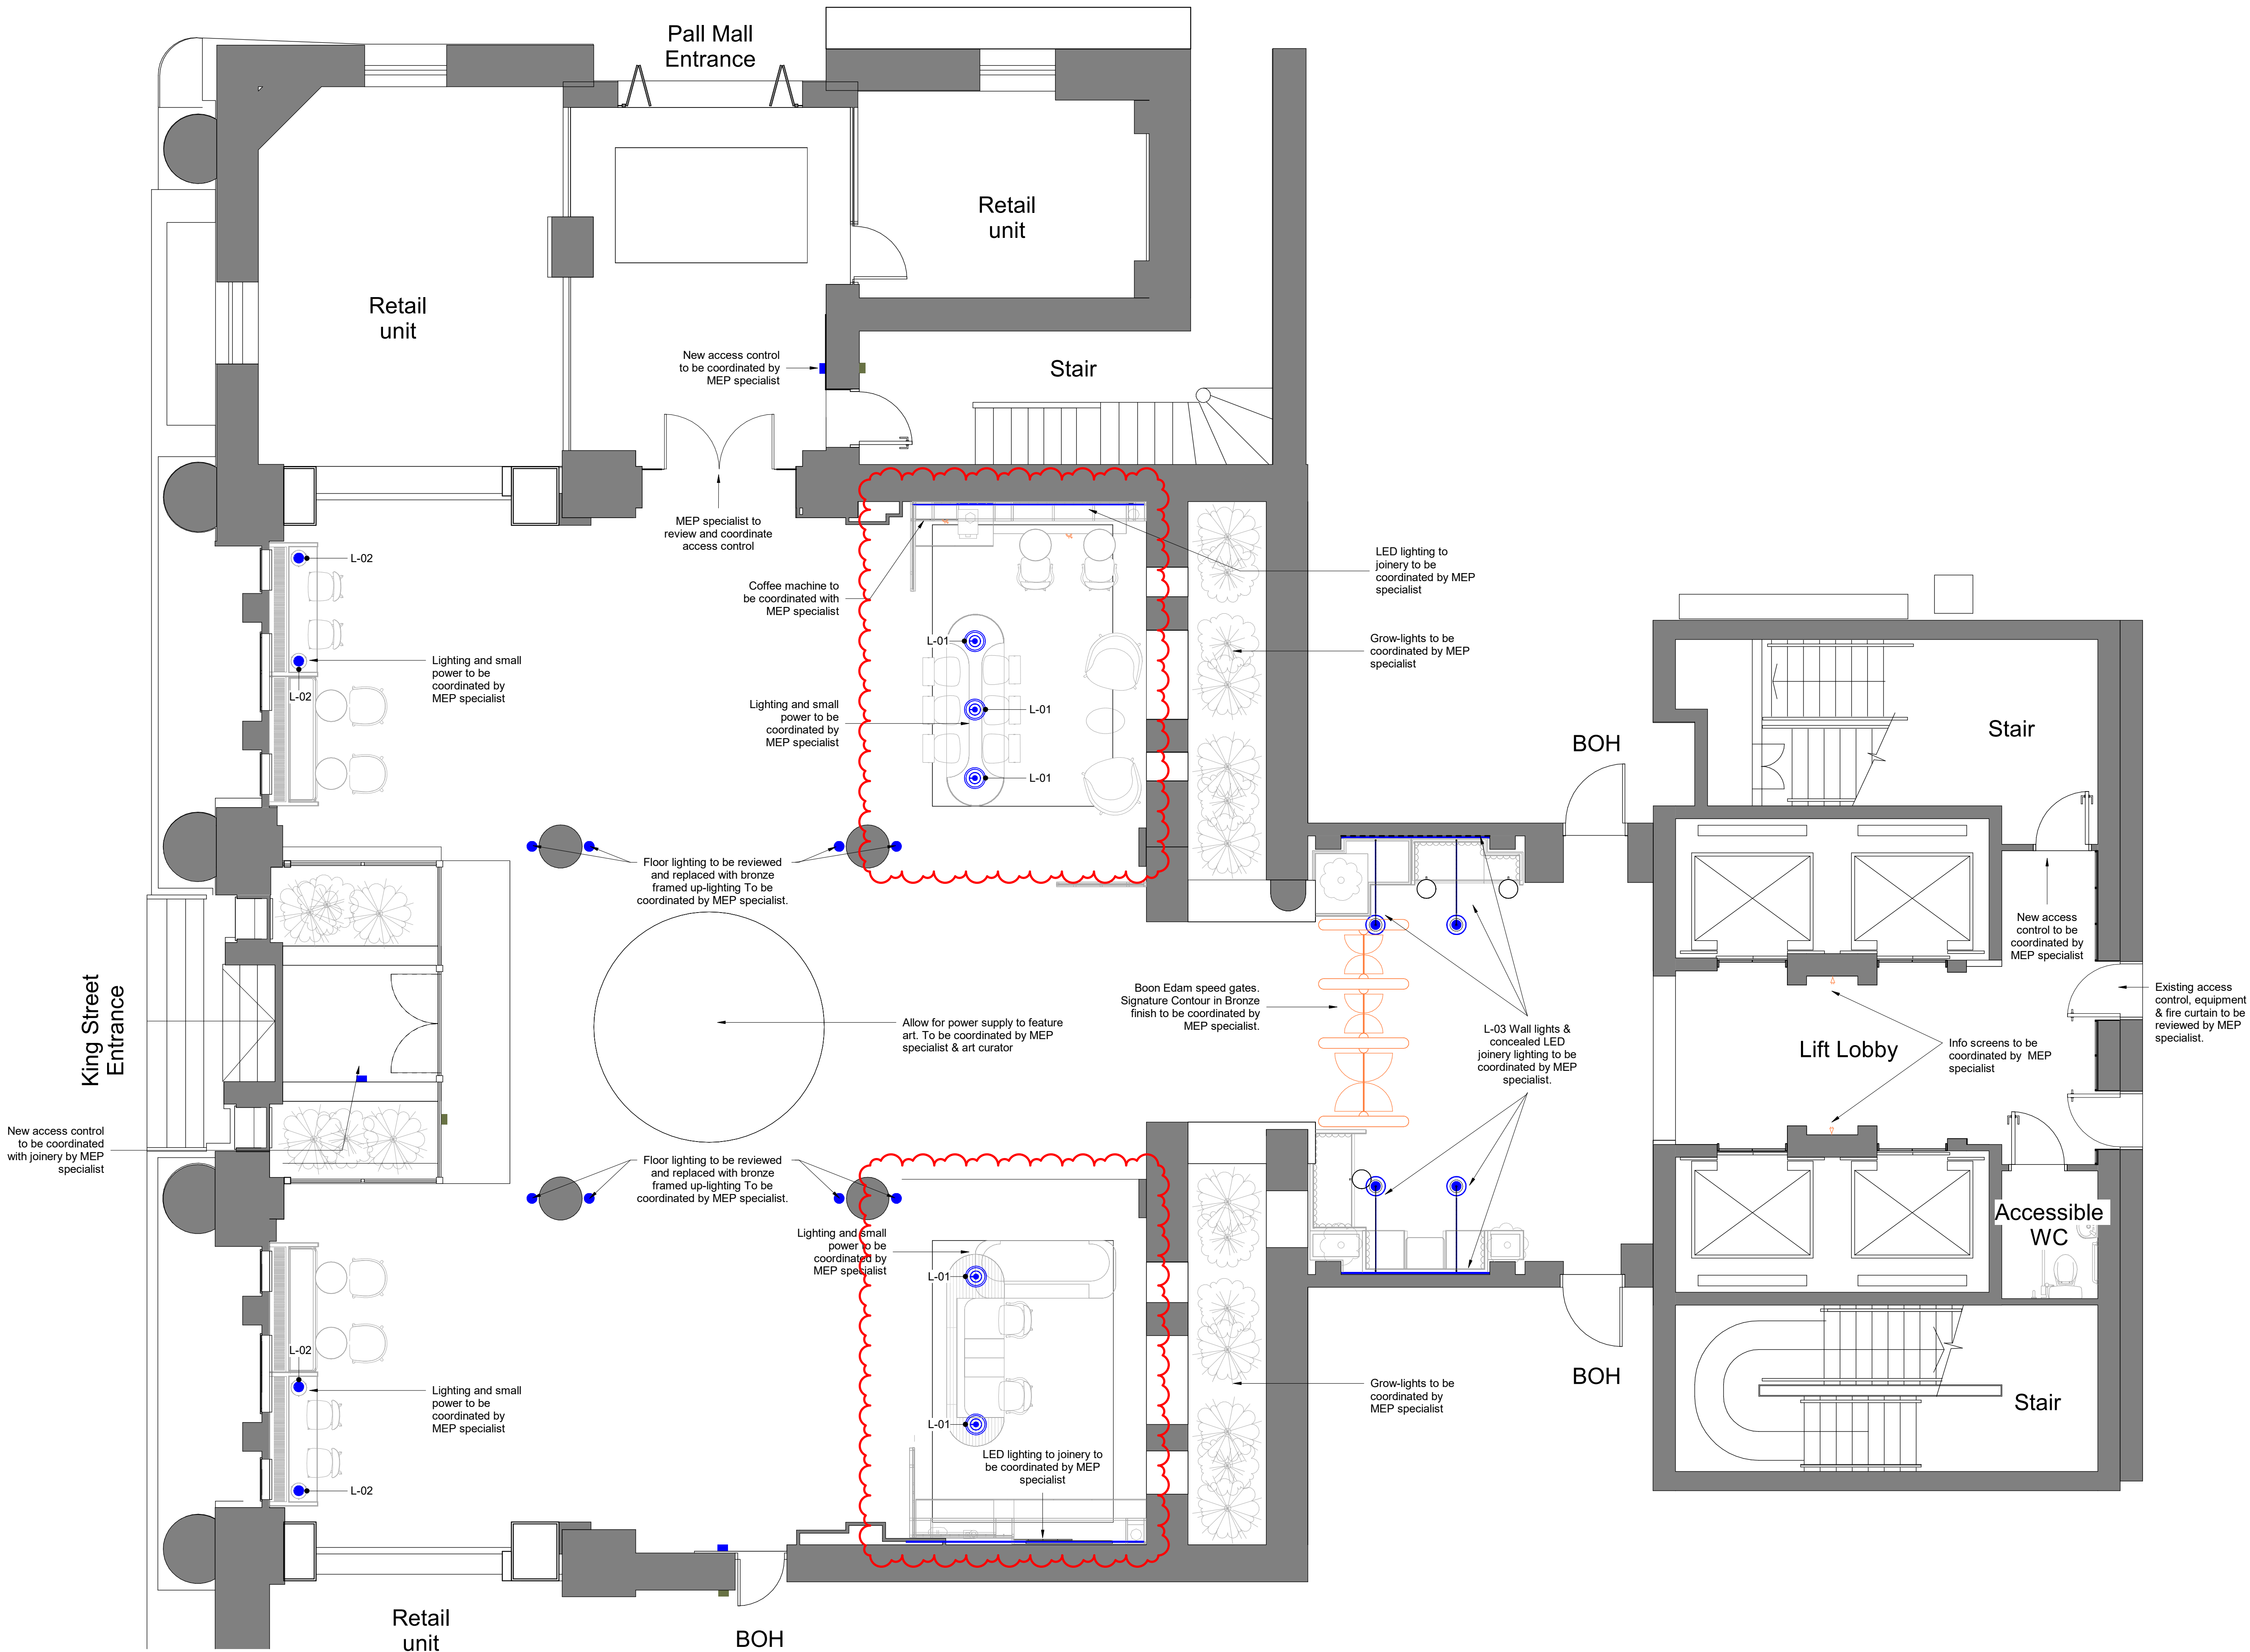

P0228/08/25Extent of inset tile reduced to existing inset carpet and notes updatedJH

P0102/05/25For information

Revisions

PurposeFor InformationStatus CodeS2

Client

Priory Manchester Ltd

Project

82 King Street Manchester

Title

Ground Floor Schematic Small Power Plan

Scale1 : 50

SizeA1

Date02/05/25

DrawnJK

CheckedNS

3DReid

www.3DReid.com

Architecture Interiors Masterplanning

Drawing No.

250009-3DR-ZZ-00-DR-I-61000

Rev.

P02

Time Stamp: 28/08/2025 16:55:30