


Do not scale from this drawing. All dimensions to be checked on site prior to manufacture and construction. This drawing is the property of Harrison Ince Holdings Limited and should not be reproduced without permission.
All discrepancies to be brought to the attention of the architect immediately.
This drawing is to be read in conjunction with the specification / bill of quantities and related drawings.

REVISIONS


FIRST ISSUE

04.08.2025 MSM

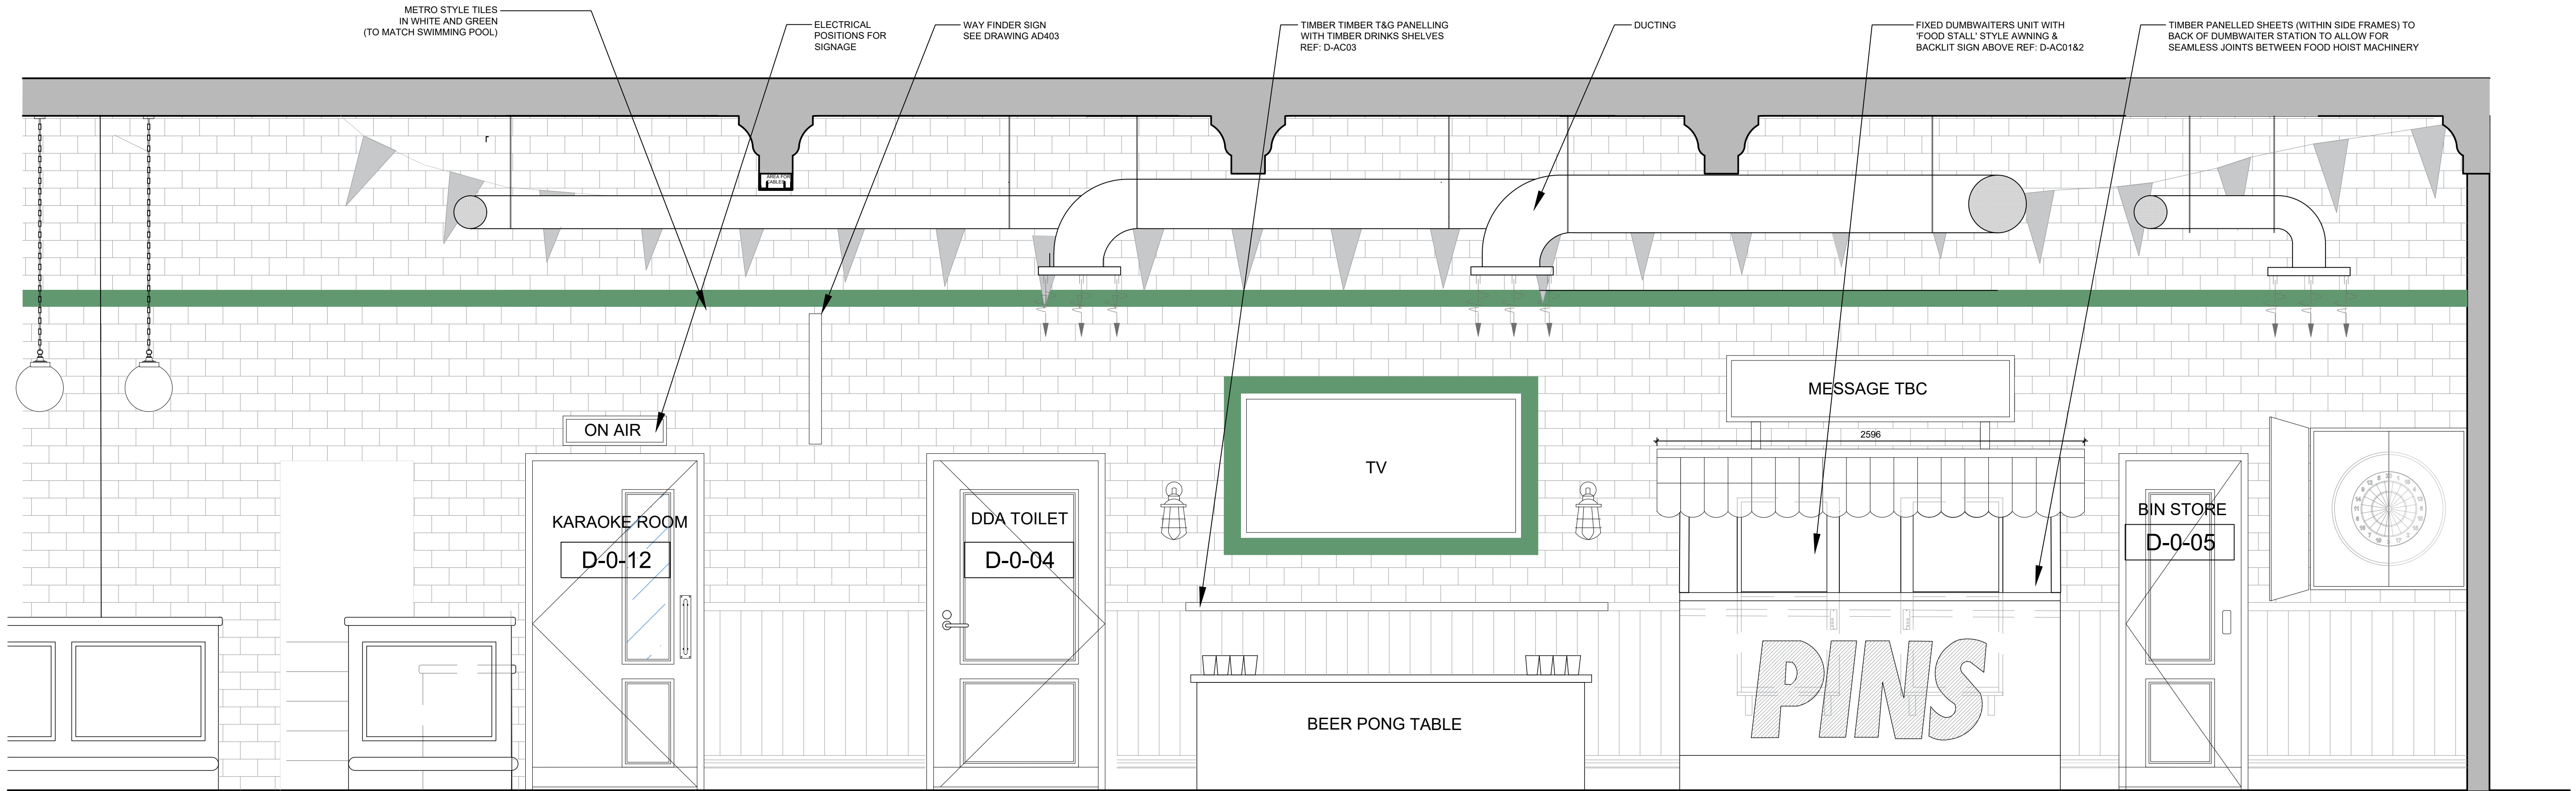

PROPOSED SECTION AJ : M&E/COFFERS SECTION

1:20

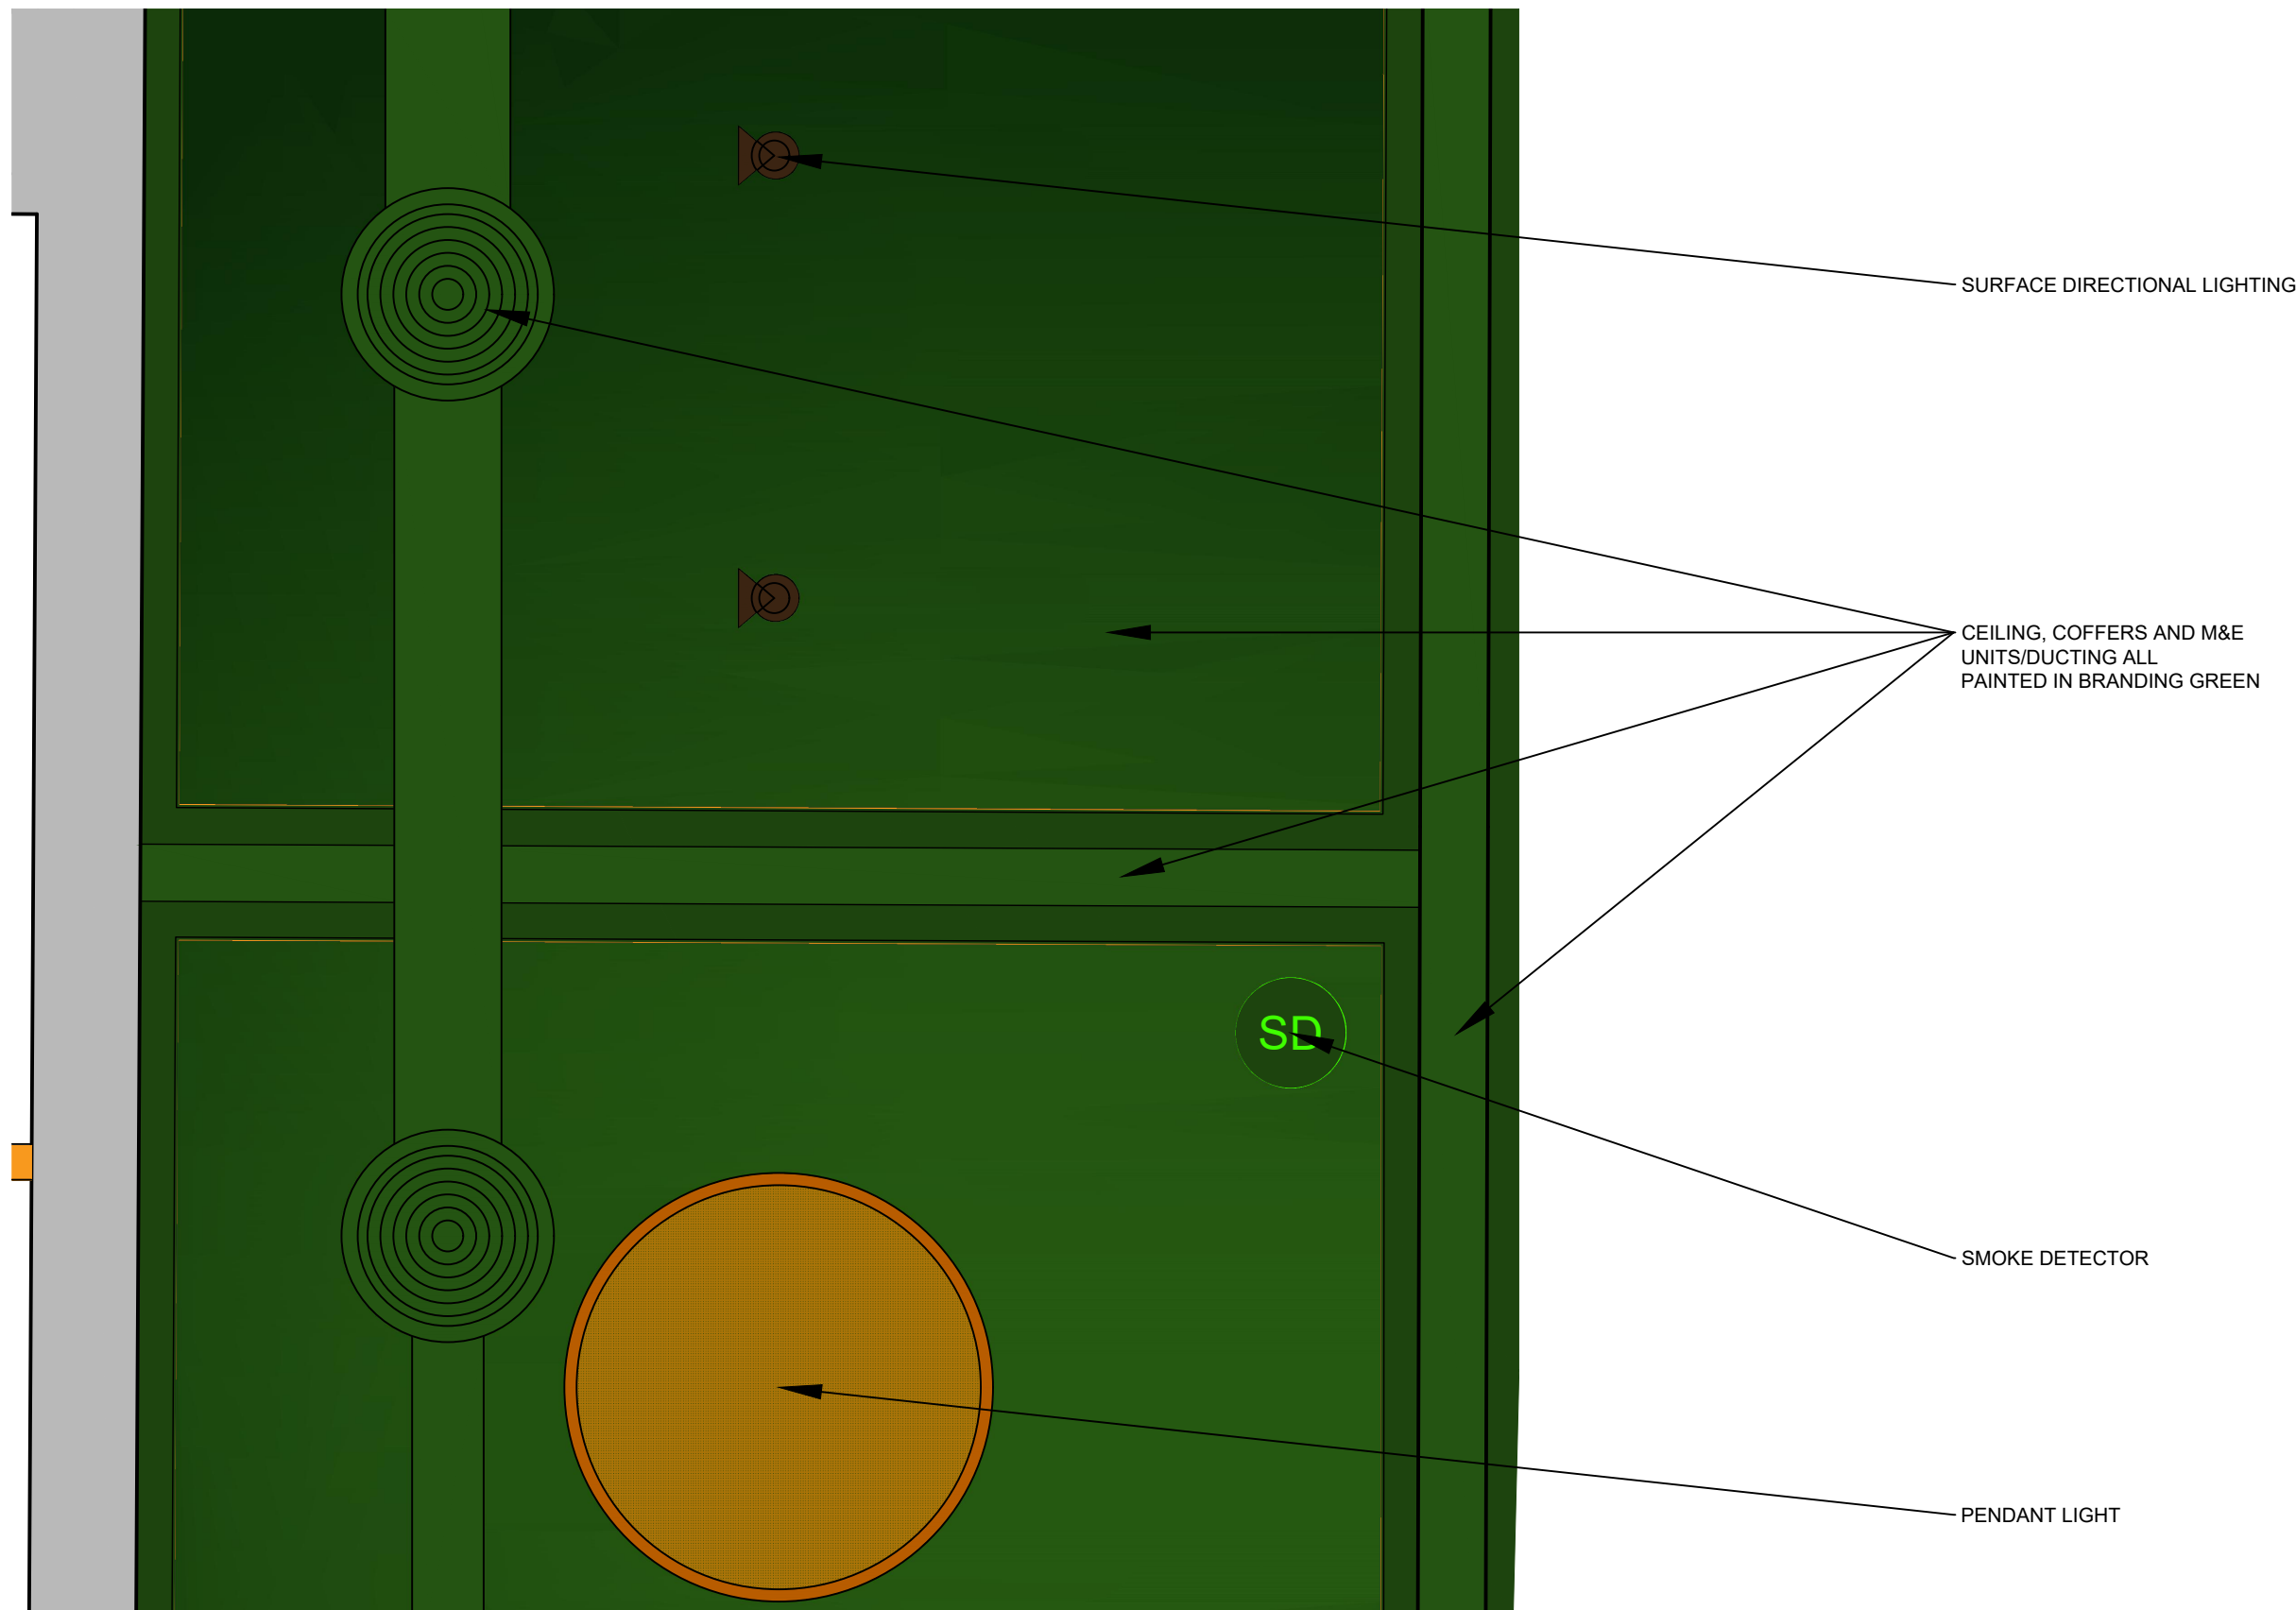

SECTION RENDERED REFLECTED CEILING PLAN


1:20

WALL TILES		
NAME	TYPE	
WALL PANELLING, DUCTING, AIR CONDITIONING UNITS AND CABLES, PAINTED IN BRANDING GREEN, REF: TBC		

FINISHES

FOR TENDER

ALL DIMENSIONS TO BE CHECKED ON SITE BEFORE CONSTRUCTION

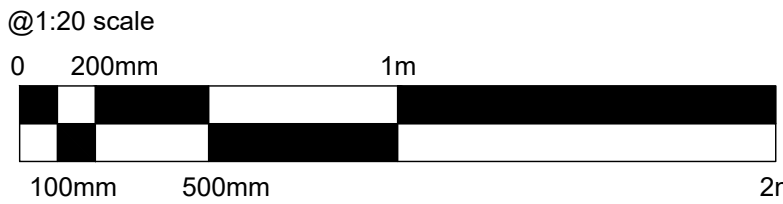

HARRISON INCE

ARCHITECTS INTERIOR DESIGNERS

PINS SOCIAL CLUB

CLIENT

SUNLIGHT HOUSE
LITTLE QUAY ST, MANCHESTER M3 3HP

PROJECT

PROPOSED SECTION AJ
M&E - COFFERS DETAIL

TITLE

DATE AUGUST 2025

SCALE 1:20 @ A1

JOB NO. 01

DWG. NO. AV208

DRAWN CAD/MSM-LEB

CHECKED

SECOND FLOOR
EASTGATE
2 CASTLE STREET
MANCHESTER
M3 4LZ
TEL: 0161 236 3650
EMAIL: enquiries@harrison-ince.co.uk