


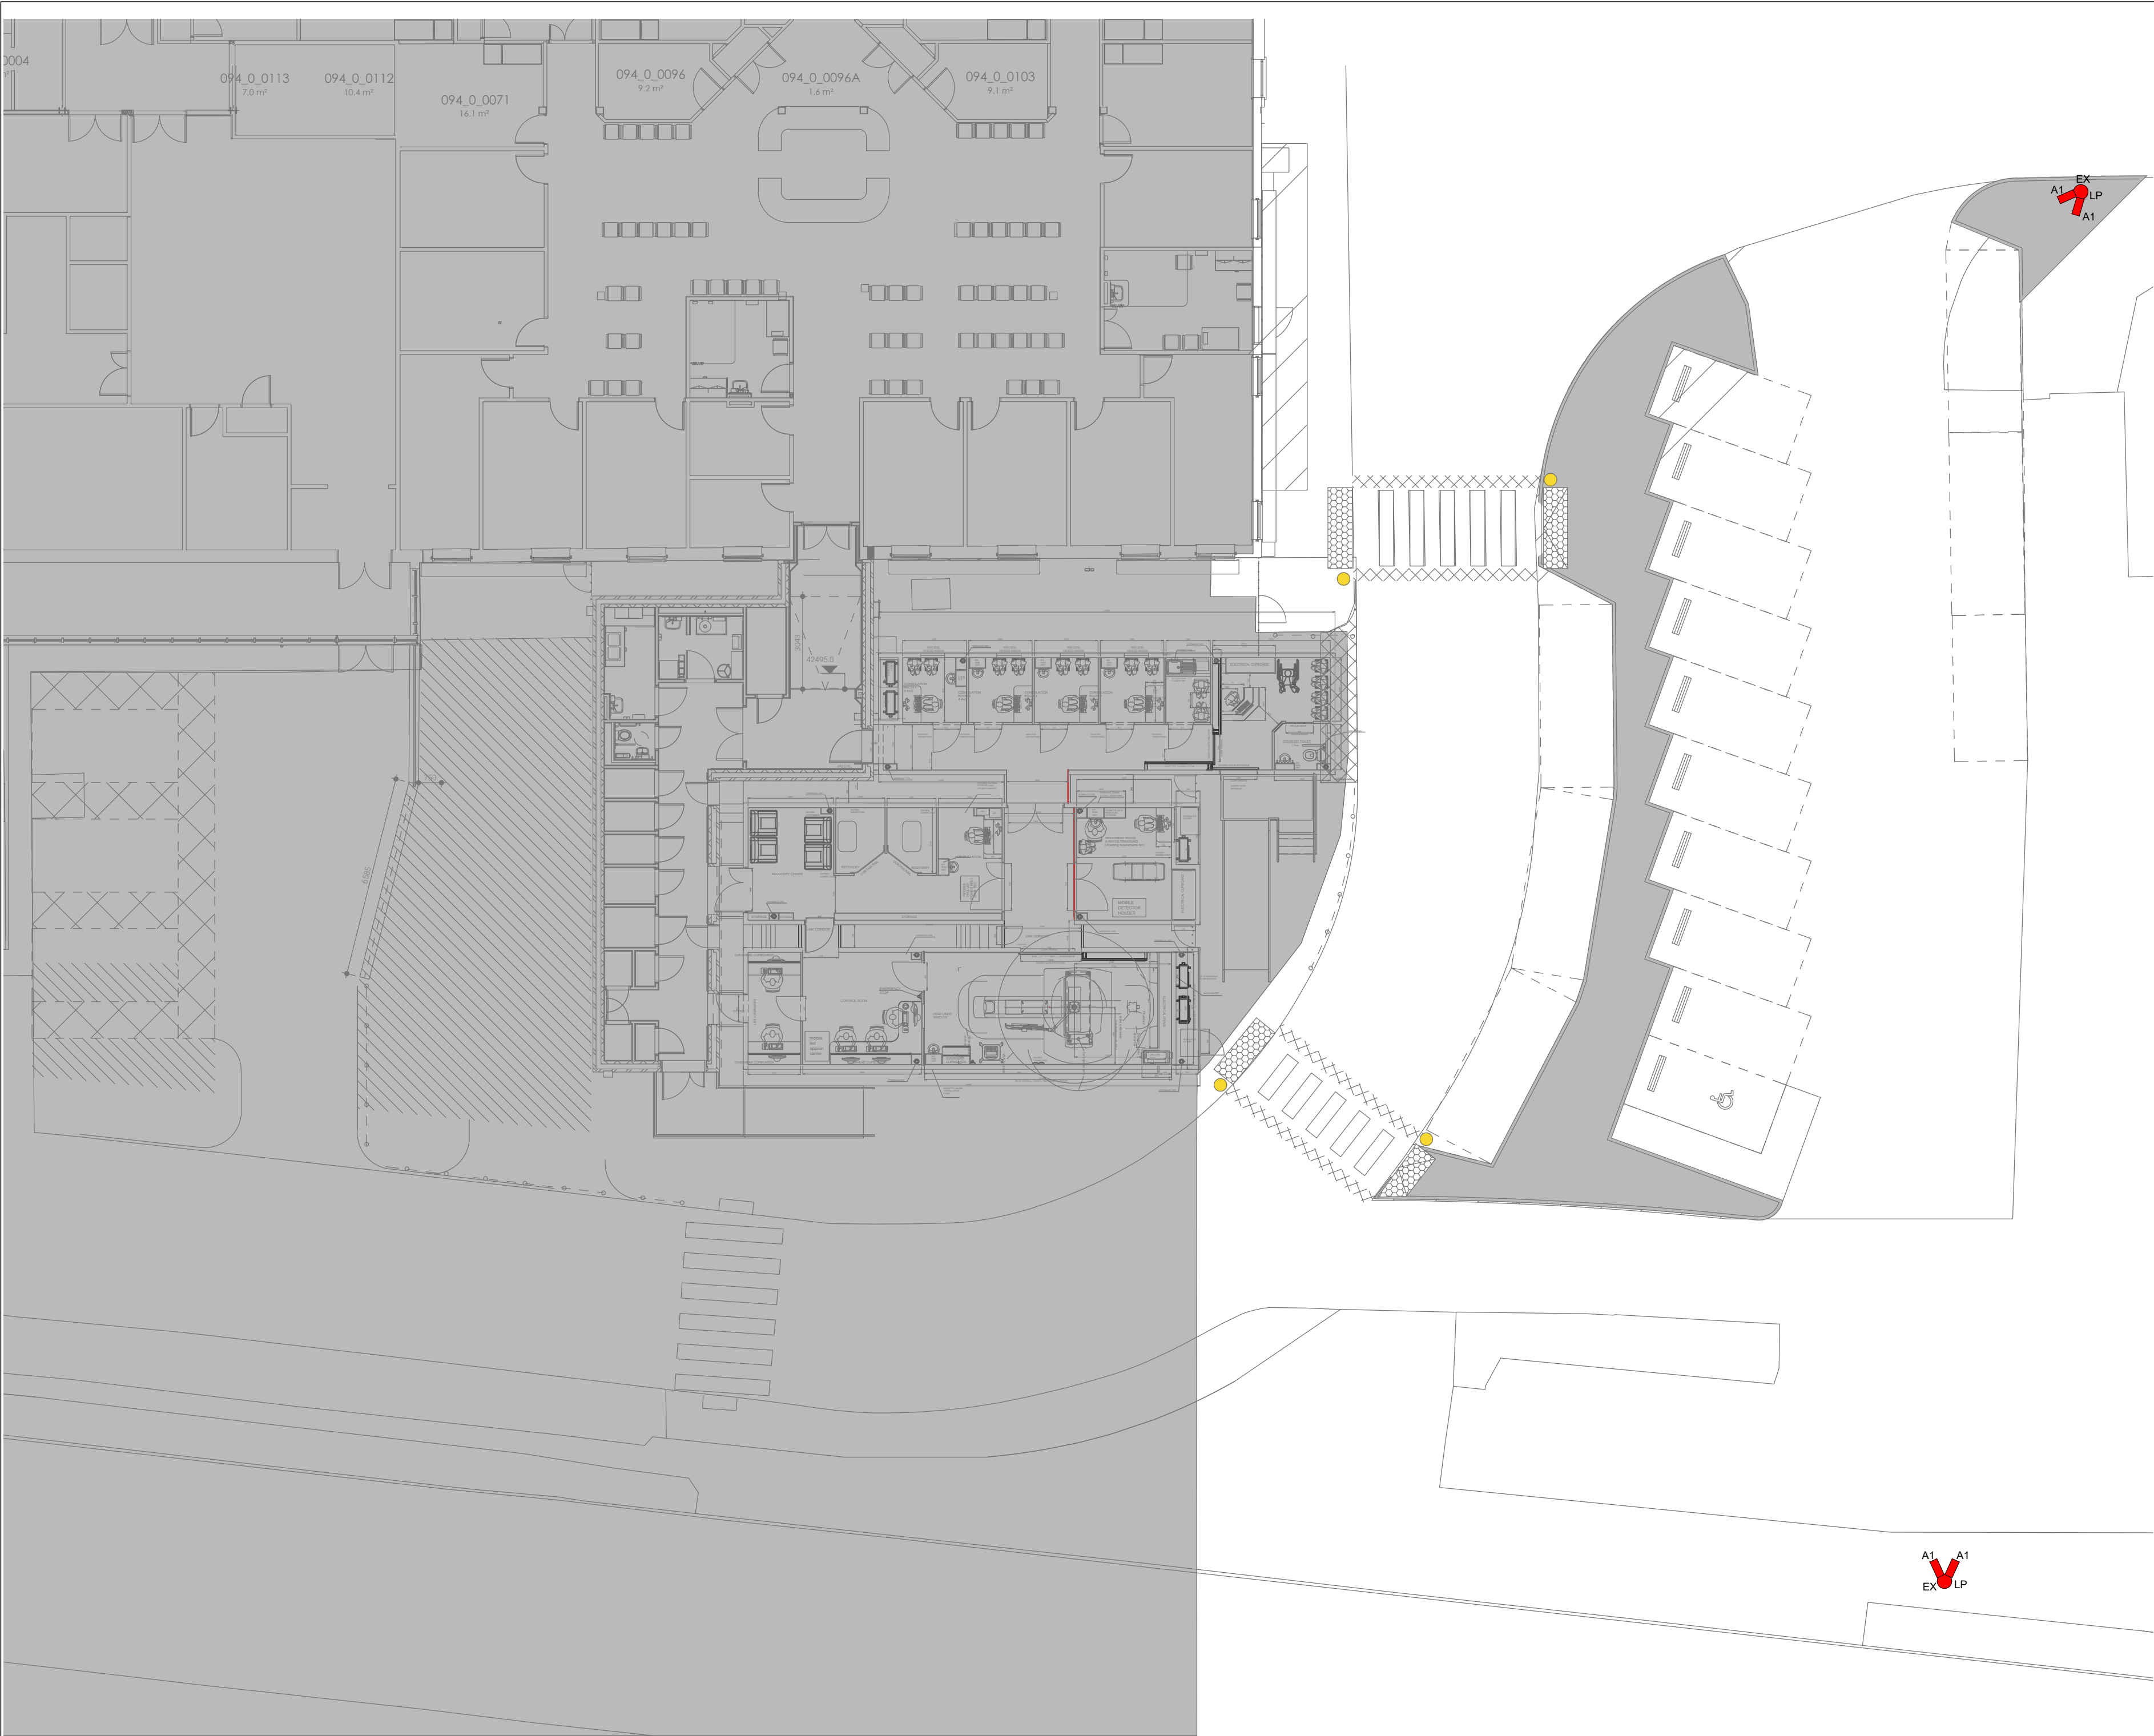

THIS DRAWING IS THE PROPERTY OF S.I.SEALY AND ASSOCIATES LTD. NO INFORMATION CONTAINED HEREON SHALL BE COPIED IN WHOLE OR IN PART, OR PASSED TO ANY OTHER PARTY WITHOUT WRITTEN CONSENT.
COPYRIGHT IS RESERVED. ©
THIS DRAWING SHALL NOT BE SCALED

RESIDUAL RISKS THAT CANNOT BE OMITTED BY DESIGN ARE HIGHLIGHTED ON THE DRAWING WITH THE SYMBOL **00**

A DESCRIPTION OF THE RISK AND THE REQUIRED ACTIONS ARE SCHEDULED BELOW :

RISK SCHEDULE	
No	DESCRIPTION
01	WORKING AT HEIGHT
02	ISOLATION OF EXISTING SERVICES
03	RISK OF ELECTRICAL SHOCK
04	WORKING IN LIVE AREAS OF HOSPITAL

01 **02** **03** **04**

NOTES

- NEW LED LIGHTING HEADS ARE TO REPLACE THE EXISTING LIGHTING HEADS.
- EXISTING LIGHTING COLUMNS AND CABLING ARE TO BE UTILISED FOR THE NEW LED LIGHTING HEADS.
- ALL EXTERNAL LIGHTING COLUMNS ARE FED VIA THE CONTACTOR REFERENCED DB/P1/8L2/8L3/9L1

LEGEND

- EX  LP EXISTING LAMP POST / LIGHTING COLUMN
- A1  A1 APOLLO LIGHTING 2NO. JACANA 2 LED FLOODLIGHTS. 20,000 LUMENS 150W.
-  STRIP OUT / MODIFICATION
-  SIMMON SIGNS ZEBRA CROSSING ILLUMINATED STEM AND A POST-TOP LED BELISHA BEACON. MODUPOST

P01	JR/GMW	11/12/2024	PRELIMINARY ISSUE
REV	DWN/CHK	DATE	DESCRIPTION
REVISION SCHEDULE			

NHS
Manchester University
NHS Foundation Trust

S.I.SEALY
Inwood Court ■ Stuart Road ■ Bredbury ■ Stockport ■ SK9 2SR
Tel: 0161 430 2044 ■ www.sisealy.co.uk

PROJECT
MANCHESTER UNIVERSITY FOUNDATION TRUST
WYTHENSHAW HOSPITAL
TEMPORARY MOBILE IMAGING UNIT AND RIGHT CAR PARK
ENABLING WORKS

TITLE
ELECTRICAL ENGINEERING SERVICES
LEVEL 00
EXTERNAL LIGHTING LAYOUT

STATUS
P

PURPOSE OF ISSUE
Preliminary

DRAWN BY
JR

CHECKED BY
GMW

DATE
04/12/2025

SCALE (@ A1L)
1: 150

PROJECT NUMBER
24070

FILE DRAWING NUMBER
24070-SIS-WYT094-XX-DR-E-63201

REV.
P01