


NOTES
All dimensions and levels to be checked on site
Any discrepancies are to be reported to the Architect before any work commences
This drawing shall not be scaled to ascertain any dimensions, work to figured dimensions only
This drawing shall not be reproduced without express written permission from AFL Architects Ltd.

DISCLAIMER
When this drawing is issued in CAD, it is an uncontrolled version issued for information only, to enable the recipient to prepare their own documents/drawings for which they are solely responsible.

SOFTWARE INTEROPERABILITY
AFL prepared this drawing using Autodesk REVIT Architecture.
AFL does not accept liability for any loss or degradation of any information held in the drawing resulting from the translation from the original file format to any other file format or from the recipients reading of it in any other programme.

Drawing adapted from:
EBL 1839-ELC-Z1-00-DR-A-00-101 13.10.2021

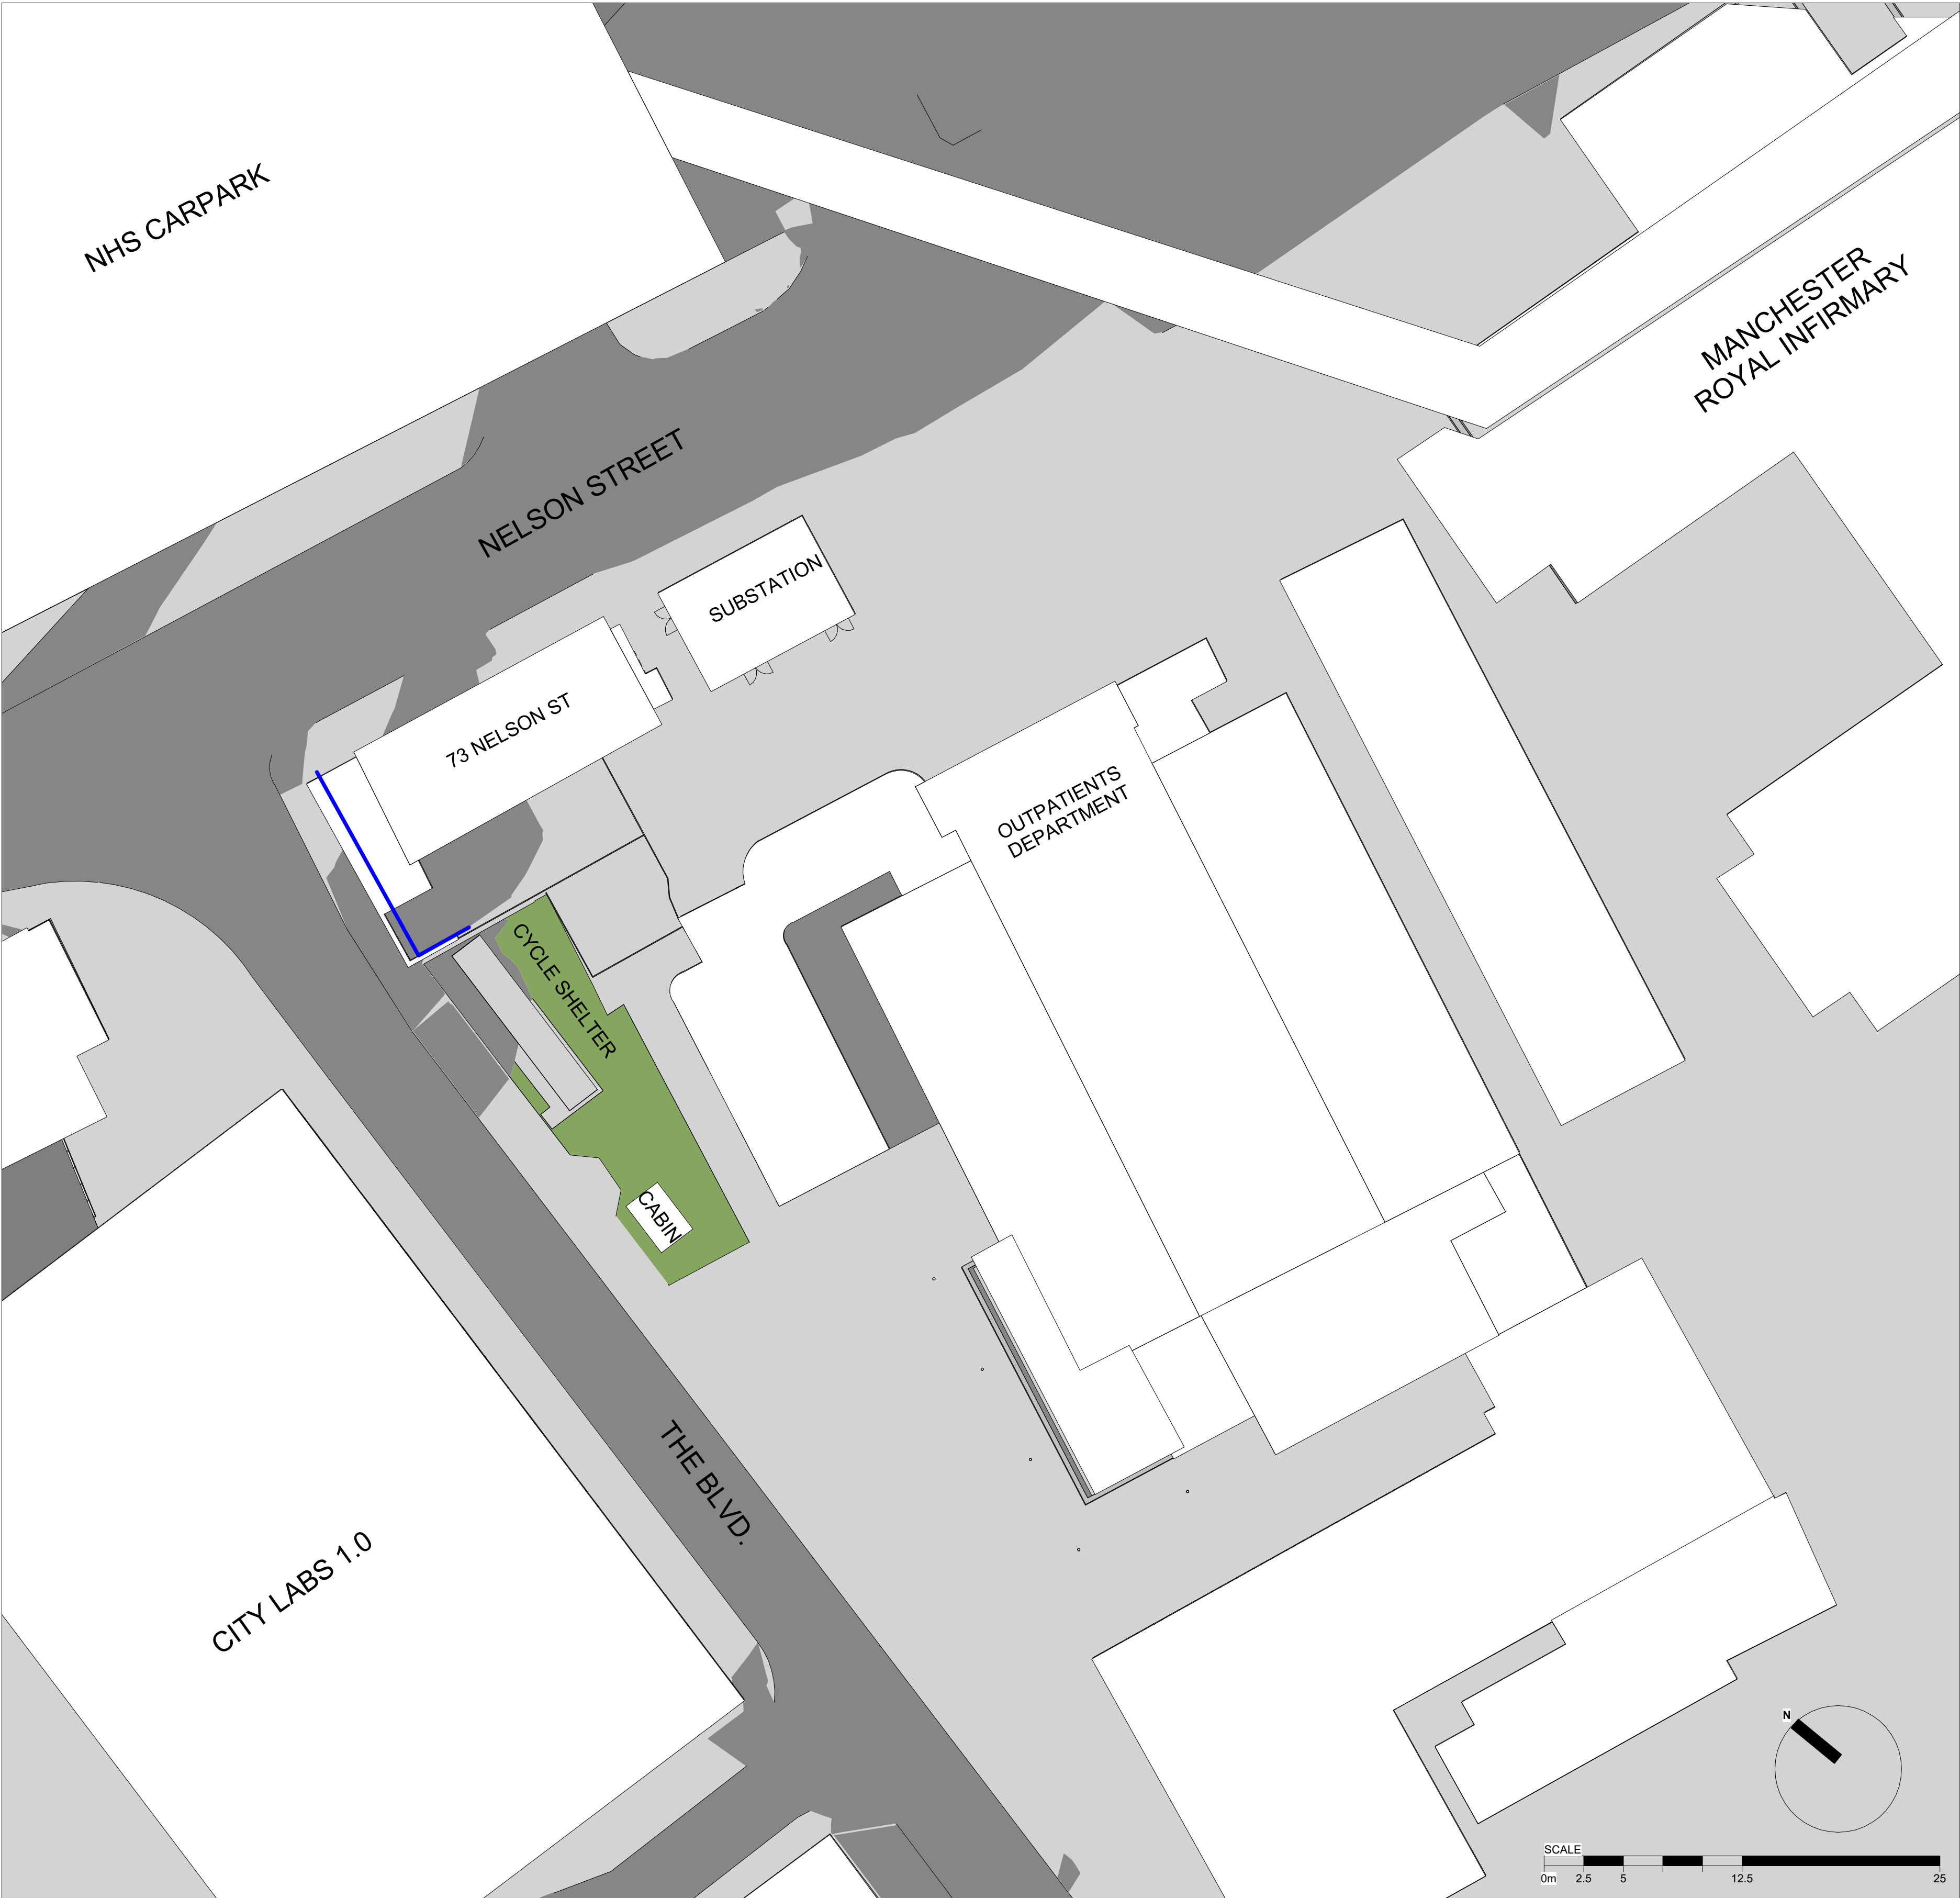

Existing Site Plan
1 : 250

P 3	12.08.25	AZS	Substation location updated.
P 2	27.09.24	PW	General Update
P 1	30.11.23	PW	First Issue

rev no.	rev date	rev by	description
project			

Nelson Street Sub Station

location
Manchester Royal Infirmary

Employer
EQUANS

client
AC Electrical (North) Ltd

AFL Architects
1st Floor
St Georges House
56 Peter Street
Manchester M2 3NQ
t: +44(0)161 236 6263
f: +44(0)161 236 6484
w: www.afl-architects.com
e: mail@afl-uk.com
twitter.com/AFLArchitects
key plan - N/A

AFL
architects

drawing title
Existing Site Plan

AFL job number	scale @ A1	drawn	PW	checked	MM
233145		rev date	12.08.25		
dwg purpose		status	rev		
Information		S2	P3		
bim project	origin	zone	level	type	role
NSS-AFL-XX-00-DR-A-00101		5-digit no.			