




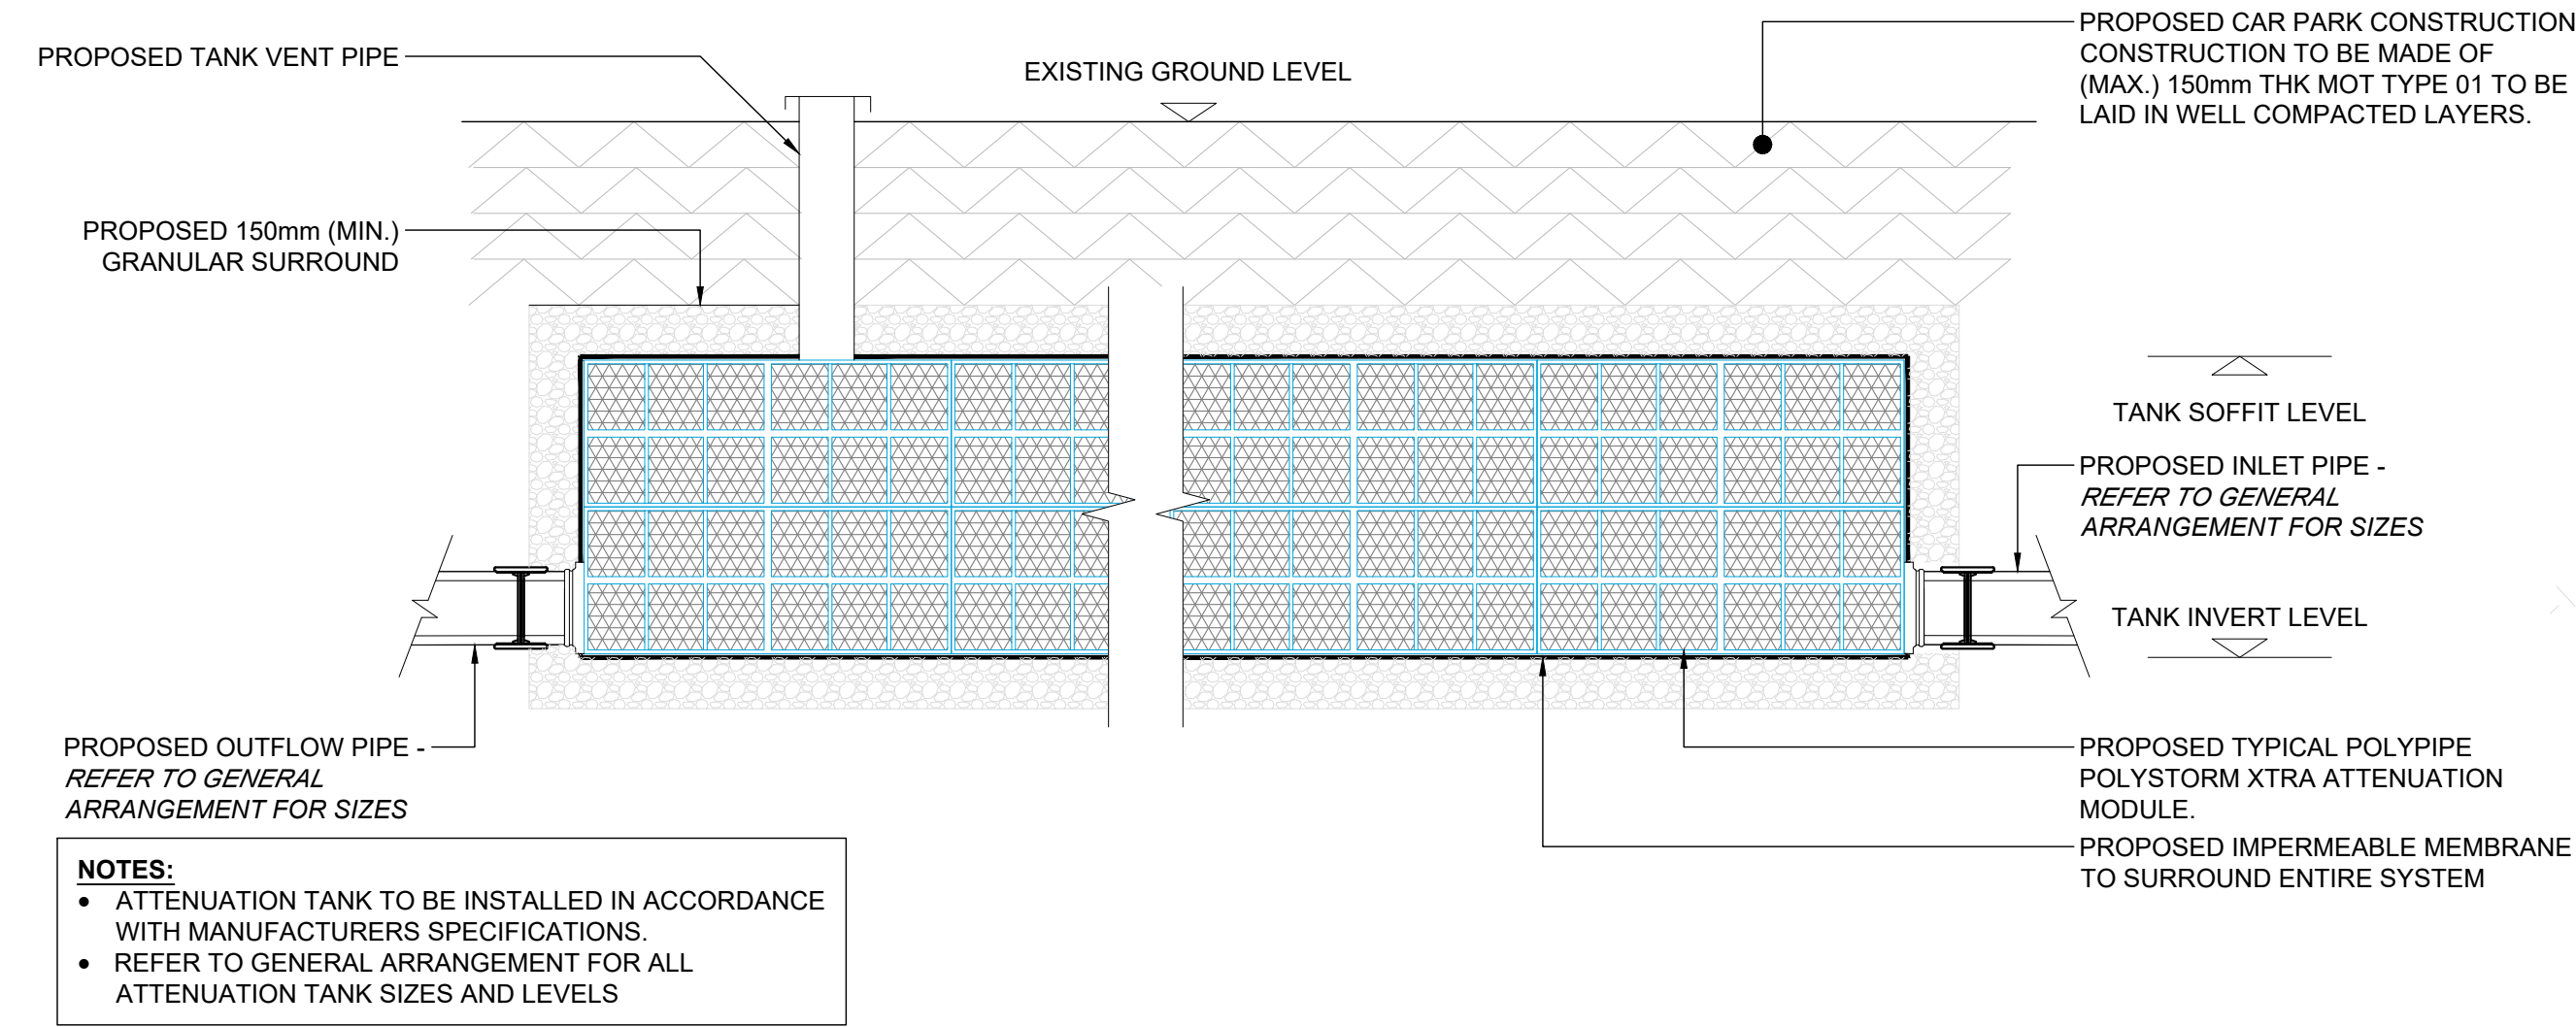


DETAIL 28
PROPOSED TYPICAL ATTENUATION TANK DETAIL
Scale 1:20

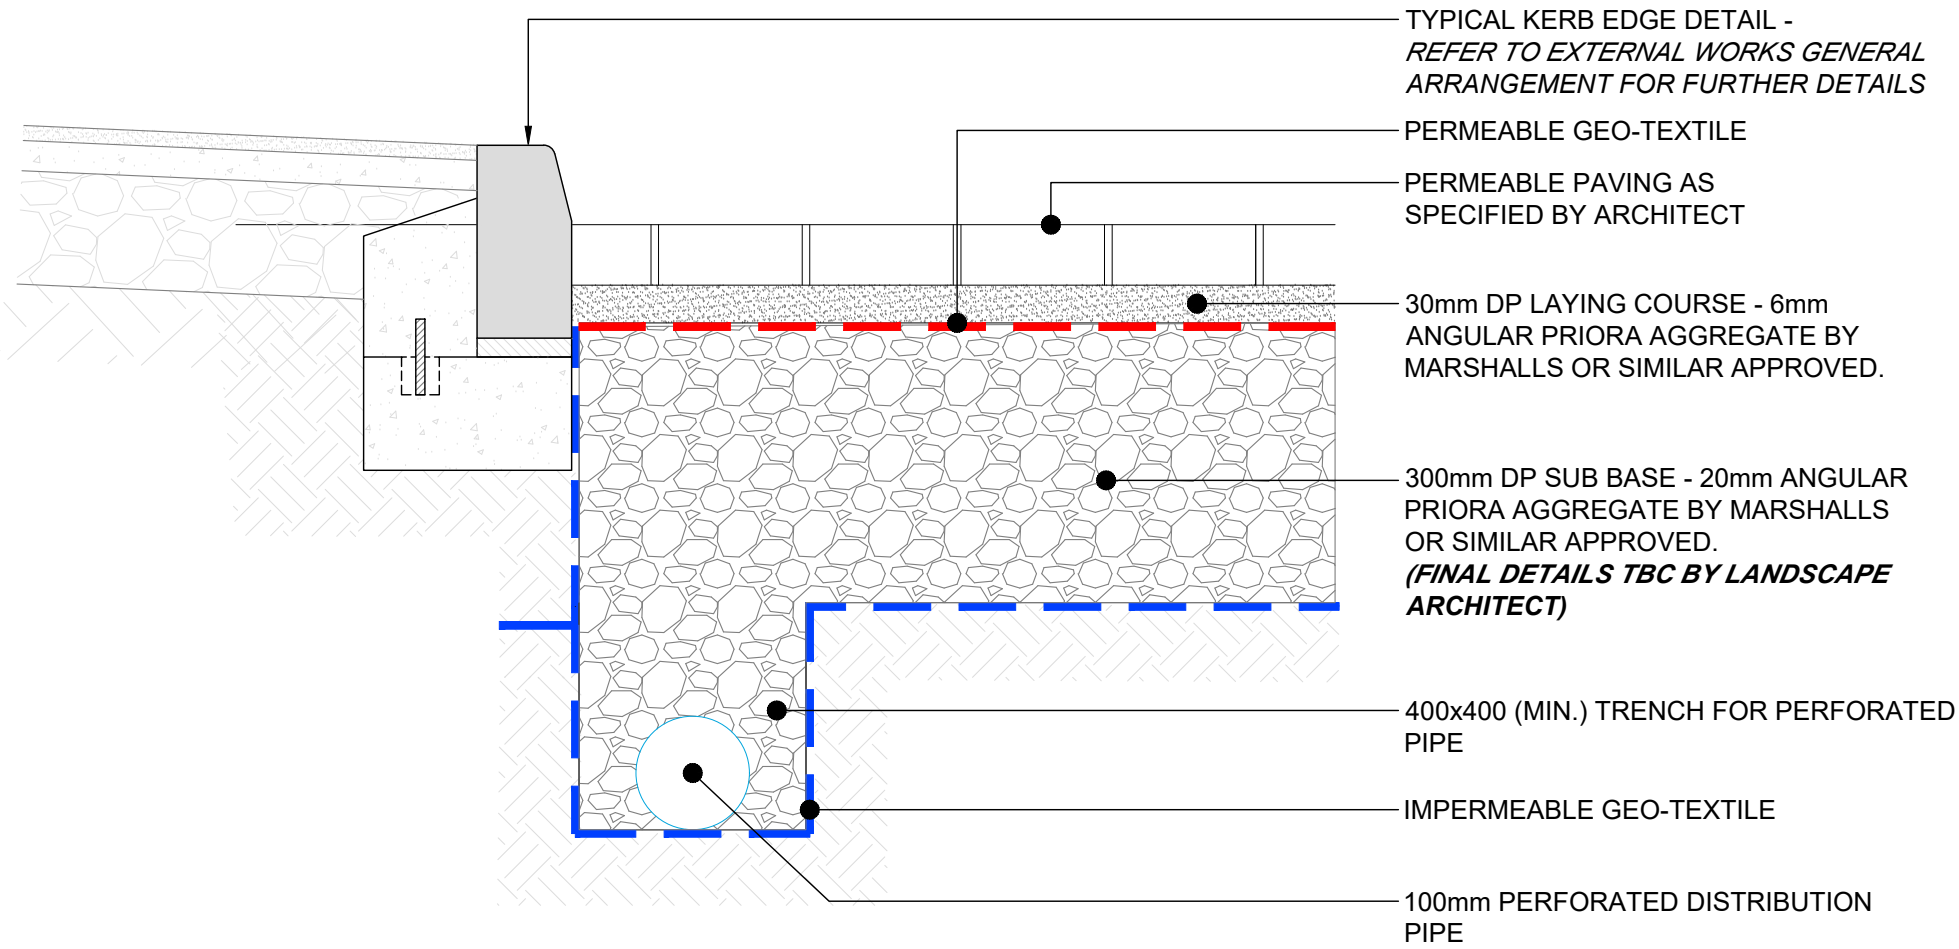

DETAIL 31
TYPICAL PERMEABLE PAVING DRAINAGE DETAIL
Scale 1:10



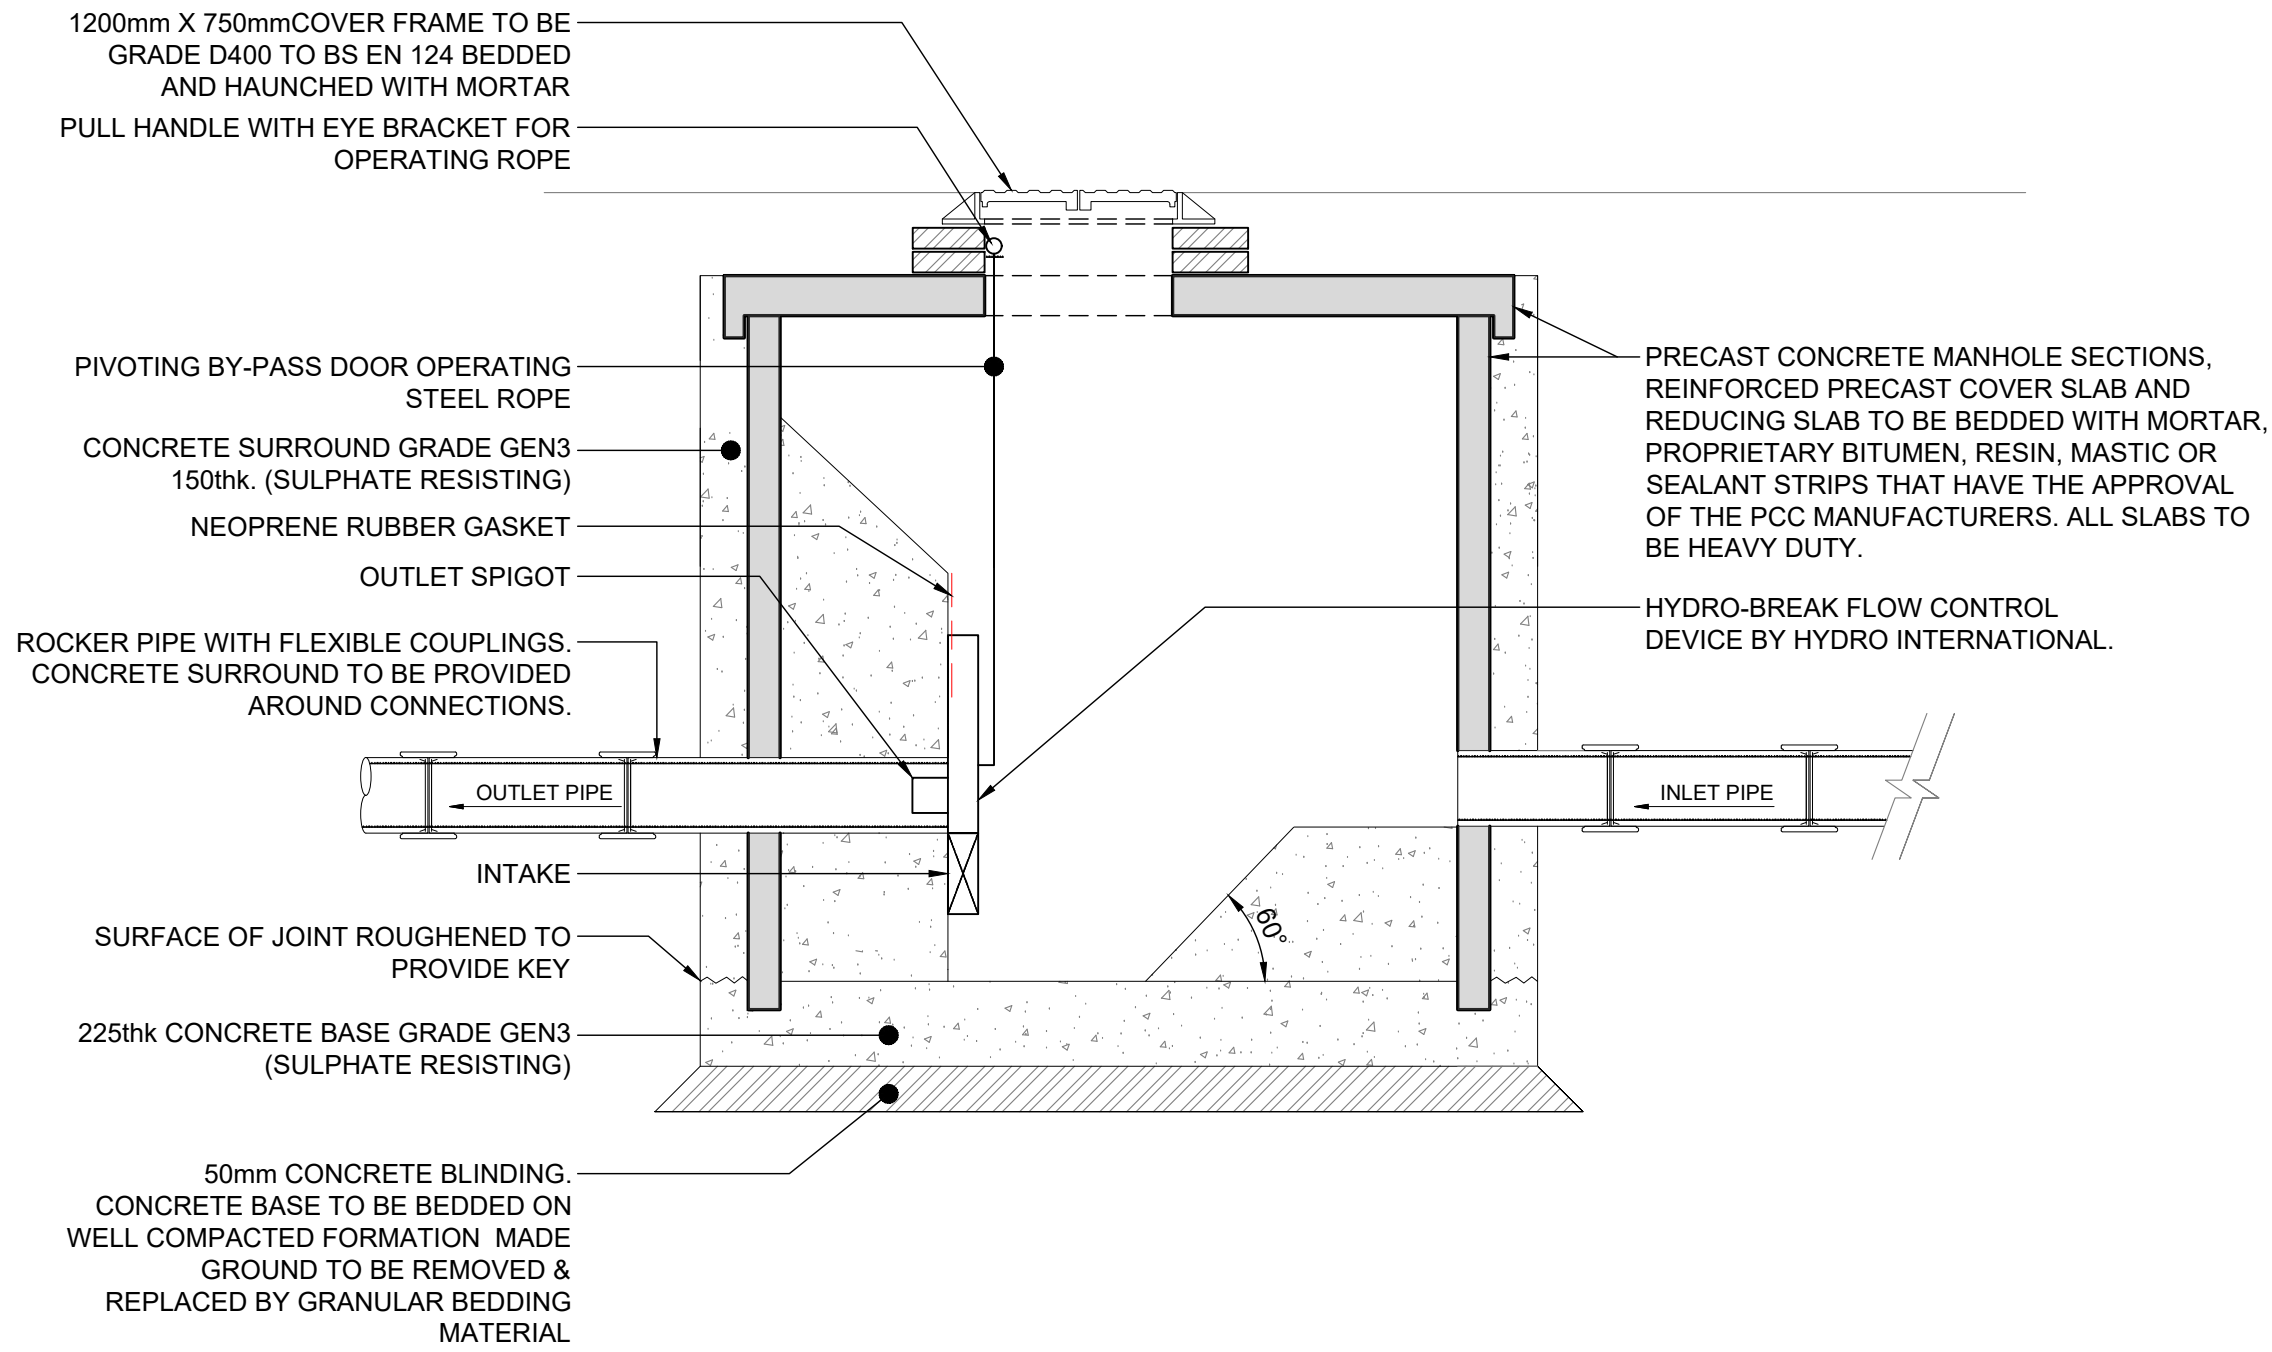


DETAIL 29
TYPICAL FLOW CONTROL CHAMBER DETAIL
Scale 1:20

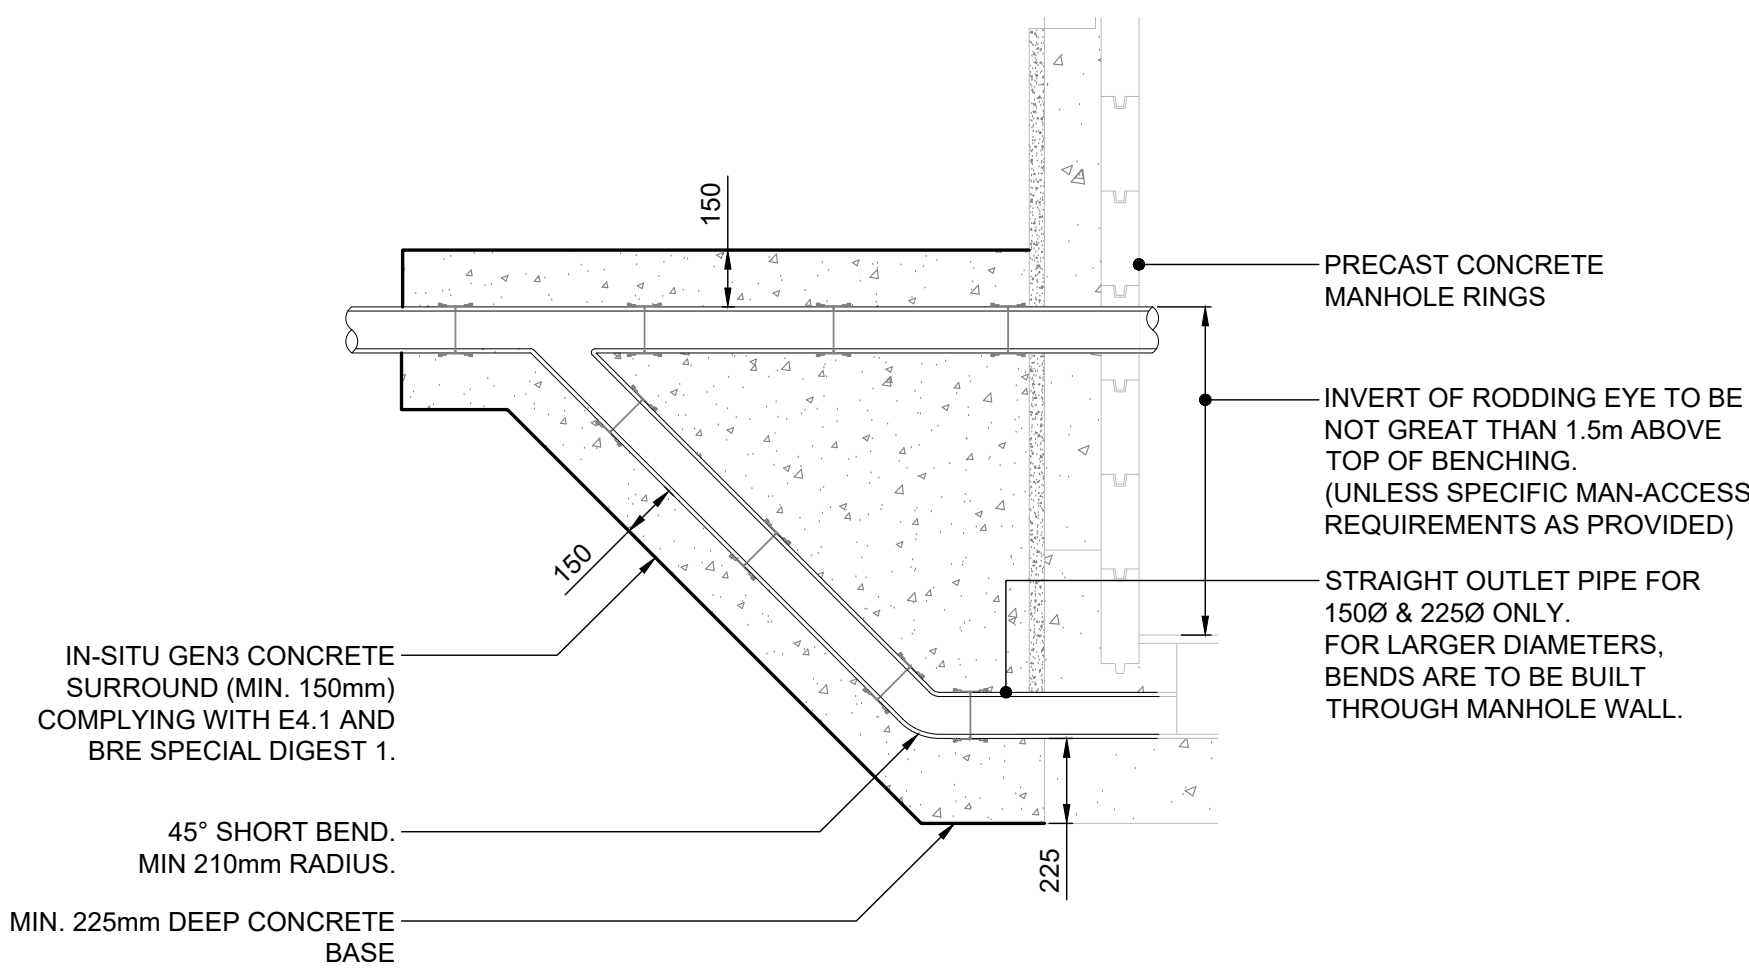

DETAIL 34
PROPOSED EXTERNAL RAMPED BACKDROP DETAIL
Scale 1:20

Advanced Silt Trap

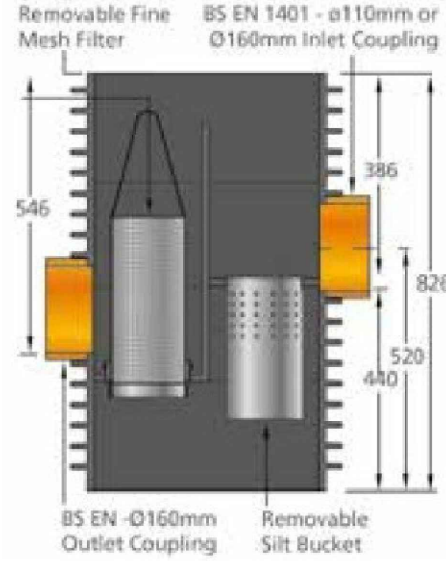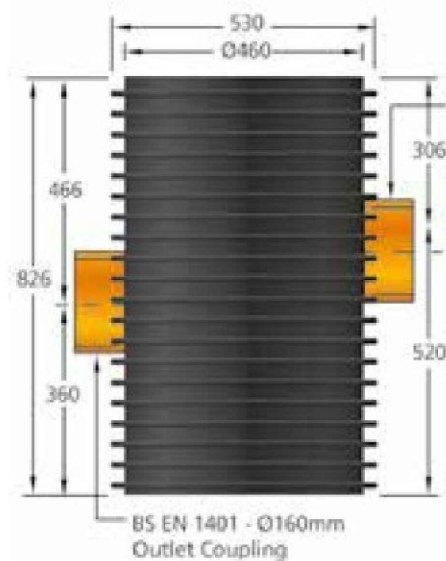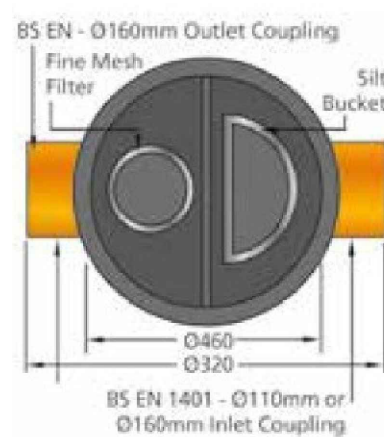

DETAIL 30
TYPICAL SILT TRAP DETAIL
Scale 1:10

notes :

1. IF THIS DRAWING HAS BEEN RECEIVED ELECTRONICALLY IT IS THE RECIPIENTS RESPONSIBILITY TO PRINT THE DOCUMENT TO THE CORRECT SCALE
2. ALL DIMENSIONS ARE IN MILLIMETRES UNLESS STATED OTHERWISE. IT IS RECOMMENDED THAT INFORMATION IS NOT SCALED OFF THIS DRAWING
3. THIS DRAWING SHOULD BE READ IN CONJUNCTION WITH ALL OTHER RELEVANT DRAWINGS AND SPECIFICATIONS
4. ANY DISCREPANCIES NOTED ON SITE ARE TO BE REPORTED TO THE ENGINEER IMMEDIATELY.
5. REFER TO FOLLOWING CCS CONSULTING DRAWINGS FOR FURTHER PLANS AND DETAILS:
 - HE031-CCS-ZZ-DR-S-0001-GENERAL NOTES
 - HE031-CCS-XX-DR-S-0100-EXTERNAL WORKS PLAN
 - HE031-CCS-XX-DR-S-0101-EXTERNAL WORKS TYPICAL DETAILS
 - HE031-CCS-XX-DR-S-0200-BELOW GROUND DRAINAGE PLAN
 - HE031-CCS-XX-DR-S-0201-BGD - TYPICAL DETAILS SHEET 01
 - HE031-CCS-XX-DR-S-0202-EXISTING BELOW GROUND SERVICES PLAN
 - HE031-CCS-XX-DR-S-0300-FOUNDATION PLAN
 - HE031-CCS-XX-DR-S-0400-CORRIDOR SUPERSTRUCTURE PLAN
 - HE031-CCS-XX-DR-S-0800-TYPICAL SECTIONS & DETAILS

C1	CONSTRUCTION ISSUE	27.03.25	JF	BF
T2	DETAIL 34 ADDED.	05.03.25	JF	BF
T1	TENDER ISSUE	14.02.25	JF	BF
P1	STAGE 03 ISSUE	05.12.24	JF	JPF
REV.	DESCRIPTION	DATE	DRW.	CHK.



APPOINTED PARTY LOGO/INFORMATION



PROJECT
WYTHENSHAW HOSPITAL - TARGETED LUNG HEALTH CHECK (TLHC)

TITLE
PROPOSED BELOW GROUND DRAINAGE - TYPICAL SECTIONS & DETAILS SHEET 02

STATUS D4	PURPOSE OF ISSUE FOR CONSTRUCTION		
DRAWN BY JF	CHECKED BY JPF	DATE DEC. '24	
SCALE (@A1) AS SHOWN		PROJECT NUMBER HE-031	
FILE DRAWING NUMBER HE031 - CCS - D4 - XX- DR - S - 0203			REV. C1