

NOTES:

ALL FIRE SAFETY EQUIPMENT LOCATIONS TO BE CHECKED BY FIRE ENGINEER. PLEASE REFER TO MECHANICAL PACKAGE FOR DETAILS ON MECHANICAL SCHEME.


ALL CABLING IN CUSTOMER AREAS WILL BE HOUSED WITHIN CONDUITS. TO BE COLOUR MATCHED.

ALL DUCTWORK WILL BE EXPOSED. TO BE COLOUR MATCHED TO CEILING IN CUSTOMER AREAS.

NO FIXINGS WILL BE MADE TO CORNICE DETAILING.

REFER TO LIGHTING PLAN FOR LIGHT FITTING DETAILS.

SCREEN TO BE FRONT FIXED TO SLAB

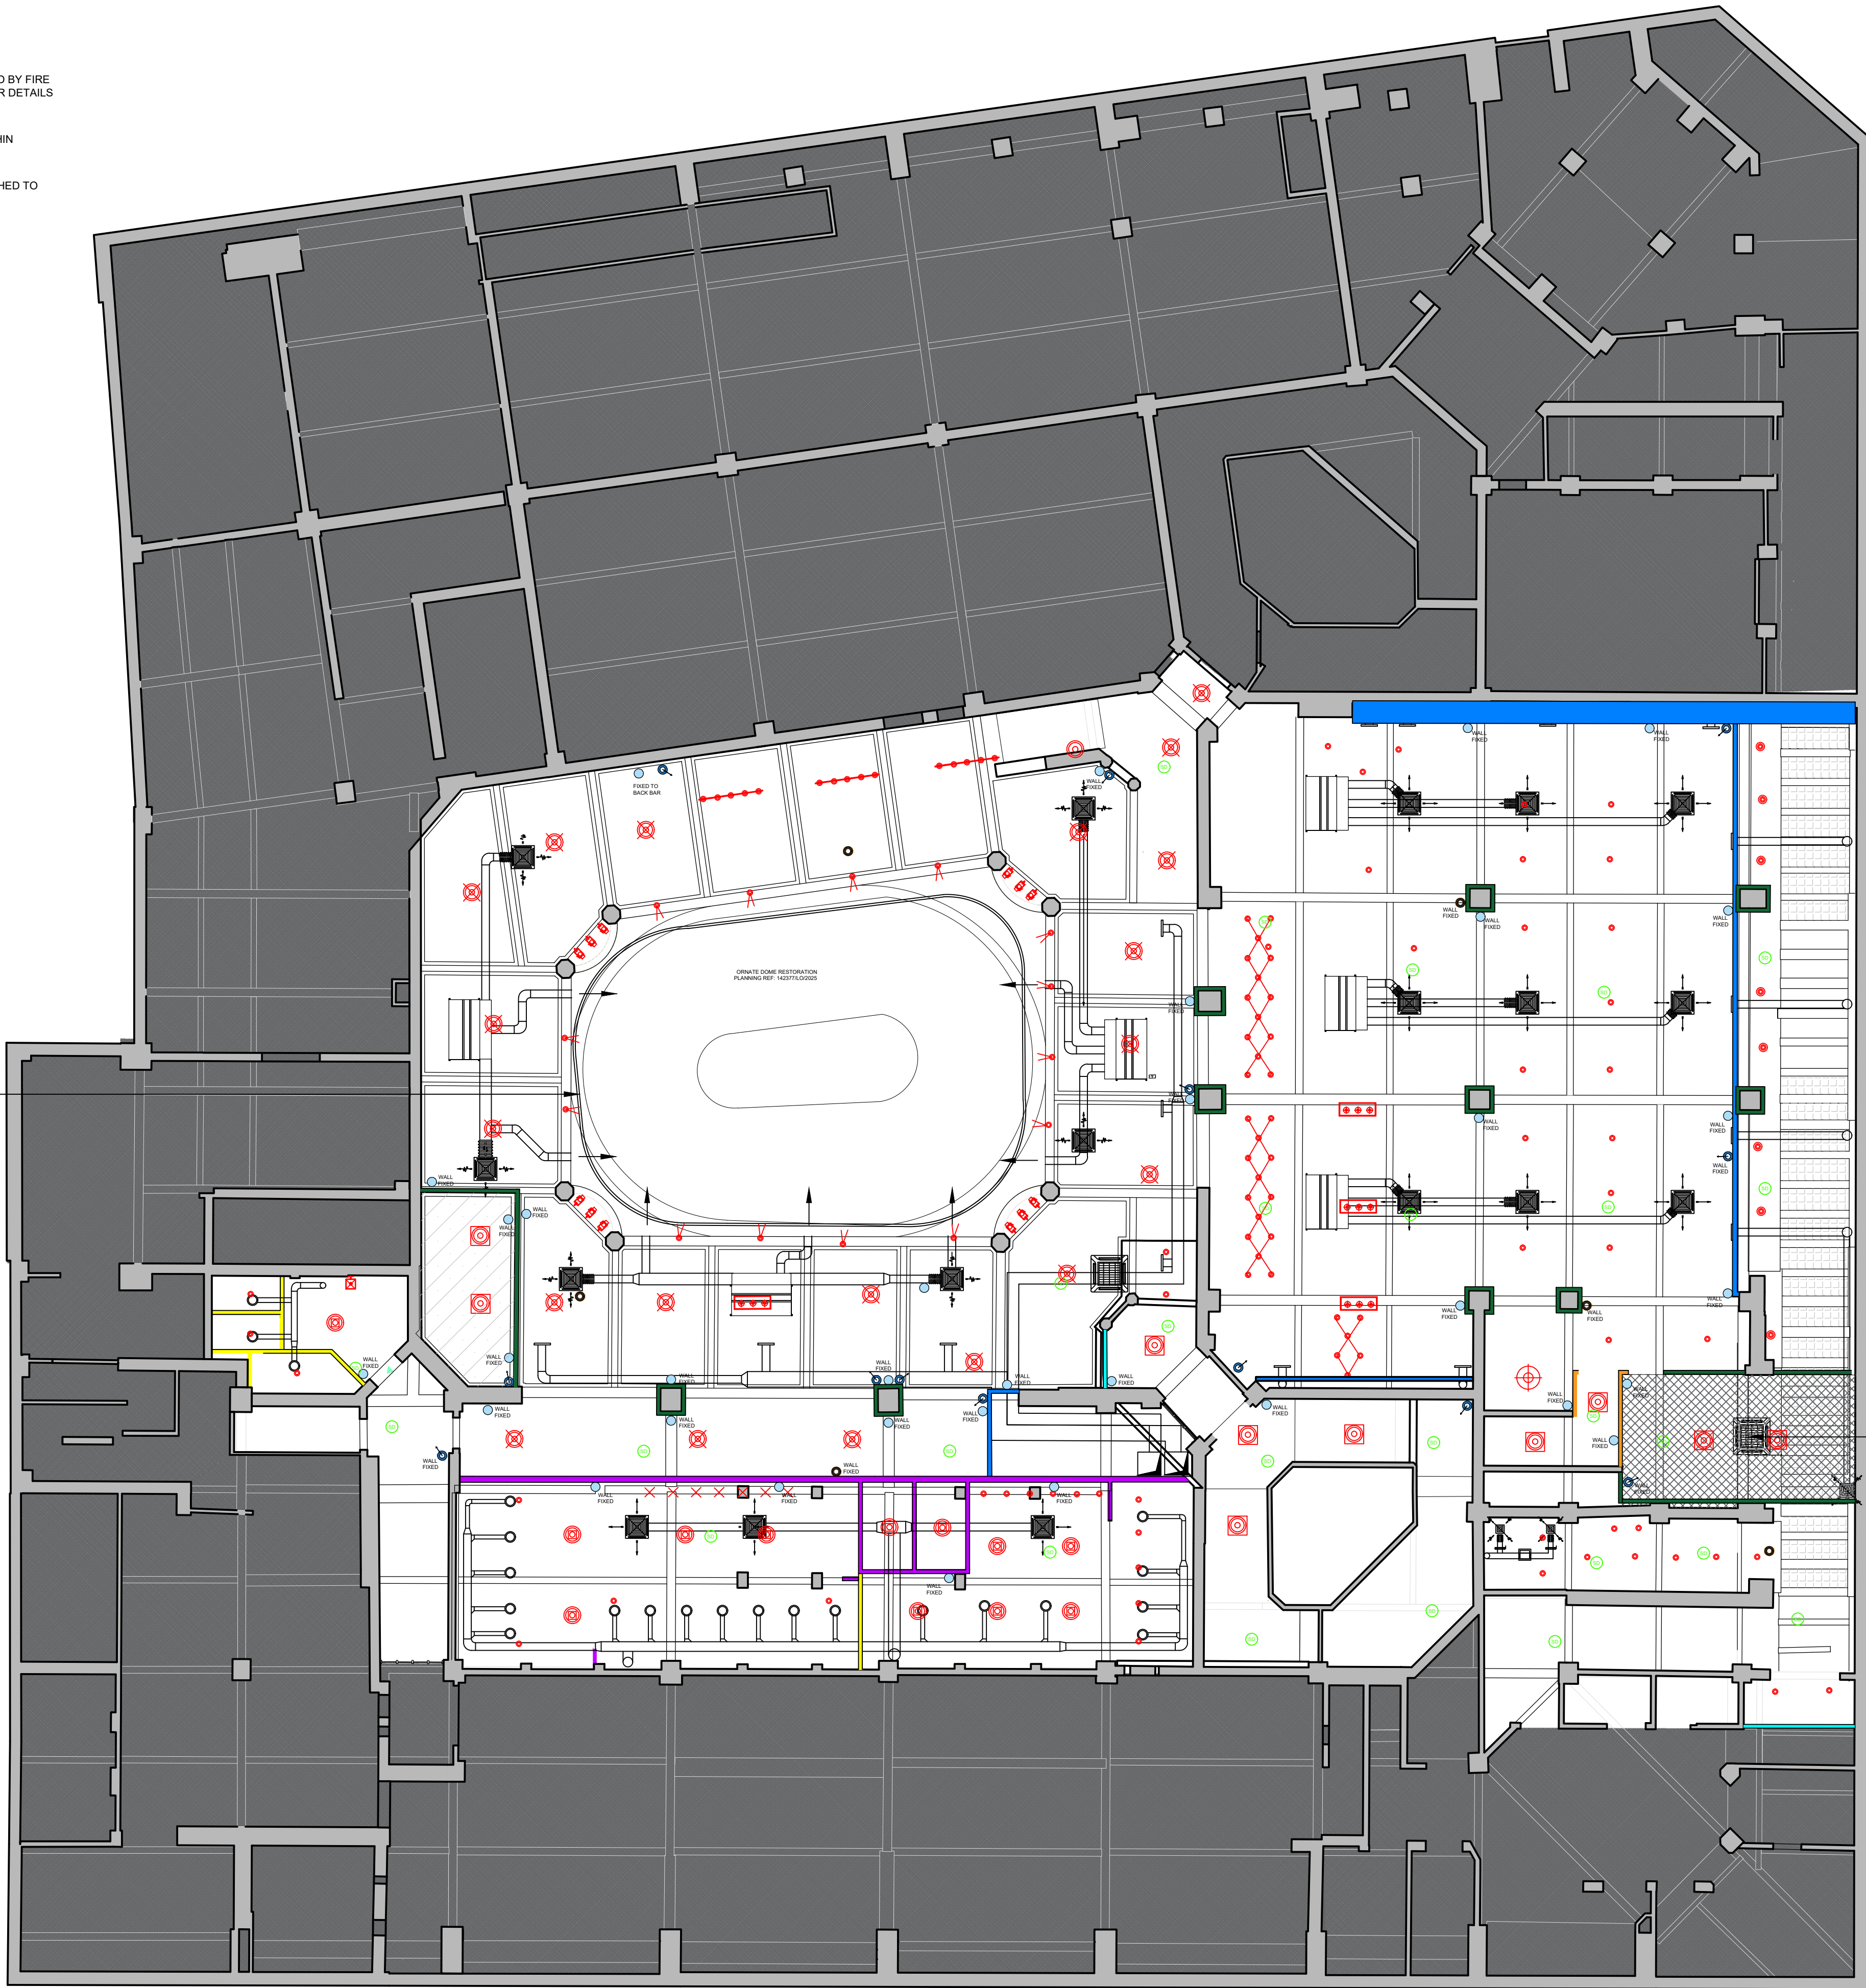

- EXIT** SELF CONTAINED MAINTAINED DIRECTIONAL EMERGENCY EXIT SIGN ILLUMINATED SUSPENDED "FIRE EXIT" SIGN 75mm LETTERS
- E** AREA COVERED BY MAINTAINED EMERGENCY LIGHT FITTING TO BS 5266, PART 1
- XB** XENON BEACON TO BE INSTALLED TO COMPLY WITH BS 5499.
- HD** AREA COVERED BY HEAT DETECTORS
- SD** AREA COVERED BY SMOKE DETECTORS
- FACP** FIRE ALARM CALL POINT
- FAIP** FIRE ALARM INDICATOR PANEL
- VP** VISION PANEL
- PB** PUSH BAR
- FRG** FIRE RESISTANT GLAZING ELEMENT.
- AS** ALARM SOUNDER
- VCS** VOICE COMMUNICATION SYSTEM

NOTE: EXISTING ALARM POINTS AND SOUNDERS MARKED IN BLACK NEW PROPOSED LOCATION MARKED IN GREEN

CEILING SYMBOLS

- 360 FISH EYE CAMERA**
- CCTV CAMERAS**
- WIFI ACCESS POINT**
- SPEAKERS**

SUSPENDED PLASTERBOARD CEILING REFER TO ACOUSTIC REPORT FOR SPECIFICATION

Do not scale from this drawing. All dimensions to be checked on site prior to manufacture and construction. This drawing is the property of Harrison Ince Holdings Limited and should not be reproduced without permission. All discrepancies to be brought to the attention of the architect immediately. This drawing is to be read in conjunction with the specification / bill of quantities and related drawings.

REVISIONS

-	PLANNING ISSUE	25.03.25	GW
A	ISSUE FOR COORDINATION	03.04.25	GW
B	CLIENT ISSUE	22.04.25	GW
C	PLANNING ISSUE	01.05.25	GW
D	PLANNING REF ISSUE	05.08.25	GW

KEY

- LANDLORD'S DEMISE (OUTSIDE SCOPE)**
- LANDLORD'S DEMISE (PINS SERVICES WITHIN SCOPE)**
- SHARED ZONE TO BE MAINTAINED (OUTSIDE SCOPE)**
- ACOUSTIC SOUND BOARD**
- NOTE: PLEASE REFER TO MECHANICAL DRAWING SET

ALL DIMENSIONS TO BE CHECKED ON SITE BEFORE CONSTRUCTION

FOR PLANNING

@1:100 scale



HARRISON INCE

ARCHITECTS INTERIOR DESIGNERS

PINS SOCIAL CLUB

CLIENT

SUNLIGHT HOUSE
LITTLE QUAY ST, MANCHESTER M3 3HP

PROJECT

PROPOSED REFLECTED CEILING PLAN
MEZZANINE

TITLE

DATE AUGUST 2025

JOB NO. 01

DRAWN CAD/GW

SCALE 1:100 @ A1

DWG. NO. AL005 D

CHECKED

SECOND FLOOR
EASTGATE
2 CASTLE STREET
MANCHESTER
M3 4LZ

TEL: 0161 236 3650
EMAIL: admin@harrison-ince.co.uk

PROPOSED RCP MEZZANINE

1:100